

HOMER2

SUITES BY HILTON

EL PASO, TEXAS

SHEET INDEX:

SHEET	DESCRIPTION	NO.	SHEET	DESCRIPTION	NO.	SHEET	DESCRIPTION	NO.
COVER SHEET		1						
CIVIL DRAWINGS			A4.71	CASEWORK - BREAKFAST SERVING COUNTER AND BUSSING STATION	54	FIRE ALARM DRAWINGS		105
UNDER SEPARATE COVER			A4.72	CASEWORK - MEDIA WALL AND COFFEE BAR	55	FA1.0	FIRE ALARM ONE LINE DIAGRAM	106
ARCHITECTURAL DRAWINGS			A4.73	CASEWORK - MEDIA WALL AND COFFEE BAR, DISH RECOVERY AND HOME2MARKET	56	FA2.0	FIRE ALARM-FIRST FLOOR PLAN	107
A0.01	FIRE PROTECTION NOTES AND DETAILS	2	A4.74	CASEWORK - FRONT DESK	57	FA2.1	FIRE ALARM-SECOND FLOOR PLAN	108
A0.02	ACCESSIBILITY DETAILS	3	A4.75	CASEWORK - BUSINESS CENTER, GUEST LAUNDRY AND VANITY	58	FA2.2	FIRE ALARM-FOURTH FLOOR PLAN	109
A0.03	ACCESSIBILITY DETAILS	4	A4.76	CASEWORK - WINDOW PERCH AND PERCH	59	FA2.3	FIRE ALARM-FOURTH FLOOR PLAN	110
A0.04	ACCESSIBILITY DETAILS	5	A4.77	CASEWORK - WORK STATION, MANAGER'S WORK SURFACE AND EMPLOYEE BREAKROOM	60	FA3.0	FIRE ALARM TYPICAL GUEST ROOM PLAN	111
A0.05	ACCESSIBILITY DETAILS	6	A4.78	CASEWORK - HOUSE LAUNDRY, ENGINEER'S OFFICE AND SALES OFFICE	61			
A0.06	SPECIFICATIONS	7	A5.01	EXTERIOR ELEVATIONS	62	PLUMBING DRAWINGS		
A0.07	NOTES & LEGENDS	8	A5.02	EXTERIOR ELEVATIONS & WINDOW SCHEDULE	63	P1.0	PLUMBING NOTES	112
A0.08	PARTITION TYPES	9	A5.01	3D VIEWS	64	P1.1	PLUMBING LEGENDS AND SCHEDULES	113
A0.09	PARTITION TYPES	10	A5.01	3D VIEWS	65	P2.0	FIRST FLOOR SEWER PLAN	114
A0.10	EGRESS PLANS	11	A6.01	BUILDING SECTIONS	66	P2.1	SECOND FLOOR SEWER PLAN	115
A0.11	EGRESS PLANS	12	A6.02	BUILDING SECTIONS	67	P2.2	THIRD FLOOR SEWER PLAN	116
A1.01	SITE PLAN	13	A6.11	WALL SECTIONS	68	P2.3	FOURTH FLOOR SEWER PLAN	117
A1.02	SITE PLAN DETAILS	14	A6.12	WALL SECTIONS	69	P2.4	ROOF STORM SEWER PLAN	118
A1.03	SITE PLAN DETAILS	15	A6.13	WALL SECTIONS	70	P3.0	FIRST FLOOR WATER PLAN	119
A2.01	FIRST FLOOR PLAN	16	A6.14	DETAILS	71	P3.1	SECOND FLOOR WATER PLAN	120
A2.02	SECOND FLOOR PLAN	17	A7.00	DOOR SCHEDULE	72	P3.2	THIRD FLOOR WATER PLAN	121
A2.03	THIRD FLOOR PLAN	18	A7.01	FLOOR TRANSITIONS	73	P3.3	FOURTH FLOOR WATER PLAN	122
A2.04	FOURTH FLOOR PLAN	19				P3.4	ROOF WATER PLAN	123
A2.05	ROOF PLAN	20				P4.0	PLUMBING RISERS	124
A3.01	FIRST FLOOR REFLECTED CEILING PLAN	21				P4.1	PLUMBING RISERS	125
A3.02	SECOND FLOOR REFLECTED CEILING PLAN	22	MECHANICAL			P5.0	PLUMBING DETAILS	126
A3.03	THIRD FLOOR REFLECTED CEILING PLAN	23	M1.0	MECHANICAL GENERAL SPECIFICATIONS & SYMBOLS	74	P5.1	PLUMBING DETAILS	127
A3.04	FOURTH FLOOR REFLECTED CEILING PLAN	24	M1.1	MECHANICAL TECHNICAL SCHEDULES	75	P6.0	PLUMBING SITE PLAN	128
A4.01	ENLARGED PLANS - KING STUDIO	25	M2.0	FIRST FLOOR MECHANICAL PLAN	76	P7.0	PLUMBING GUEST ROOM PLANS	129
A4.02	ENLARGED PLANS - KING STUDIO CONNECTING	26	M2.1	SECOND FLOOR MECHANICAL PLAN	77	P7.1	PLUMBING GUEST ROOM PLANS	130
A4.03	ENLARGED PLANS - KING STUDIO ACCESSIBLE	27	M2.2	THIRD FLOOR MECHANICAL PLAN	80	P7.2	ENLARGED STORAGE WATER HEATER ROOM	131
A4.04	ENLARGED PLANS - KING 1 BEDROOM	28	M2.3	FOURTH FLOOR MECHANICAL PLAN	81			
A4.05	ENLARGED PLANS - KING 1 BEDROOM	29	M2.4	ROOF MECHANICAL PLAN	82	STRUCTURAL DRAWINGS		
A4.06	ENLARGED PLANS - KING 1 BEDROOM ACCESSIBLE	30	M3.0	MECHANICAL INSTALLATION DETAILS	83	S1	STRUCTURAL NOTES & DETAILS	132
A4.07	ENLARGED PLANS - KING 1 BEDROOM ACCESSIBLE	31	M4.0	MECHANICAL TYPICAL GUESTROOM PLAN	84	S2	FOUNDATION PLAN	133
A4.08	ENLARGED PLANS - 2 QUEEN STUDIO	32	M5.0	MECHANICAL COMCHECK REPORT	85	S3	SECOND FLOOR FRAMING PLAN	134
A4.09	ENLARGED PLANS - 2 QUEEN STUDIO	33	M6.0	MECHANICAL HEATING COOLING LOAD	86	S4	THIRD FLOOR FRAMING PLAN	135
A4.10	ENLARGED PLANS - 2 QUEEN STUDIO - CONNECTING	34				S5	FOURTH FLOOR FRAMING PLAN	136
A4.11	ENLARGED PLANS - 2 QUEEN STUDIO - CONNECTING	35	ELECTRICAL DRAWINGS			S6	ROOF FRAMING PLAN	137
A4.12	ENLARGED PLANS - 2 QUEEN STUDIO - ACCESSIBLE	36	E1.0	ELECTRICAL ONE LINE DIAGRAM	87	S7	FOUNDATION DETAILS	138
A4.13	ENLARGED PLANS - 2 QUEEN STUDIO - ACCESSIBLE	37	E1.1	ELECTRICAL SHORT CIRCUIT & VOLTAGE DROP CALCULATIONS	88	S8	TRUSS DETAILS	139
A4.41	ENLARGED BATH PLANS AND ELEVATIONS - TYPICAL GUESTROOM BATHS	38	E1.2	ELECTRICAL NOTES & LEGENDS OF SYMBOLS	89	S9	SECTIONS	140
A4.42	ENLARGED BATH PLANS AND ELEVATIONS - TYPICAL GUESTROOM BATHS	39	E2.0	FIRST FLOOR ELECTRICAL PLAN	90	S10	NAILING PATTERN, WALL NOTES, SCHEDULES AND DETAILS	141
A4.49	GUEST ROOM BLOCKING DETAILS	40	E2.1	SECOND FLOOR ELECTRICAL PLAN	91			
A4.50	ENLARGED CONSTRUCTION PLAN- LOBBY	41	E2.2	THIRD FLOOR ELECTRICAL PLAN	92			
A4.51	ENLARGED FINISH PLAN- LOBBY	42	E2.3	FOURTH FLOOR ELECTRICAL PLAN	93			
A4.52	ENLARGED FURNITURE AND EQUIPMENT PLAN- LOBBY	43	E2.4	ROOF ELECTRICAL POWER PLAN	94			
A4.53	ENLARGED RCP PLAN- LOBBY	44	E3.0	PARTIAL ENLARGED FIRST FLOOR POWER PLAN	95			
A4.54a	INTERIOR ELEVATIONS- LOBBY	45	E4.0	GUEST ROOM ELECTRICAL PLANS	96			
A4.54b	INTERIOR ELEVATIONS- PUBLIC SPACES	46	E4.1	GUEST ROOM ELECTRICAL PLANS	97			
A4.55a	INTERIOR ELEVATIONS- PUBLIC SPACES & DETAILS	47	E5.0	ELECTRICAL SITE PLAN	98			
A4.55b	INTERIOR ELEVATIONS- LOBBY & CORRIDOR	48	E5.1	ELECTRICAL PHOTOMETRIC PLAN	99			
A4.56	ENLARGED PLANS- PUBLIC SPACES	49	E5.2	ELECTRICAL CUT SHEET	100			
A4.60	ENLARGED POOL PLANS	51	E6.0	ELECTRICAL PANELS	101			
A4.62	POOL DETAILS	52	E6.1	ELECTRICAL PANELS	102			
A4.70	CASEWORK - BREAKFAST SERVING COUNTER	53	E7.0	ELECTRICAL DETAILS	103			
			E8.0	ELECTRICAL COMCHECK REPORT	104			

ARCHITECT: R55 ARCHITECTS, LLC
CONTACT: SHANE SIGRIST
PO BOX 270035
FLOWER MOUND, TX 75027
817/536-9258

MEP ENGINEER: MEP GREEN DESIGNS, PLLC
CONTACT: BUNG VU
17047 EL CAMINO REAL, SUITE 211
HOUSTON, TX 77058
TELE: 281-786-1195
CELL: 832/276-0752
FAX: 281/282-9144

STRUCTURAL ENGINEER: MILLETT ENGINEERING GROUP
CONTACT: JOHN MILLETT
3606 CONVENT DR.
FT. WORTH, TEXAS 76028
817/610-9094
FAX: 817/610-9398

ACCESSIBILITY:

GENERAL CONTRACTOR SHALL EMPLOY SERVICES OF THIRD PARTY REGISTERED ACCESSIBILITY SPECIALIST (RAS) TO PROVIDE INTERMITTENT INSPECTIONS DURING CONSTRUCTION AND FINAL INSPECTION PRIOR TO OPENING. GENERAL CONTRACTOR RESPONSIBLE FOR ACCESSIBILITY DEFICIENCIES THAT COULD HAVE BEEN CORRECTED DURING CONSTRUCTION INSPECTION. INSPECTIONS SHALL OCCUR DURING FRAMING TO ASSURE COMPLIANCE AS REQUIRED. NOTIFY ACCORDINGLY IF DISCREPANCIES OR ISSUES OCCUR.

ENERGY CODE REQUIREMENTS:

1. AT EXTERIOR WALLS, PROVIDE R-20 CAVITY WALL INSULATION. IF SPRAY FOAM INSULATION IS SELECTED, USE AS REQUIRED FOR R-20 AND PROVIDE AIR GAP AT ENVELOPE IN ACCORDANCE WITH MANUFACTURER AND ENVELOPE INSPECTOR RECOMMENDATIONS. PROVIDE CONTINUOUS AIR/VAPOR BARRIER PER CODE AND MANUFACTURER REQUIREMENTS AND RECOMMENDATIONS.
2. ROOF INSULATION ABOVE ROOF DECK TO BE R-25 CONTINUOUS (MINIMUM).
3. ROOF MATERIAL TO HAVE MINIMUM 3-YEAR AGED SOLAR REFLECTANCE OF 0.55 AND MINIMUM 3-YEAR AGED THERMAL EMITTANCE OF 0.75.
4. PROVIDE CONTINUOUS AIR BARRIER SEALED PER MANUFACTURER INSTRUCTIONS AND SPECIFICATIONS.
5. ALL EXTERIOR GLAZING TO BE SHGC 0.25 COMPLIANT WITH ENERGY CODE REQUIREMENTS AND TEXAS DEPARTMENT OF INSURANCE REQUIREMENTS FOR SPECIFIC BUILDING LOCATION.
6. COMMISSIONING OF ALL MECHANICAL AND PLUMBING SYSTEMS SHALL BE PERFORMED BY LICENSED TESTING AGENT IN ACCORDANCE WITH MEP DRAWINGS AND ENERGY CODE REQUIREMENTS. PROVIDE THIRD PARTY ENERGY CODE CERTIFICATION OF ENVELOPE AND SYSTEMS PER REQUIREMENTS.

SPECIAL INSPECTIONS:

OWNER (DEVELOPER) AND GENERAL CONTRACTOR TO COORDINATE HIRING OF THIRD PARTY INSPECTOR PRIOR TO BIDDING AND CONSTRUCTION.

OWNER (DEVELOPER) AND/OR GENERAL CONTRACTOR TO COORDINATE SPECIAL INSPECTIONS AS REQUIRED BY IRC 2015 CHAPTER 17. SPECIAL INSPECTIONS SHALL BE PERFORMED FOR:


- BOLTS IN CONCRETE
- CONCRETE
- EIFS SYSTEMS (WHERE OCCUR)
- ELECTRICAL SERVICE ENTRANCE
- PLATE ANCHORS
- SHEAR WALLS AND BRACE WALL LINES
- SMOKE CONTROL SYSTEMS, FIRE STOPPING AND DRAFTSTOPS PER CODE REQUIREMENTS
- SPECIAL CASES (SIMPSON FASTENERS, ETC...)
- ENGINEERED JOISTS AND ROOF TRUSSES WITH REQUIRED BRACING
- STRUCTURAL MASONRY (WHERE OCCUR)
- WELDING
- SPECIAL GRADING, EXCAVATING AND FILLING (WHERE OCCUR)
- SPRAY-APPLIED FIRE PROOFING
- ADDITIONAL ITEMS PER STRUCTURAL DRAWINGS
- ANY OTHER ITEMS AS REQUIRED BY SECTION 17.

SPECIAL INSPECTIONS SHALL BE COMPLETED BY LICENSED INSPECTOR QUALIFIED TO PERFORM SAID INSPECTION.

INSPECTION REPORTS TO BE FILED WITH CITY BUILDING INSPECTIONS DEPARTMENT, ENGINEER/ARCHITECT, AND OWNER (DEVELOPER), TYPICAL. PROVIDE CERTIFICATION OF ENERGY CODE COMPLIANCE AS REQUIRED.

BUILDING CODE WORKSHEET

BUILDING CODES:	2015 INTERNATIONAL BUILDING CODE	HOMER2 SUITES - EL PASO, TEXAS
	2015 INTERNATIONAL PLUMBING CODE	
	2015 INTERNATIONAL MECHANICAL CODE	
	2015 INTERNATIONAL GAS CODE	
	2015 INTERNATIONAL ENERGY CODE	
	2015 INTERNATIONAL FIRE CODE	
	2014 NATIONAL ELECTRICAL CODE	
	2012 TEXAS ACCESSIBILITY STANDARDS	
AND APPLICABLE LOCAL AMMENDMENTS TO ALL OF THE ABOVE		
AUTOMATIC FIRE EXTINGUISHING SYSTEM: TYPE 13 SYSTEM		
AUTOMATIC FIRE ALARM SYSTEM		
FIRE ALARM AND FIRE SPRINKLER CONTRACTORS TO SUBMIT DRAWINGS TO CITY AND TO FRANCHISE FOR REVIEW AND APPROVAL FOR FIRE ALARM AND FIRE SPRINKLER SYSTEM PRIOR TO INSTALLATION.		
CODE SUMMARY:		
CONSTRUCTION TYPE:	VA	
OCCUPANCY:	R-1	
ALLOWABLE NUMBER OF STORIES (TABLE 504.4):		ALLOWED HEIGHT & S.F.
REFERENCE BELOW		4
ALLOWABLE SQUARE FOOTAGE (TABLE 506.2):		TOTAL
36,000		144,000
4 STORIES		65,386
Automatic sprinkler system increase: For Group R buildings equipped throughout with an approved automatic sprinkler system in accordance with Section 903.3.1.1, the value specified in Table 504.4 for maximum number of stories is increased by one, but shall not exceed four stories, respectively.		
SQUARE FOOTAGES:		
FIRST FLOOR:	16,409 S.F.	
SECOND FLOOR:	16,417 S.F.	
THIRD FLOOR:	16,280 S.F.	
FOURTH FLOOR:	16,280 S.F.	
65,386 S.F.		

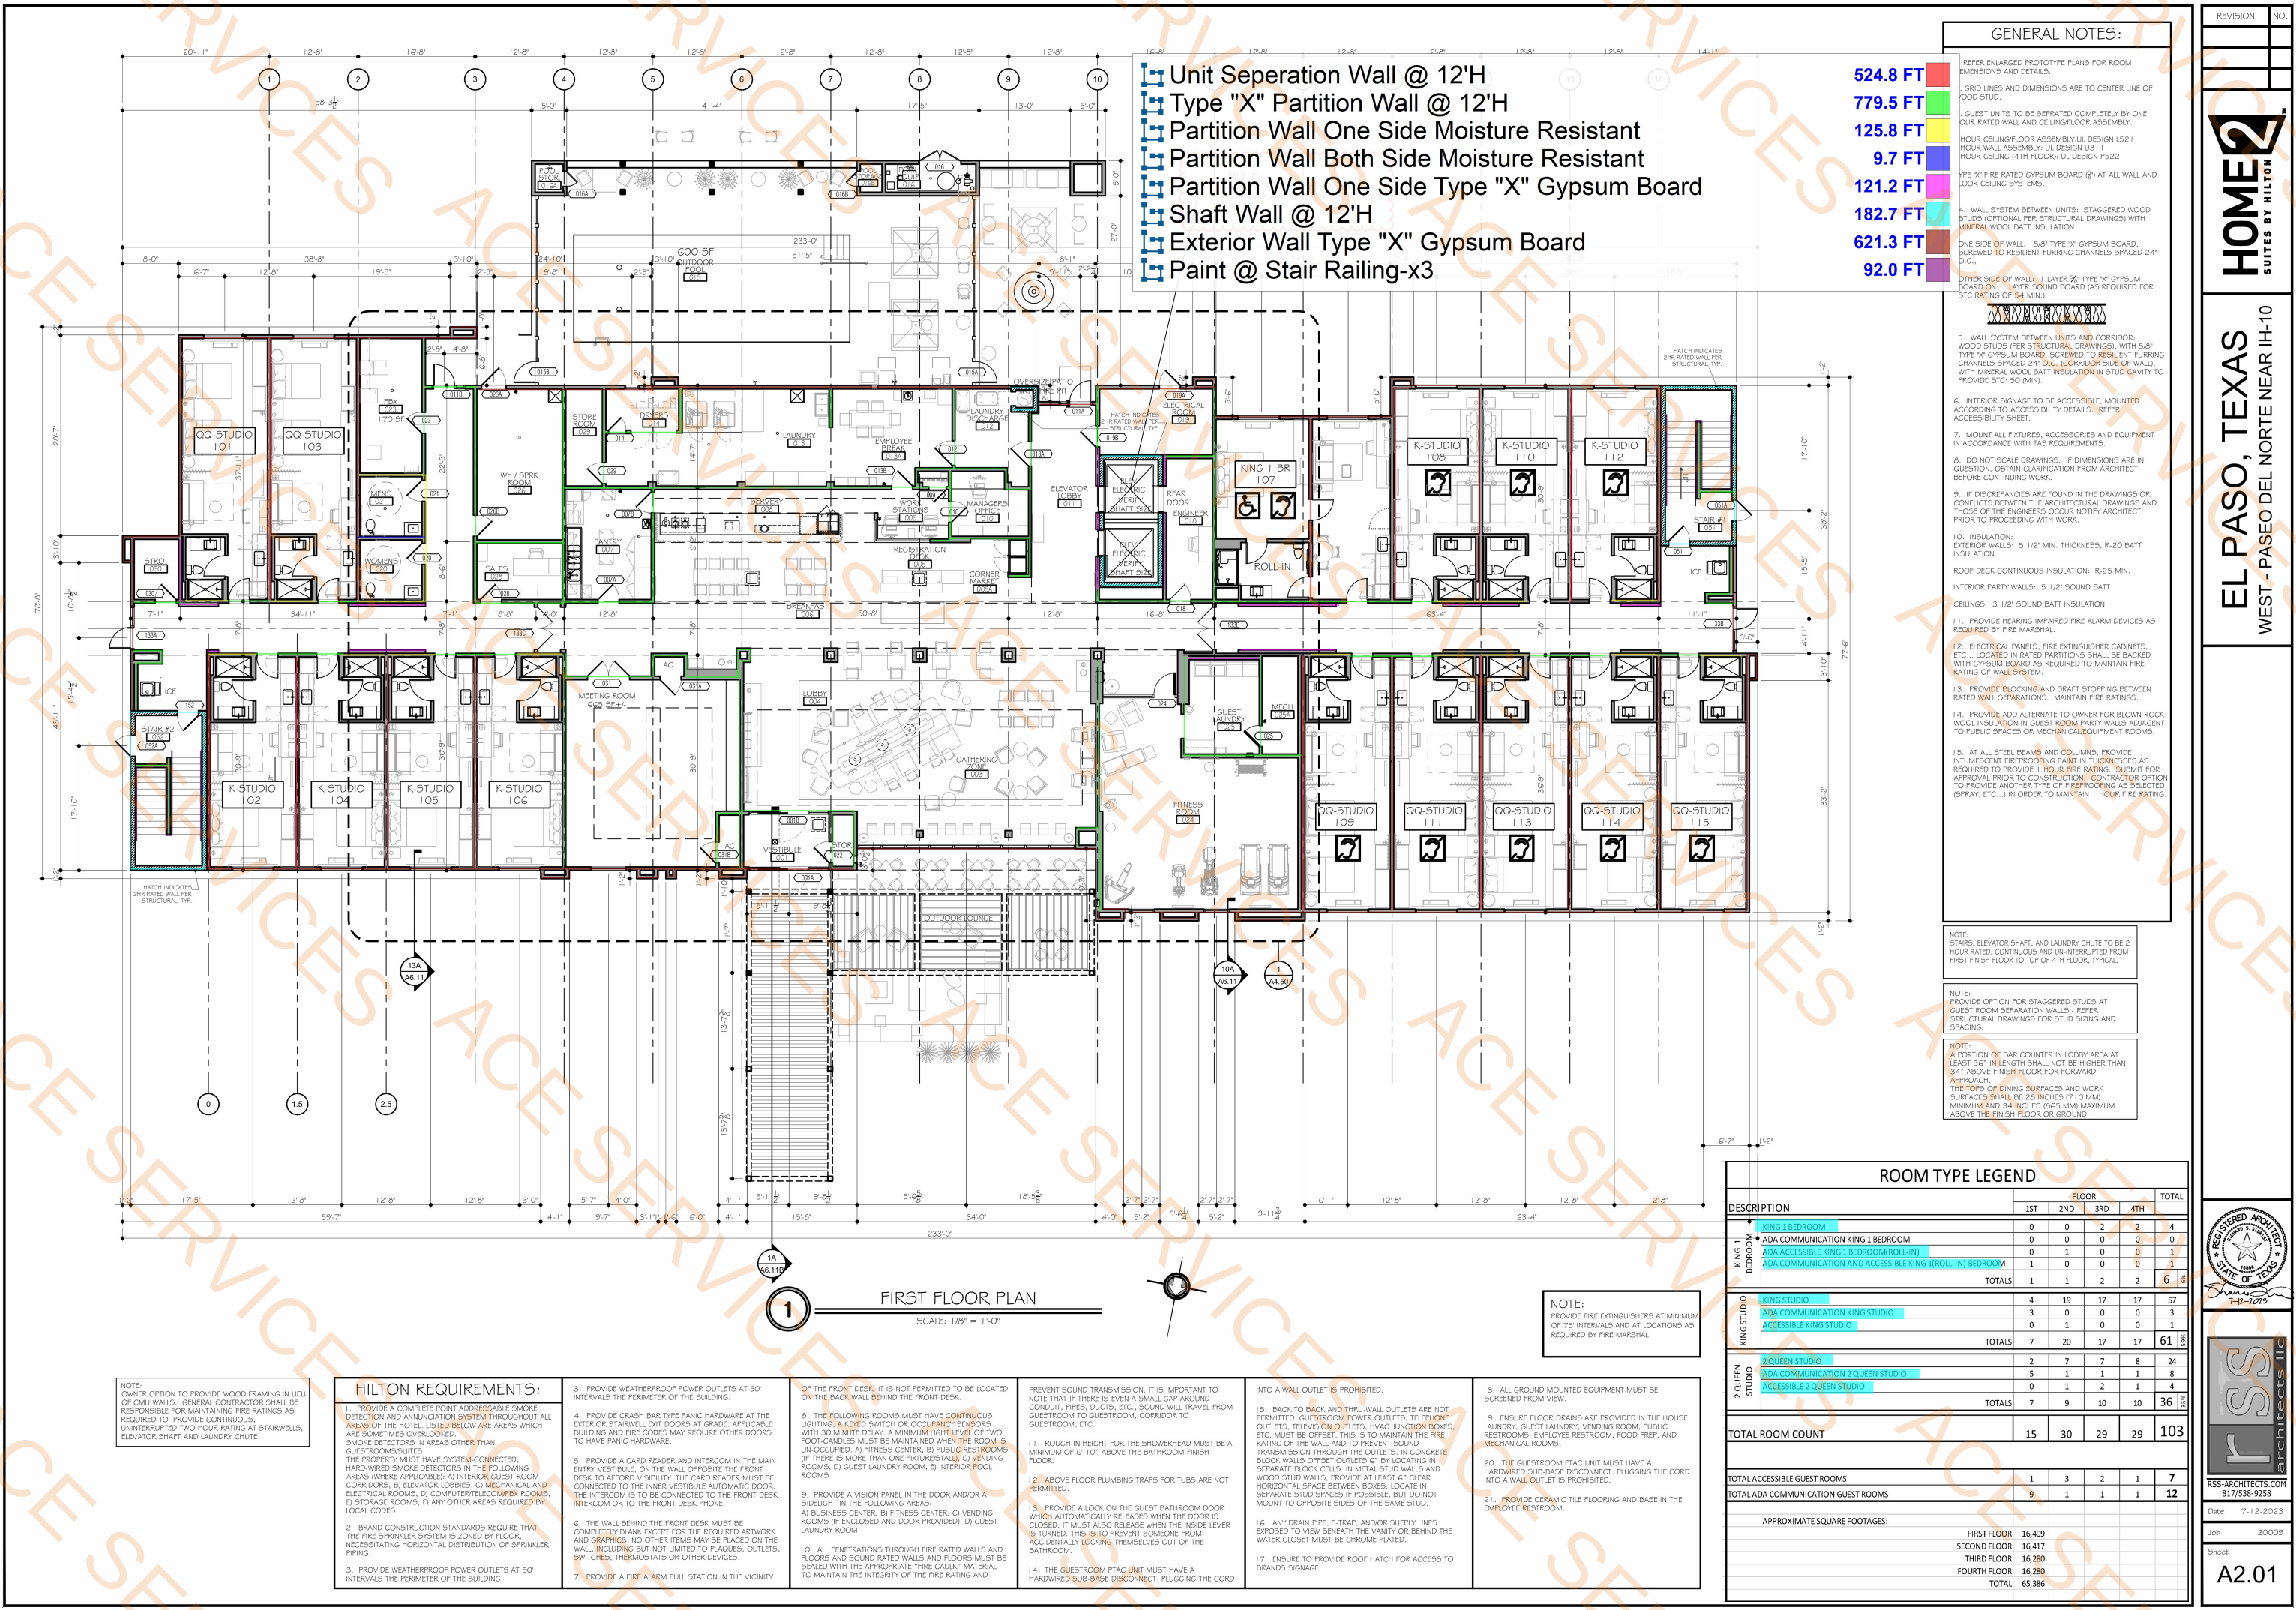

- Unit Separation Wall @ 12'H
- Type "X" Partition Wall @ 12'H
- Partition Wall One Side Moisture Resistant
- Partition Wall Both Side Moisture Resistant
- Partition Wall One Side Type "X" Gypsum Board
- Shaft Wall @ 12'H
- Exterior Wall Type "X" Gypsum Board
- Paint @ Stair Railing-x3

- 524.8 FT
- 779.5 FT
- 125.8 FT
- 9.7 FT
- 121.2 FT
- 182.7 FT
- 621.3 FT
- 92.0 FT

- GENERAL NOTES:
- REFER ENLARGED PROTOTYPE PLANS FOR ROOM DIMENSIONS AND DETAILS.
 - GRID LINES AND DIMENSIONS ARE TO CENTER LINE OF GRID STUD.
 - GUEST UNITS TO BE SEPARATED COMPLETELY BY ONE HOUR RATED WALL AND CEILING/FLOOR ASSEMBLY.
 - HOUR CEILING/FLOOR ASSEMBLY: UL DESIGN L521
 - HOUR WALL ASSEMBLY: UL DESIGN U311
 - HOUR CEILING (4TH FLOOR): UL DESIGN F522
 - TYPE "X" FIRE RATED GYPSUM BOARD (5/8") AT ALL WALL AND FLOOR CEILING SYSTEMS.
 - WALL SYSTEM BETWEEN UNITS: STAGGERED WOOD STUDS (OPTIONAL PER STRUCTURAL DRAWINGS) WITH 5/8" TYPE "X" GYPSUM BOARD, SCREWED TO RESILIENT FURRING CHANNELS 5" SPACED 24" O.C. (CORRIDOR SIDE OF WALL), WITH MINERAL WOOL BATT INSULATION IN STUD CAVITY TO PROVIDE STC 50 (MIN).
 - WALL SYSTEM BETWEEN UNITS AND CORRIDOR: WOOD STUDS (PER STRUCTURAL DRAWINGS), WITH 5/8" TYPE "X" GYPSUM BOARD, SCREWED TO RESILIENT FURRING CHANNELS 5" SPACED 24" O.C. (CORRIDOR SIDE OF WALL), WITH MINERAL WOOL BATT INSULATION IN STUD CAVITY TO PROVIDE STC 50 (MIN).
 - INTERIOR SIGNAGE TO BE ACCESSIBLE, MOUNTED ACCORDING TO ACCESSIBILITY DETAILS. REFER ACCESSIBILITY SHEET.
 - MOUNT ALL FIXTURES, ACCESSORIES AND EQUIPMENT IN ACCORDANCE WITH T&S REQUIREMENTS.
 - DO NOT SCALE DRAWINGS. IF DIMENSIONS ARE IN QUESTION, OBTAIN CLARIFICATION FROM ARCHITECT BEFORE CONTINUING WORK.
 - IF DISCREPANCIES ARE FOUND IN THE DRAWINGS OR CONFLICTS BETWEEN THE ARCHITECTURAL DRAWINGS AND THOSE OF THE ENGINEERS OCCUR NOTIFY ARCHITECT PRIOR TO PROCEEDING WITH WORK.
 - INSULATION: EXTERIOR WALLS: 5 1/2" MIN. THICKNESS, R-20 BATT INSULATION. ROOF DECK CONTINUOUS INSULATION: R-25 MIN. INTERIOR PARTY WALLS: 5 1/2" SOUND BATT CEILING: 3 1/2" SOUND BATT INSULATION.
 - PROVIDE HEARING IMPAIRED FIRE ALARM DEVICES AS REQUIRED BY FIRE MARSHAL.
 - ELECTRICAL PANELS, FIRE EXTINGUISHER CABINETS, ETC., LOCATED IN RATED PARTITIONS SHALL BE BACKED WITH GYPSUM BOARD AS REQUIRED TO MAINTAIN FIRE RATING OF WALL SYSTEM.
 - PROVIDE BLOCKING AND DRAFT STOPPING BETWEEN RATED WALL SEPARATIONS. MAINTAIN FIRE RATINGS.
 - PROVIDE ADD ALTERNATE TO OWNER FOR BLOWN ROCK WOOL INSULATION IN GUEST ROOM PARTY WALLS ADJACENT TO PUBLIC SPACES OR MECHANICAL/EQUIPMENT ROOMS.
 - AT ALL STEEL BEAMS AND COLUMNS, PROVIDE INTUMESCENT FIREPROOFING PAINT IN THICKNESSES AS REQUIRED TO PROVIDE 1 HOUR FIRE RATING. SUBMIT FOR APPROVAL PRIOR TO CONSTRUCTION. CONTRACTOR OPTION TO PROVIDE ANOTHER TYPE OF FIREPROOFING AS SELECTED (SPRAY, ETC...) IN ORDER TO MAINTAIN 1 HOUR FIRE RATING.
- NOTE: STAIRS, ELEVATOR SHAFT, AND LAUNDRY CHUTE TO BE 2 HOUR RATED, CONTINUOUS AND UN-INTERRUPTED FROM FIRST FINISH FLOOR TO TOP OF 4TH FLOOR, TYPICAL.
- NOTE: PROVIDE OPTION FOR STAGGERED STUDS AT GUEST ROOM SEPARATION WALLS - REFER STRUCTURAL DRAWINGS FOR STUD SIZING AND SPACING.
- NOTE: A PORTION OF BAR COUNTER IN LOBBY AREA AT LEAST 36" IN LENGTH SHALL NOT BE HIGHER THAN 34" ABOVE FINISH FLOOR FOR FORWARD APPROACH. THE TOPS OF DINING SURFACES AND WORK SURFACES SHALL BE 28 INCHES (710 MM) MINIMUM AND 34 INCHES (865 MM) MAXIMUM ABOVE THE FINISH FLOOR OR GROUND.

ROOM TYPE LEGEND					
DESCRIPTION	FLOOR				TOTAL
	1ST	2ND	3RD	4TH	
KING 1 BEDROOM	0	0	2	2	4
	ADA COMMUNICATION KING 1 BEDROOM	0	0	0	0
	ADA ACCESSIBLE KING 1 BEDROOM (ROLL-IN)	0	1	0	1
	ADA COMMUNICATION AND ACCESSIBLE KING 1 (ROLL-IN) BEDROOM	1	0	0	1
TOTALS	1	1	2	2	6
KING STUDIO	4	19	17	17	57
	ADA COMMUNICATION KING STUDIO	3	0	0	3
	ADA ACCESSIBLE KING STUDIO	0	1	0	1
	TOTALS	7	20	17	61
2 QUEEN STUDIO	2	7	7	8	24
	ADA COMMUNICATION 2 QUEEN STUDIO	5	1	1	8
	ADA ACCESSIBLE 2 QUEEN STUDIO	0	1	2	4
	TOTALS	7	9	10	36
TOTAL ROOM COUNT					
TOTAL ACCESSIBLE GUEST ROOMS					
TOTAL ADA COMMUNICATION GUEST ROOMS					
APPROXIMATE SQUARE FOOTAGES:					
FIRST FLOOR: 16,409					
SECOND FLOOR: 16,417					
THIRD FLOOR: 16,380					
FOURTH FLOOR: 16,280					
TOTAL: 65,386					

HILTON REQUIREMENTS:

- PROVIDE A COMPLETE POINT ADDRESSABLE SMOKE DETECTION AND ANNUNCIATION SYSTEM THROUGHOUT ALL AREAS OF THE HOTEL LISTED BELOW ARE AREAS WHICH ARE SOMETIMES OVERLOOKED. SMOKE DETECTORS IN AREAS OTHER THAN GUESTROOMS/SUITES THE PROPERTY MUST HAVE SYSTEM-CONNECTED, HARD-WIRED SMOKE DETECTORS IN THE FOLLOWING AREAS (WHERE APPLICABLE): A) INTERIOR GUEST ROOM CORRIDORS, B) ELEVATOR LOBBIES, C) MECHANICAL AND ELECTRICAL ROOMS, D) COMPUTER/TELECOM/REB ROOMS, E) STORAGE ROOMS, F) ANY OTHER AREAS REQUIRED BY LOCAL CODES.
- BRAND CONSTRUCTION STANDARDS REQUIRE THAT THE FIRE SPRINKLER SYSTEM IS ZONED BY FLOOR, NECESSITATING HORIZONTAL DISTRIBUTION OF SPRINKLER PIPING.
- PROVIDE WEATHERPROOF POWER OUTLETS AT 50' INTERVALS THE PERIMETER OF THE BUILDING.
- PROVIDE CRASH BAR TYPE PANIC HARDWARE AT THE EXTERIOR STAIRWELL EXIT DOORS AT GRADE. APPLICABLE BUILDING AND FIRE CODES MAY REQUIRE OTHER DOORS TO HAVE PANIC HARDWARE.
- PROVIDE A CARD READER AND INTERCOM IN THE MAIN ENTRY VESTIBULE, ON THE WALL OPPOSITE THE FRONT DESK TO AFFORD VISIBILITY. THE CARD READER MUST BE CONNECTED TO THE INNER VESTIBULE AUTOMATIC DOOR. THE INTERCOM IS TO BE CONNECTED TO THE FRONT DESK INTERCOM OR TO THE FRONT DESK PHONE.
- THE WALL BEHIND THE FRONT DESK MUST BE COMPLETELY BLANK EXCEPT FOR THE REQUIRED ARTWORK AND GRAPHICS. NO OTHER ITEMS MAY BE PLACED ON THE WALL, INCLUDING BUT NOT LIMITED TO PLAQUES, OUTLETS, SWITCHES, THERMOSTATS OR OTHER DEVICES.
- PROVIDE A FIRE ALARM PULL STATION IN THE VICINITY

- OF THE FRONT DESK, IT IS NOT PERMITTED TO BE LOCATED ON THE BACK WALL BEHIND THE FRONT DESK.
- THE FOLLOWING ROOMS MUST HAVE CONTINUOUS LIGHTING: A) KEYED SWITCH OR OCCUPANCY SENSORS WITH 30 MINUTE DELAY. A MINIMUM LIGHT LEVEL OF TWO FOOT CANDLES MUST BE MAINTAINED WHEN THE ROOM IS UNOCCUPIED. A) FITNESS CENTER, B) PUBLIC RESTROOMS IF THERE IS MORE THAN ONE FIXTURE/STALL, C) VENDING ROOMS, D) GUEST LAUNDRY ROOM, E) INTERIOR POOL.
- PROVIDE A VISION PANEL IN THE DOOR AND/OR A SIDELIGHT IN THE FOLLOWING AREAS: A) BUSINESS CENTER, B) FITNESS CENTER, C) VENDING ROOMS IF ENCLOSED AND DOOR PROVIDED, D) GUEST LAUNDRY ROOM.
- ALL PENETRATIONS THROUGH FIRE RATED WALLS AND FLOORS AND SOUND RATED WALLS AND FLOORS MUST BE SEALED WITH THE APPROPRIATE "FIRE CAULK" MATERIAL TO MAINTAIN THE INTEGRITY OF THE FIRE RATING AND

- PREVENT SOUND TRANSMISSION, IT IS IMPORTANT TO NOTE THAT IF THERE IS EVEN A SMALL GAP AROUND CONDUIT, PIPES, DUCTS, ETC., SOUND WILL TRAVEL FROM GUESTROOM TO GUESTROOM, CORRIDOR TO GUESTROOM, ETC.
- ROUGH-IN HEIGHT FOR THE SHOWERHEAD MUST BE A MINIMUM OF 6'-10" ABOVE THE BATHROOM FINISH FLOOR.
- ABOVE FLOOR PLUMBING TRAPS FOR TUBS ARE NOT PERMITTED.
- PROVIDE A LOCK ON THE GUEST BATHROOM DOOR WHICH AUTOMATICALLY RELEASES WHEN THE DOOR IS CLOSED. IT MUST ALSO RELEASE WHEN THE INSIDE LEVER IS TURNED. THIS IS TO PREVENT SOMEONE FROM ACCIDENTALLY LOCKING THEMSELVES OUT OF THE BATHROOM.
- THE GUESTROOM PTAC UNIT MUST HAVE A HARDWIRED SUB-BASE DISCONNECT, PLUGGING THE CORD INTO A WALL OUTLET IS PROHIBITED.
- BACK TO BACK AND THRU-WALL OUTLETS ARE NOT PERMITTED. GUESTROOM POWER OUTLETS, TELEPHONE OUTLETS, TELEVISION OUTLETS, HVAC JUNCTION BOXES, ETC. MUST BE OFFSET. THIS IS TO MAINTAIN THE FIRE RATING OF THE WALL AND TO PREVENT SOUND TRANSMISSION THROUGH THE OUTLETS. IN CONCRETE BLOCK WALLS OFFSET OUTLETS 6" BY LOCATING IN SEPARATE BLOCK CELLS. IN METAL STUD WALLS AND WOOD STUD WALLS, PROVIDE AT LEAST 6" CLEAR HORIZONTAL SPACE BETWEEN BOXES. LOCATE IN SEPARATE STUD SPACES IF POSSIBLE, BUT DO NOT MOUNT TO OPPOSITE SIDES OF THE SAME STUD.
- ANY DRAIN PIPE, F-TRAP, AND/OR SUPPLY LINES EXPOSED TO VIEW BENEATH THE VANITY OR BEHIND THE WATER CLOSET MUST BE CHROME PLATED.
- ENSURE TO PROVIDE ROOF HATCH FOR ACCESS TO BRANDS SIGNAGE.


- ALL GROUND MOUNTED EQUIPMENT MUST BE SCREENED FROM VIEW.
- ENSURE FLOOR DRAINS ARE PROVIDED IN THE HOUSE LAUNDRY, GUEST LAUNDRY, VENDING ROOM, PUBLIC RESTROOMS, EMPLOYEE RESTROOM, FOOD PREP, AND MECHANICAL ROOMS.
- THE GUESTROOM PTAC UNIT MUST HAVE A HARDWIRED SUB-BASE DISCONNECT, PLUGGING THE CORD INTO A WALL OUTLET IS PROHIBITED.
- PROVIDE CERAMIC TILE FLOORING AND BASE IN THE EMPLOYEE RESTROOM.



- Unit Separation Wall @ 9'H
- Shaft Wall @ 9'H
- Partition Wall One Side Moisture Resistant @ 9'H
- Type "X" Partition Wall @ 9'H
- One Side Type "X" Gypsum Board Wall
- Exterior Wall Type "X" Gypsum Board @ 9'H

1 SECOND FLOOR PLAN
SCALE: 1/8" = 1'-0"

REVISION	NO.
EL PASO, TEXAS WEST - PASEO DEL NORTE NEAR IH-10	
RSS-ARCHITECTS.COM 817/538-9238	
Date: 11-10-2022	
Job: 20009	
Sheet:	
A2.02	

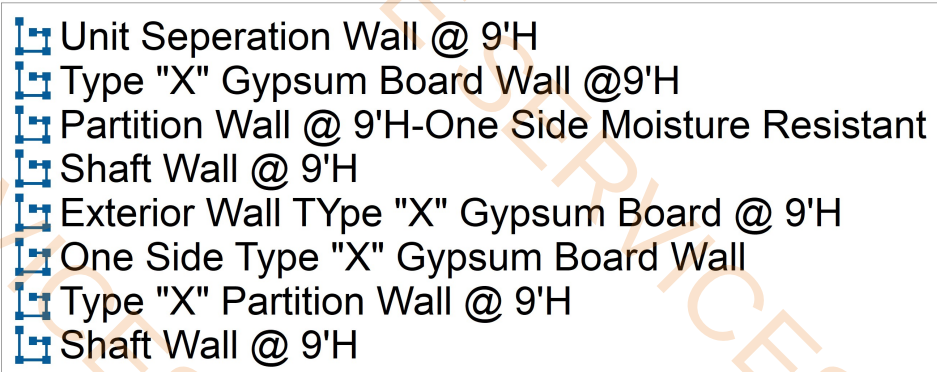


908.3 FT	
367.2 FT	
204.8 FT	
176.1 FT	
631.9 FT	
215.1 FT	
87.0 FT	
10.9 FT	



REVISION		NO.	
		EL PASO, TEXAS WEST - PASEO DEL NORTE NEAR IH-10	
			
			
RSS-ARCHITECTS.COM 817/538-9258			
Date	7-12-2023		
Job	20009		
Sheet	A2.04		

5/8" Type "X" Gypsum Board Ceiling-PT07
Paint @ Exposed Structure

171.7 SQ FT
357.9 SQ FT

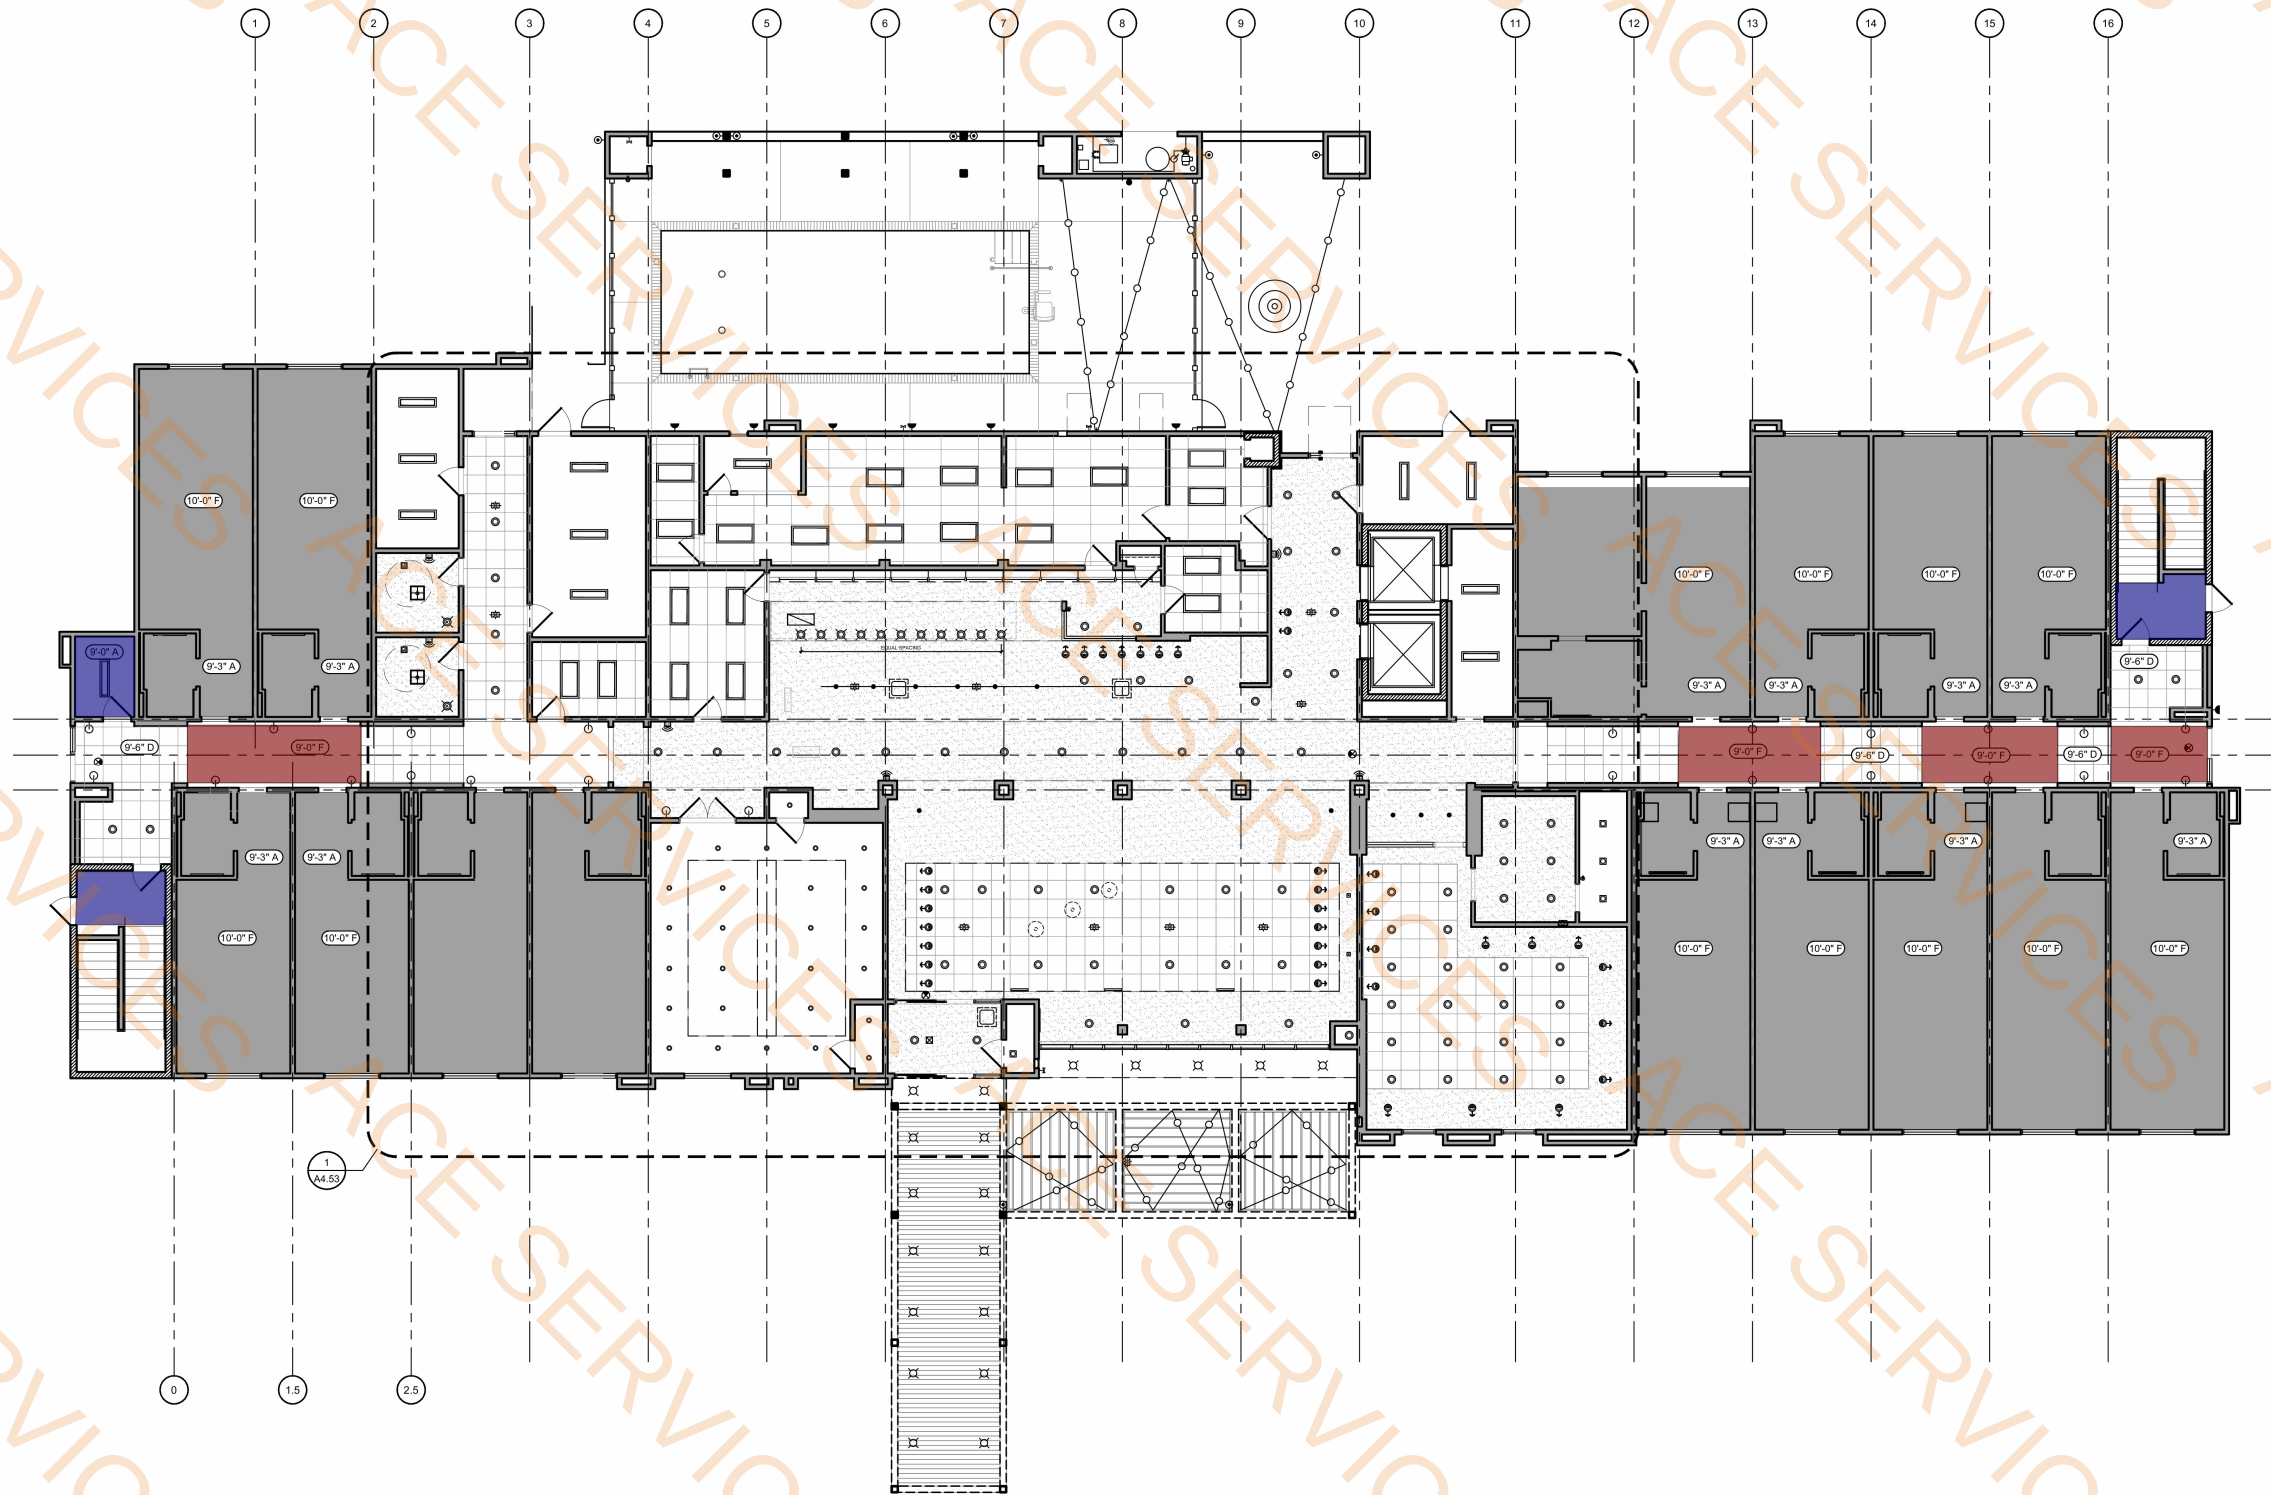

1 FIRST FLOOR RCP
SCALE: 1/8" = 1'-0"

- KEY NOTES:
- GYP. BD. VEE REVEAL
 - LAUNDRY CHUTE - SHAFT OPEN TO VENT AT ROOF
 - CORNICHE BEYOND
 - ALUMINUM ACCENT BAND/TUBE - REFER TO ELEVATIONS
 - EXTERIOR SCIENCE(S) - REFER TO FIXTURE LEGEND & ELEVATIONS FOR PLACEMENT & QUANTITY
 - FLUSH ACCESS PANEL W/ DROP IN DOOR - MFR. ISC STYLEMARK No. 8 CAP-1818 - CONFIRM SIZE WITH ENGINEER OF RECORD - TEXTURE & PAINT TO MATCH ADJ. CEILING
 - REFER TO ELEVATIONS FOR SCIENCE PLACEMENT DESIGN INTENT
 - OPEN-AIR TRELLIS
 - T&G WOOD DECKING AT UNDERSIDE OF COVERED CANOPY - REFER TO STYLE GUIDE FOR FINISH REQUIREMENTS

XXX FURNISHINGS LEGEND:
PA-204 WALL SCIENCE

- CEILING LEGEND:
- 6'-0" CEILING HEIGHT
6'-0" CEILING FINISH
- A. PRIME & PAINTED GYPSUM BOARD
 - B. PRIME & PAINTED GYPSUM BOARD - MOISTURE RESISTANT
 - C. OPEN TO UNDERSIDE OF FLOOR / ROOF SYSTEM ABOVE - PAINT ALL ELEMENTS - ELEVATION INDICATED MAY BE "APPROXIMATE" & FOR GENERAL REFERENCE ONLY - REFER TO SECTIONS
 - D. 2X2 LAY-IN ACOUSTICAL CLG. TILE SUSPENDED FROM STRUCT.
 - E. 2X4 LAY-IN CLG. GRID SYSTEM SUSPENDED FROM STRUCT. - INFILLED W/ 1/2" VINYL FACED GYPSUM BOARD PANELS
 - F. UNDERSIDE OF FLOOR / ROOF SYSTEM - PRIME & PAINTED TO RECEIVE FINAL FINISH
- NOTE: PROVIDE 5/8" TYPE "X" GYPSUM BOARD ON R/C CHANNELS ABOVE ALL TURNED OR DROPPED CEILING AT THE TRUSSES AS REQUIRED TO MAINTAIN FIRE RATING, TYPICAL.

- CEILING - FIXTURE LEGEND: SYMBOLS ARE NOT TO SCALE
- DECORATIVE WALL SCIENCE - REFER TO FF&E PACKAGE
 - DECORATIVE ROUND SUSPENDED LIGHT FIXTURE - REFER TO FF&E PACKAGE
 - DECORATIVE SQUARE SURFACE MOUNT LIGHT FIXTURE - REFER TO FF&E PACKAGE
 - DECORATIVE SUSPENDED LIGHT FIXTURE - REFER TO FF&E PACKAGE
 - (R-1) RECESSED DOWNLIGHT
 - (R-2) RECESSED WALL WASH
 - (R-3) RECESSED DOWNLIGHT W/ LENS (FLUORESCENT LAMP - UL LABEL)
 - (R-4) SMALL RECESSED DOWNLIGHT (HALOGEN LAMP) NARROW BEAM SPREAD
 - (R-6) SURFACE MOUNTED FIXTURE
 - (R-7) EXT. RECESSED DOWNLIGHT WALL WASHER - (UL WET LABEL)
 - (T-1) 2X2 LAY-IN FLUORESCENT FIXTURE
 - (T-2) 2X4 LAY-IN FLUOR. FIXTURE
 - (T-3) 1X4 SURFACE MOUNTED FLUORESCENT FIXTURE
 - (C-1) RECESSED FLUORESCENT COVE FIXTURE - 4FT
 - (W-1) WALL MOUNTED STRIP LIGHT - 4FT
 - (S-1) WALL SCIENCE @ POOL AREA (UL WET LABEL)
 - (S-2) WALL SCIENCE @ REAR ENTRY (UL WET LABEL)
 - (S-3) EXTERIOR SCIENCE (UPLIGHT)
 - (S-5) EXTERIOR FLOODLIGHT
 - (G-1) EXTERIOR HEAVY DUTY LIGHT STRING
 - SPEAKER
 - MECHANICAL EXHAUST GRILLE
 - 2X2 MECHANICAL RETURN GRILLE
 - 2X2 MECHANICAL SUPPLY GRILLE
 - MECHANICAL SUPPLY GRILLE
 - MECHANICAL RETURN GRILLE
 - SMOKE DETECTOR
 - SPRINKLER HEAD
 - SIDE WALL SPRINKLER HEAD
 - VEE CONTROL JOINT
 - (P-3) IN-GROUND UPLIGHT
 - FIRE HORN/STROBE
 - * PROVIDE EMERGENCY LIGHTING AS REQUIRED BY LOCAL CODE

- GENERAL NOTES:
- REFER TO FF&E PACKAGE FOR FURNITURE, BUILT-IN MILLWORK AND FINISH SPECIFICATIONS
 - FIRE EXTINGUISHERS, SMOKE DETECTORS AND OTHER EMERGENCY DEVICES TO BE LOCATED PER LOCAL CODE. EXTINGUISHER LOCATIONS WITHIN THE PUBLIC SPACE SHALL BE CONTAINED WITHIN FULLY RECESSED CABINETS, RATED WHERE REQUIRED.
 - PROVIDE EMERGENCY LIGHTING PER LOCAL CODE.
 - CENTER LINE OF WALL DEVICES TO BE MOUNTED AT 12" A.F.F. TYPICAL U.N.O.
 - REFER TO HOME 2 SUITES BY HILTON STANDARDS MANUAL FOR ADDITION GUESTROOM, GUESTROOM BATH, GUESTROOM KITCHEN AND INDOOR POOL REQUIREMENTS.
 - SPRINKLER HEADS ARE SHOWN FOR DESIGN INTENT & REFERENCE ONLY. LOCAL DESIGN/ENGINEERS WILL NEED TO MODIFY ACCORDINGLY. SPRINKLER HEADS IN CEILINGS IN PUBLIC AREAS TO BE CONCEALED. ALL OTHER HEADS TO BE SEMI-RECESSED.
 - ANY PORTION OF A WALL SCIENCE OR OTHER OBJECT THAT PROTRUDES INTO THE CIRCULATION PATH ABOVE 27" A.F.F. AND BELOW 80" A.F.F. IS LIMITED TO A 4" MAXIMUM PROJECTION.

- KEY NOTES:
- GYP. BD. "VEE" REVEAL
 - LAUNDRY CHUTE - SHAFT OPEN TO VENT AT ROOF
 - CORNICHE BEYOND
 - ALUMINUM ACCENT BAND/TUBE - REFER TO ELEVATIONS FOR PLACEMENT & QUANTITY
 - EXTERIOR SCOFFS(S) - REFER TO FIXTURE LEGEND & ELEVATIONS FOR PLACEMENT & QUANTITY
 - FLUSH ACCESS PANEL W/ DROP IN DOOR - MFR. ISC STYLEMARK M6.8 CAP-1818 - CONFIRM SIZE WITH ENGINEER OF RECORD - TEXTURE & PAINT TO MATCH ADJ. CEILING
 - REFER TO ELEVATIONS FOR SCOFF PLACEMENT DESIGN INTENT
 - OPEN-AIR TRELLIS
 - T&G WOOD DECKING AT UNDERSIDE OF COVERED CANOPY - REFER TO STYLE GUIDE FOR FINISH REQUIREMENTS

FURNISHINGS LEGEND:

PA-204 WALL SCOFF

CEILING LEGEND:

- CEILING HEIGHT
- CEILING FINISH
- A. PRIME & PAINTED GYPSUM BOARD
 - B. PRIME & PAINTED GYPSUM BOARD - MOISTURE RESISTANT
 - C. OPEN TO UNDERSIDE OF FLOOR / ROOF SYSTEM ABOVE - PAINT ALL ELEMENTS - ELEVATION INDICATED MAY BE "APPROXIMATE" & FOR GENERAL REFERENCE ONLY - REFER TO SECTIONS
 - D. 2X2 LAY-IN ACOUSTICAL CLG. TILE SUSPENDED FROM STRUCT.
 - E. 2X4 LAY-IN CLG. GRID SYSTEM SUSPENDED FROM STRUCT. - FILLED W/ 1/2" VINYL FACED GYPSUM BOARD PANELS
 - F. UNDERSIDE OF FLOOR / ROOF SYSTEM - PRIME & PAINTED TO RECEIVE FINAL FINISH
- NOTE: PROVIDE 5/8" TYPE "X" GYPSUM BOARD ON RC CHANNELS ABOVE ALL FLURRED OR DROPPED CEILINGS AT THE TRUSSES AS REQUIRED TO MAINTAIN FIRE RATING, TYPICAL.

CEILING - FIXTURE LEGEND: SYMBOLS ARE NOT TO SCALE

- DECORATIVE WALL SCOFF - REFER TO FF&E PACKAGE
- DECORATIVE ROUND SUSPENDED LIGHT FIXTURE - REFER TO FF&E PACKAGE
- DECORATIVE SQUARE SURFACE MOUNT LIGHT FIXTURE - REFER TO FF&E PACKAGE
- DECORATIVE SUSPENDED LIGHT FIXTURE - REFER TO FF&E PACKAGE
- (R-1): RECESSED DOWNLIGHT
- (R-2): RECESSED WALL WASH
- (R-3): RECESSED DOWNLIGHT W/ LENS (FLUORESCENT LAMP) - UL WET LABEL
- (R-4): SMALL RECESSED DOWNLIGHT (HALOGEN LAMP) NARROW BEAM SPREAD
- (R-6): SURFACE MOUNTED FIXTURE
- (R-7): EXT. RECESSED DOWNLIGHT WALL WASHER - (UL WET LABEL)
- (T-1): 2X2 LAY-IN FLUORESCENT FIXTURE
- (T-2): 2X4 LAY-IN FLUOR. FIXTURE
- (T-3): 1X4 SURFACE MOUNTED FLUORESCENT FIXTURE
- (C-1): RECESSED FLUORESCENT COVE FIXTURE - 4FT
- (W-1): WALL MOUNTED STRIP LIGHT - 4FT
- (S-1): WALL SCOFF @ POOL AREA (UL WET LABEL)
- (S-2): WALL SCOFF @ REAR ENTRY (UL WET LABEL)
- (S-3): EXTERIOR SCOFF (UPLIGHT)
- (S-6): EXTERIOR FLOODLIGHT
- (G-1): EXTERIOR HEAVY DUTY LIGHT STRING
- SPEAKER
- MECHANICAL EXHAUST GRILLE
- 2X2 MECHANICAL RETURN GRILLE
- 2X2 MECHANICAL SUPPLY GRILLE
- MECHANICAL RETURN GRILLE
- MECHANICAL SUPPLY GRILLE
- SMOKE DETECTOR
- SPRINKLER HEAD
- SIDE WALL SPRINKLER HEAD
- "VEE" CONTROL JOINT
- (P-3) IN-GROUND UPLIGHT
- FIRE HORN/STROBE
- * PROVIDE EMERGENCY LIGHTING AS REQUIRED BY LOCAL CODE


GENERAL NOTES:

- REFER TO FF&E PACKAGE FOR FURNITURE, BUILT-IN MILLWORK AND FINISH SPECIFICATIONS
- FIRE EXTINGUISHERS, SMOKE DETECTORS AND OTHER EMERGENCY DEVICES TO BE LOCATED PER LOCAL CODE. EXTINGUISHER LOCATIONS WITHIN THE PUBLIC SPACE SHALL BE CONTAINED WITHIN FULLY RECESSED CABINETS, RATED WHERE REQUIRED.
- PROVIDE EMERGENCY LIGHTING PER LOCAL CODE.
- CENTER LINE OF WALL DEVICES TO BE MOUNTED AT 15" A.F.F. TYPICAL UNO.
- REFER TO HOME 2 SUITES BY HILTON STANDARDS MANUAL FOR ADDITION GUESTROOM, GUESTROOM BATH, GUESTROOM KITCHEN AND INDOOR POOL REQUIREMENTS
- SPRINKLER HEADS ARE SHOWN FOR DESIGN INTENT & REFERENCE ONLY. LOCAL DESIGNER/ENGINEER WILL NEED TO MODIFY ACCORDINGLY. SPRINKLER HEADS IN CEILING IN PUBLIC AREAS TO BE CONCEALED. ALL OTHER HEADS TO BE SEMI-RECESSED.
- ANY PORTION OF A WALL, SCOFF OR OTHER OBJECT THAT PROTRUDES INTO THE CIRCULATION PATH ABOVE 27" A.F.F. AND BELOW 80" A.F.F. IS LIMITED TO A 4" MAXIMUM PROJECTION.

- Paint @ Exposed Structure
- 5/8" Type "X" Gypsum Board Ceiling-PT07

1015.2 SQ FT

692.3 SQ FT

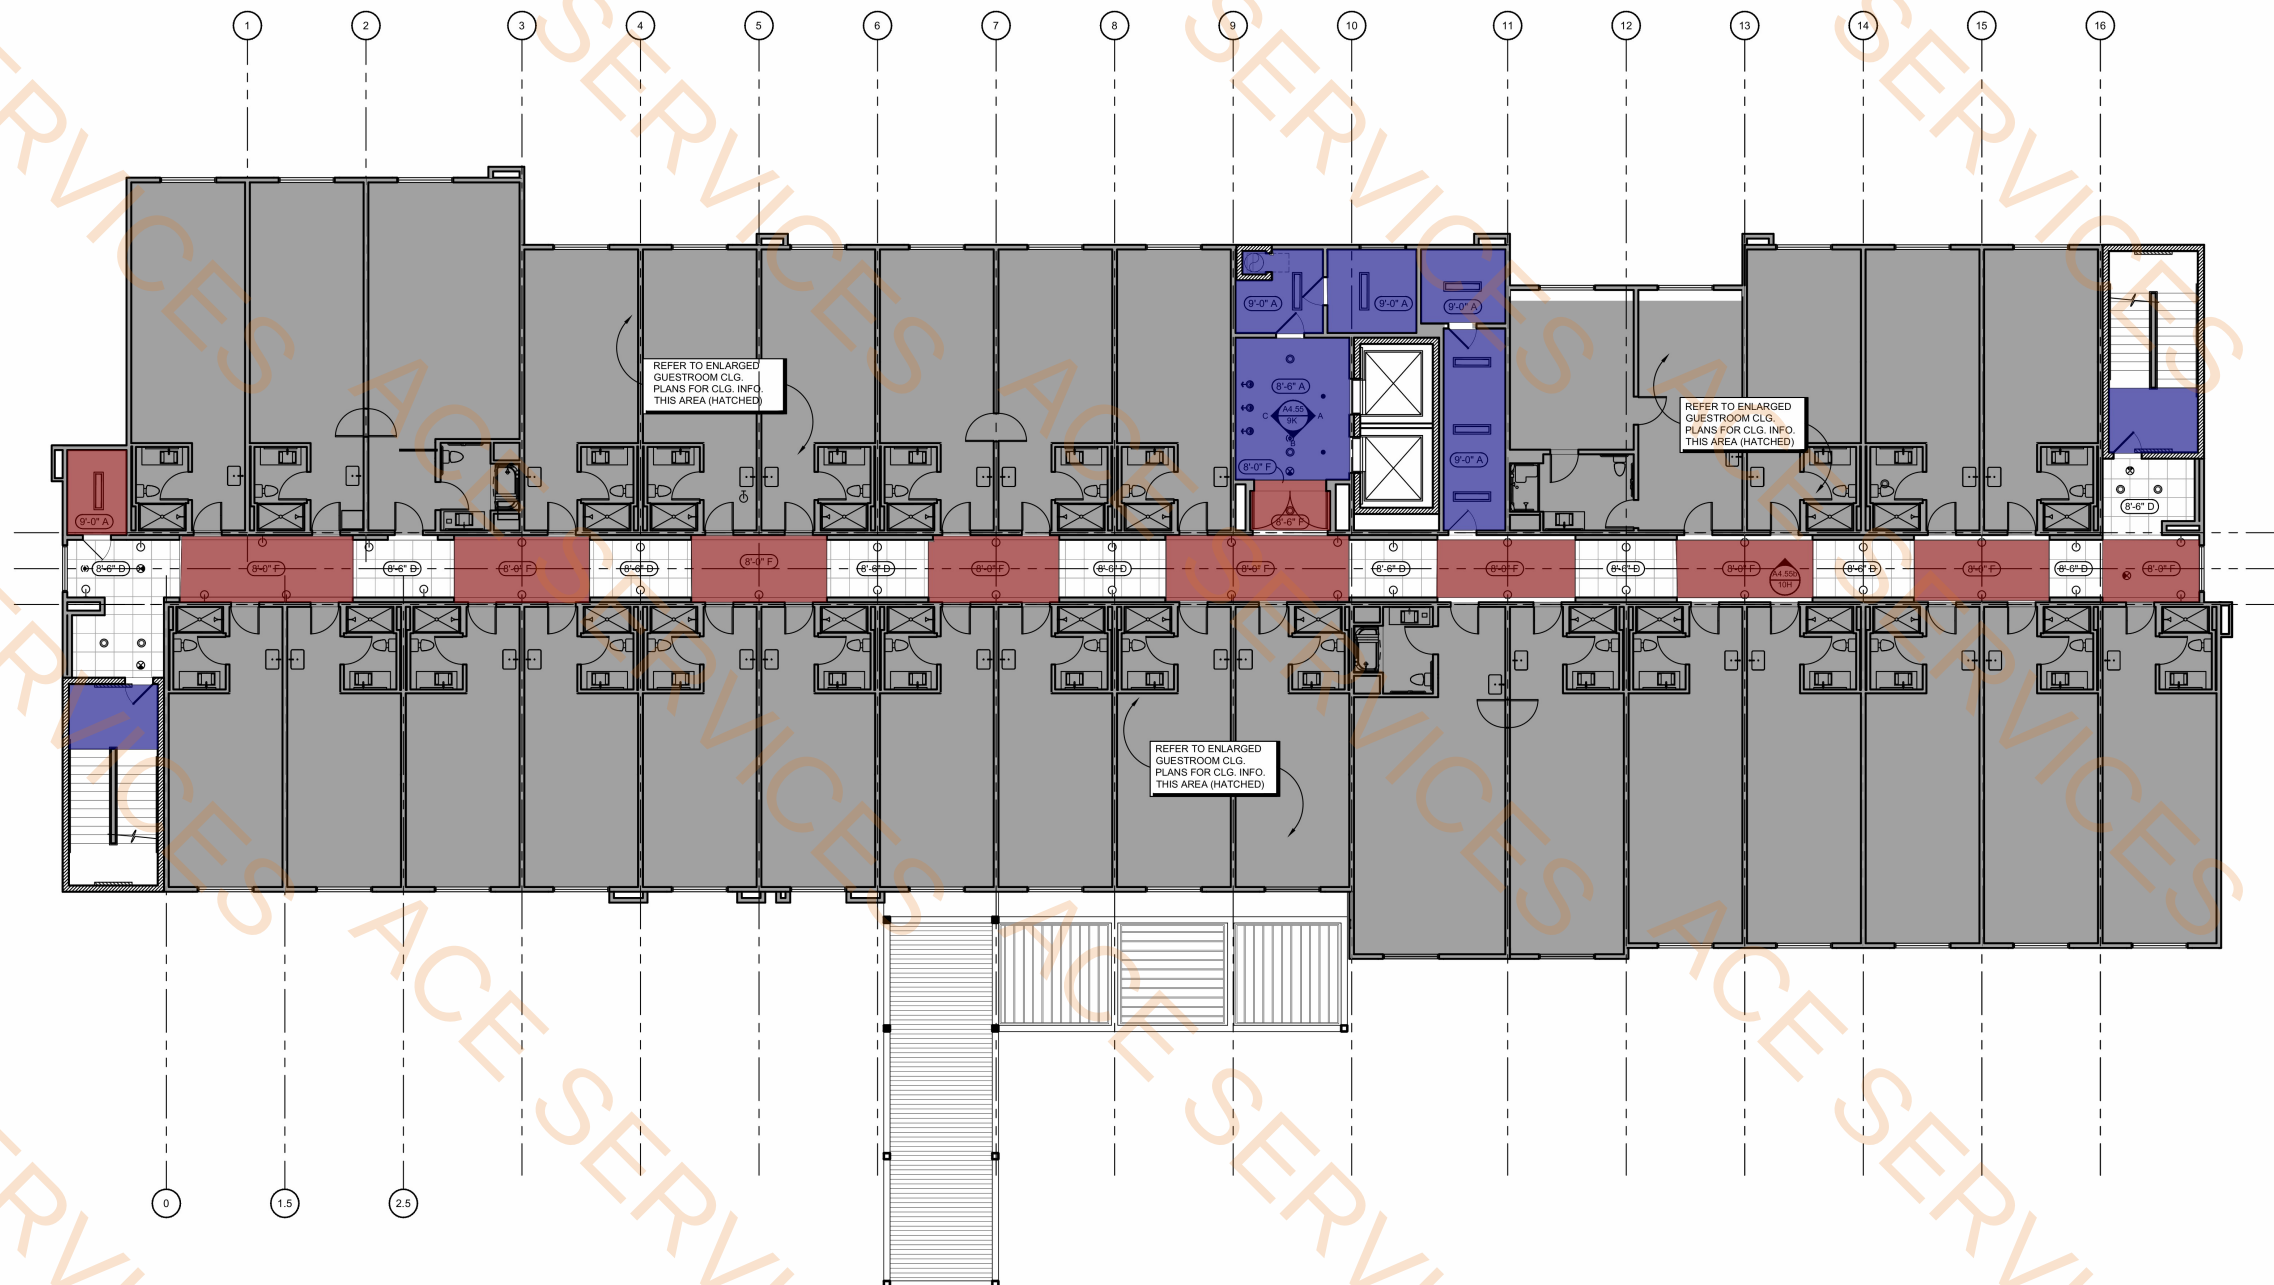

1 SECOND FLOOR RCP

SCALE: 1/8" = 1'-0"

- KEY NOTES:
- GYP. BD. 'VEE' REVEAL
 - LAUNDRY CHUTE - SHAFT OPEN TO VENT AT ROOF CORNICE BEYOND
 - ALUMINUM ACCENT BAND/ TUBE - REFER TO ELEVATIONS
 - EXTERIOR SCONCE(S) - REFER TO FIXTURE LEGEND & ELEVATIONS FOR PLACEMENT & QUANTITY
 - FLUSH ACCESS PANEL W/ DROP IN DOOR - MFR. ISC STYLE MARK NO. 8 CAP-1018 - CONFIRM SIZE WITH ENGINEER OF RECORD - TEXTURE & PAINT TO MATCH ADJ. CEILING
 - REFER TO ELEVATIONS FOR SCONCE PLACEMENT DESIGN INTENT
 - OPEN-AIR TRELLIS
 - T&G WOOD DECKING AT UNDERSIDE OF COVERED CANOPY - REFER TO STYLE GUIDE FOR FINISH REQUIREMENTS

FURNISHINGS LEGEND:

PA-204 WALL SCONCE

CEILING LEGEND:

- CEILING HEIGHT
CEILING FINISH
- A. PRIMED & PAINTED GYPSUM BOARD
B. PRIMED & PAINTED GYPSUM BOARD - MOISTURE RESISTANT
C. OPEN TO UNDERSIDE OF FLOOR / ROOF SYSTEM ABOVE - PAINT ALL ELEMENTS - ELEVATION INDICATED MAY BE "APPROXIMATE" & FOR GENERAL REFERENCE ONLY - REFER TO SECTIONS
D. 2X2 LAY-IN ACoustICAL CLG. TILE SUSPENDED FROM STRUCT.
E. 2X4 LAY-IN CLG. GRID SYSTEM SUSPENDED FROM STRUCT. - INFILLED W/ 1/2" VINYL FACED GYPSUM BOARD PANELS
F. UNDERSIDE OF FLOOR / ROOF SYSTEM - PRIMED & PAINTED TO RECEIVE FINAL FINISH

NOTE: PROVIDE 5/8" TYPE "X" GYPSUM BOARD ON RC CHANNELS ABOVE ALL FLURRED OR DROPPED CEILINGS AT THE TRUSSES AS REQUIRED TO MAINTAIN FIRE RATING, TYPICAL

CEILING - FIXTURE LEGEND: SYMBOLS ARE NOT TO SCALE

- DECORATIVE WALL SCONCE - REFER TO FF&E PACKAGE
DECORATIVE ROUND SUSPENDED LIGHT FIXTURE - REFER TO FF&E PACKAGE
DECORATIVE SQUARE SURFACE MOUNT LIGHT FIXTURE - REFER TO FF&E PACKAGE
DECORATIVE SUSPENDED LIGHT FIXTURE - REFER TO FF&E PACKAGE
(R-1) RECESSED DOWNLIGHT
(R-2) RECESSED WALL WASH
(R-3) RECESSED DOWNLIGHT W/ LENS (FLUORESCENT LAMP) - UL WET LABEL
(R-4) SMALL RECESSED DOWNLIGHT (HALOGEN LAMP) NARROW BEAM SPREAD
(R-5) SURFACE MOUNTED FIXTURE
(R-7) EXT. RECESSED DOWNLIGHT WALL WASHER (UL WET LABEL)
(T-1) 2X2 LAY-IN FLUORESCENT FIXTURE
(T-2) 2X4 LAY-IN FLUOR. FIXTURE
(T-3) 1X4 SURFACE MOUNTED FLUORESCENT FIXTURE
(C-1) RECESSED FLUORESCENT COVE FIXTURE - 4FT
(W-1) WALL MOUNTED STRIP LIGHT - 4FT
(S-1) WALL SCONCE @ POOL AREA (UL WET LABEL)
(S-2) WALL SCONCE @ REAR ENTRY (UL WET LABEL)
(S-3) EXTERIOR SCONCE (UPLIGHT)
(S-5) EXTERIOR FLOODLIGHT
(S-11) EXTERIOR HEAVY DUTY LIGHT STRING
SPEAKER
MECHANICAL EXHAUST GRILLE
2X2 MECHANICAL RETURN GRILLE
2X2 MECHANICAL SUPPLY GRILLE
MECHANICAL SUPPLY GRILLE
MECHANICAL RETURN GRILLE
SMOKE DETECTOR
SPRINKLER HEAD
SIDE WALL SPRINKLER HEAD
'VEE' CONTROL JOINT
(P-3) IN-GROUND UPLIGHT
FIRE HORN/STROBE
* PROVIDE EMERGENCY LIGHTING AS REQUIRED BY LOCAL CODE

GENERAL NOTES:

- REFER TO FF&E PACKAGE FOR FURNITURE, BUILT-IN MILLWORK AND FINISH SPECIFICATIONS
- FIRE EXTINGUISHERS, SMOKE DETECTORS AND OTHER EMERGENCY DEVICES TO BE LOCATED PER LOCAL CODE. EXTINGUISHER LOCATIONS WITHIN THE PUBLIC SPACE SHALL BE CONTAINED WITHIN FULLY RECESSED CABINETS, RATED WHERE REQUIRED. PROVIDE EMERGENCY LIGHTING PER LOCAL CODE. CENTER LINE OF WALL DEVICES TO BE MOUNTED AT 10' A.F.F. TYPICAL U.A.G.
- REFER TO HOME 2 SUITES BY HILTON STANDARDS MANUAL FOR ADDITION GUESTROOM, GUESTROOM BATH, GUESTROOM KITCHEN, AND INDOOR POOL REQUIREMENTS
- SPRINKLER HEADS ARE SHOWN FOR DESIGN INTENT & REFERENCE ONLY. LOCAL DESIGNER/ENGINEER WILL NEED TO MODIFY ACCORDINGLY. SPRINKLER HEADS IN CEILINGS IN PUBLIC AREAS TO BE CONCEALED. ALL OTHER HEADS TO BE SEMI-RECESSED
- ANY PORTION OF A WALL SCONCE OR OTHER OBJECT THAT PROTRUDES INTO THE CIRCULATION PATH ABOVE 27" A.F.F. AND BELOW 80" A.F.F. IS LIMITED TO A 4" MAXIMUM PROJECTION.

- Paint @ Exposed Structure
5/8" Type "X" Gypsum Board Ceiling-PT07

981.8 SQ FT

786.3 SQ FT

1 THIRD FLOOR RCP
SCALE: 1/8" = 1'-0"

- KEY NOTES:
- GYP. BD. 'VEE' REVEAL
 - LAUNDRY CHUTE - SHAFT OPEN TO VENT AT ROOF CORNICE BEYOND
 - ALUMINUM ACCENT BAND/TUBE - REFER TO ELEVATIONS
 - EXTERIOR SCONCE(S) - REFER TO FIXTURE LEGEND & ELEVATIONS FOR PLACEMENT & QUANTITY
 - FLUSH ACCESS PANEL W/ DROP IN DOOR - MFR. ISC STYLE/MARKING & CAP 1518 - CONFIRM SIZE WITH ENGINEER OF RECORD - TEXTURE & PAINT TO MATCH ADJ. CEILING
 - REFER TO ELEVATIONS FOR SCONCE PLACEMENT DESIGN INTENT
 - OPEN-AIR TRELLIS
 - 7&G WOOD DECKING AT UNDERSIDE OF COVERED GANTRY - REFER TO STYLE GUIDE FOR FINISH REQUIREMENTS

FURNISHINGS LEGEND:

PA-204 WALL SCONCE

CEILING LEGEND:

- CEILING HEIGHT
- CEILING FINISH
- A. PRIMED & PAINTED GYPSUM BOARD - MOISTURE RESISTANT
- B. OPEN TO UNDERSIDE OF FLOOR / ROOF SYSTEM ABOVE - PAINT ELEMENTS - ELEVATION INDICATED MAY BE APPROXIMATE & FOR GENERAL REFERENCE ONLY - REFER TO SECTIONS
- C. 2X2 LAY-IN ACoustical CLG. TILE SUSPENDED FROM STRUCT.
- D. 2X4 LAY-IN CLG. GRID SYSTEM SUSPENDED FROM STRUCT. - INFILLED W/ 1/2" VINYL FACED GYPSUM BOARD PANELS
- E. UNDERSIDE OF FLOOR / ROOF SYSTEM - PRIMED & PAINTED TO RECEIVE FINAL FINISH

NOTE: PROVIDE 5/8" TYPE "Y" GYPSUM BOARD ON RC CHANNELS ABOVE ALL FURRED OR DROPPED CEILINGS AT THE TRUSSES AS REQUIRED TO MAINTAIN FIRE RATING, TYPICAL.


CEILING - FIXTURE LEGEND: SYMBOLS ARE NOT TO SCALE

- DECORATIVE WALL SCONCE - REFER TO FF&E PACKAGE
- DECORATIVE ROUND SUSPENDED LIGHT FIXTURE - REFER TO FF&E PACKAGE
- DECORATIVE SQUARE SURFACE MOUNT LIGHT FIXTURE - REFER TO FF&E PACKAGE
- DECORATIVE SUSPENDED LIGHT FIXTURE - REFER TO FF&E PACKAGE
- (R-1) RECESSED DOWNLIGHT
- (R-2) RECESSED WALL WASH
- (R-3) RECESSED DOWNLIGHT W/ LENS (FLUORESCENT LAMP) - UL WET LABELED
- (R-4) SMALL RECESSED DOWNLIGHT (HALOGEN LAMP) - NARROW BEAM SPREAD
- (R-6) SURFACE MOUNTED FIXTURE
- (R-7) EXT. RECESSED DOWNLIGHT WALL WASH (UL WET LABEL)
- (T-1) 2X2 LAY-IN FLUORESCENT FIXTURE
- (T-2) 2X4 LAY-IN FLOOR FIXTURE
- (T-3) 1X4 SURFACE MOUNTED FLUORESCENT FIXTURE
- (C-1) RECESSED FLUORESCENT COVE FIXTURE - 4FT
- (W-1) WALL MOUNTED STRIP LIGHT - 4FT
- (S-1) WALL SCONCE @ POOL AREA (UL WET LABEL)
- (S-2) WALL SCONCE @ REAR ENTRY (UL WET LABEL)
- (S-3) EXTERIOR SCONCE (UPLIGHT)
- (S-6) EXTERIOR FLOODLIGHT
- (O-1) EXTERIOR HEAVY DUTY LIGHT STRING
- SPEAKER
- MECHANICAL EXHAUST GRILLE
- 2X2 MECHANICAL RETURN GRILLE
- 2X2 MECHANICAL SUPPLY GRILLE
- MECHANICAL SUPPLY GRILLE
- MECHANICAL RETURN GRILLE
- SMOKE DETECTOR
- SPRINKLER HEAD
- SIDE WALL SPRINKLER HEAD
- 'VEE' CONTROL JOINT
- (P-3) IN-GROUND UPLIGHT
- FIRE HORN/STROBE
- * PROVIDE EMERGENCY LIGHTING AS REQUIRED BY LOCAL CODE


GENERAL NOTES:

- REFER TO FF&E PACKAGE FOR FURNITURE, BUILT-IN MILLWORK AND FINISH SPECIFICATIONS
- FIRE EXTINGUISHERS, SMOKE DETECTORS AND OTHER EMERGENCY DEVICES TO BE LOCATED PER LOCAL CODE. EXTINGUISHER LOCATIONS WITHIN THE PUBLIC SPACE SHALL BE CONTAINED WITHIN FULLY RECESSED CABINETS, RATED WHERE REQUIRED
- PROVIDE EMERGENCY LIGHTING PER LOCAL CODE. CENTER LINE OF WALL DEVICES TO BE MOUNTED AT 15" A.F.F. TYPICAL UNLESS NOTED OTHERWISE
- REFER TO HOME 2 SUITES BY HILTON STANDARDS MANUAL FOR ADDITION GUESTROOM, GUESTROOM BATH, GUESTROOM KITCHEN AND INDOOR POOL REQUIREMENTS
- SPRINKLER HEADS ARE SHOWN FOR DESIGN INTENT & REFERENCE ONLY. LOCAL DESIGNER/ENGINEER WILL NEED TO MODIFY ACCORDINGLY. SPRINKLER HEADS IN CEILING IN PUBLIC AREAS TO BE CONCEALED. ALL OTHER HEADS TO BE SEMI-RECESSED.
- ANY PORTION OF A WALL, SCONCE OR OTHER OBJECT THAT PROTRUDES INTO THE CIRCULATION PATH ABOVE 27" A.F.F. AND BELOW 80" A.F.F. IS LIMITED TO A 4" MAXIMUM PROJECTION.


- 5/8" Type "X" Gypsum Board Ceiling-PT07 779.4 SQ FT
- Paint @ Exposed Structure 1005.8 SQ FT
- Two Layers Type "X" Gypsum Board Ceiling 134.2 SQ FT

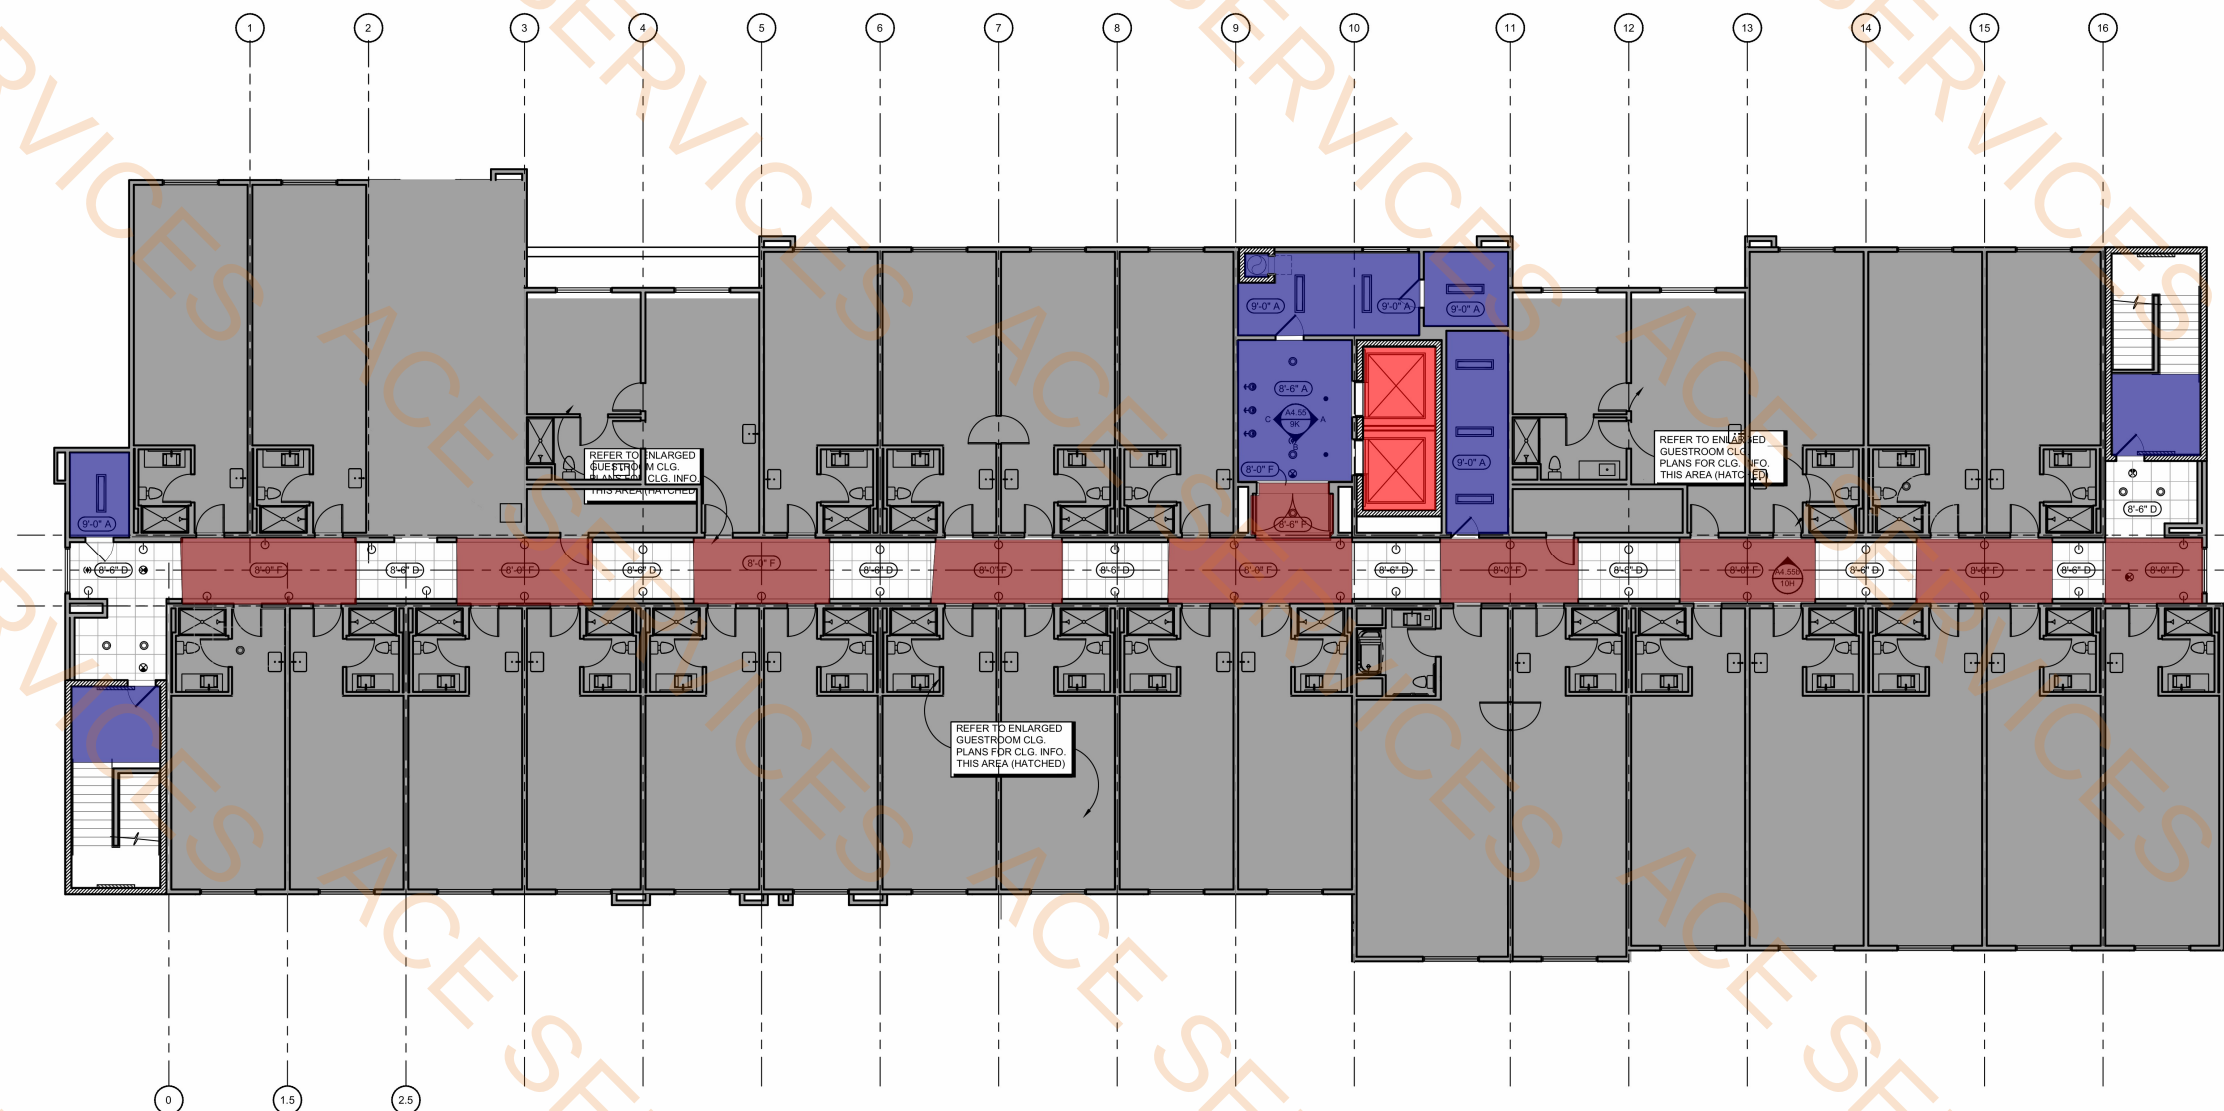


1 FOURTH FLOOR RCP
SCALE: 1/8" = 1'-0"

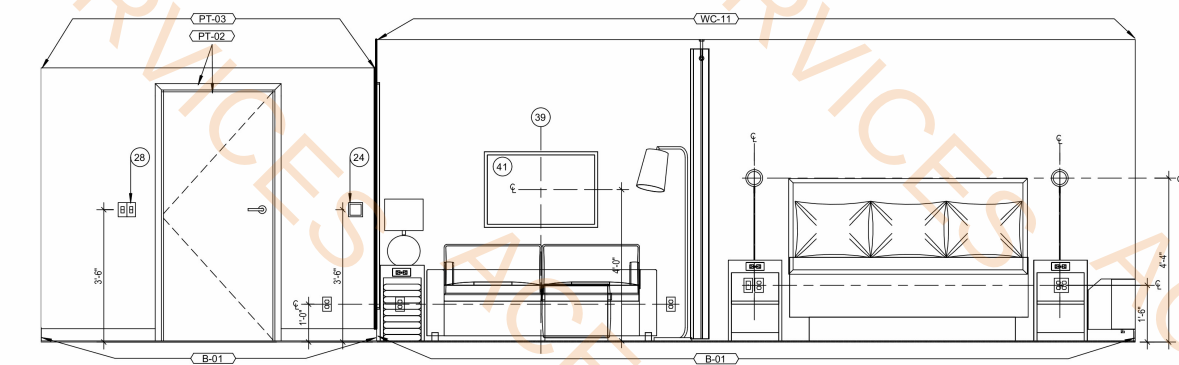


8 HEADBOARD WALL
1/2" = 1'-0"

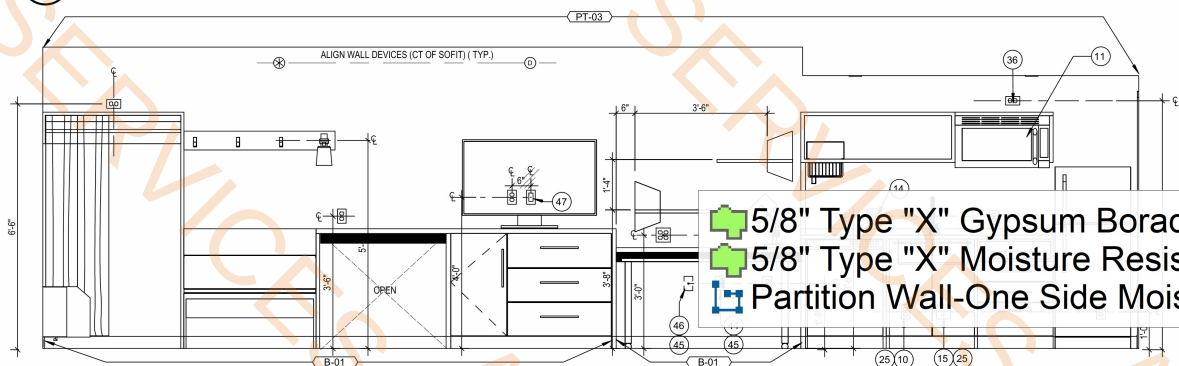


6 WORKING WALL
1/2" = 1'-0"

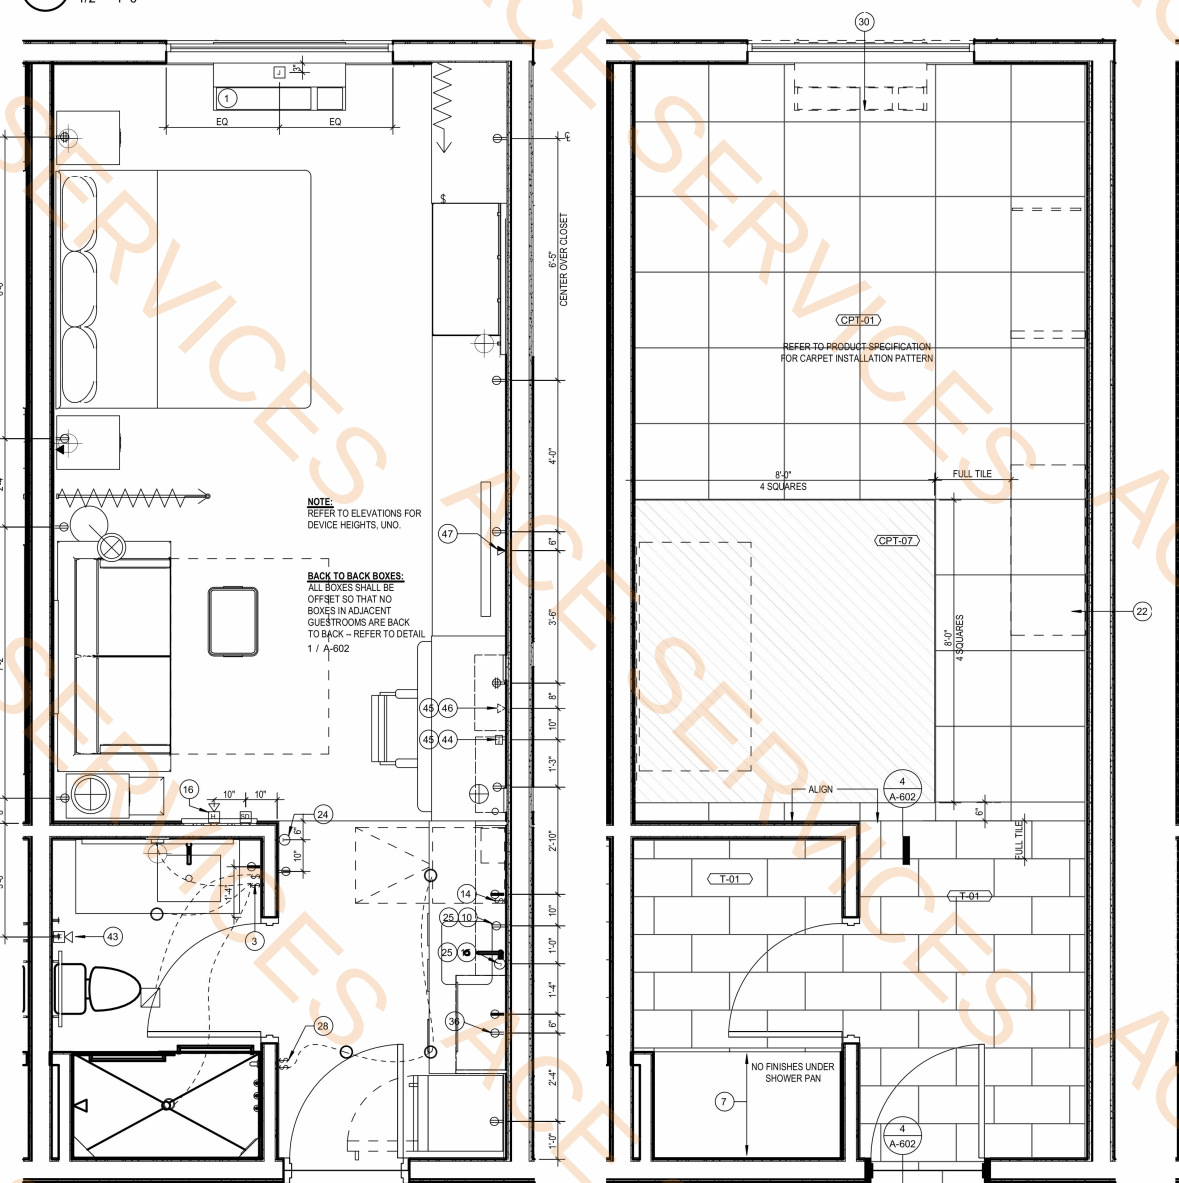


4 ELECTRICAL PLAN
1/2" = 1'-0"

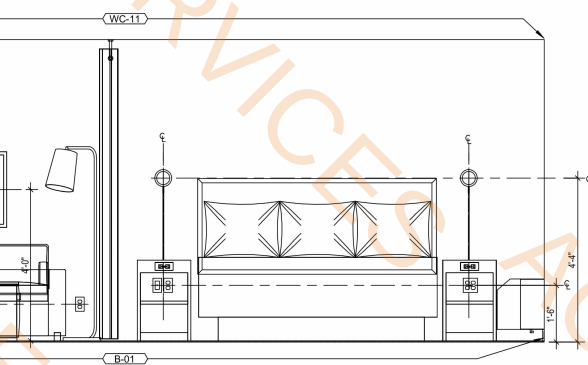


7 WINDOW
1/2" = 1'-0"

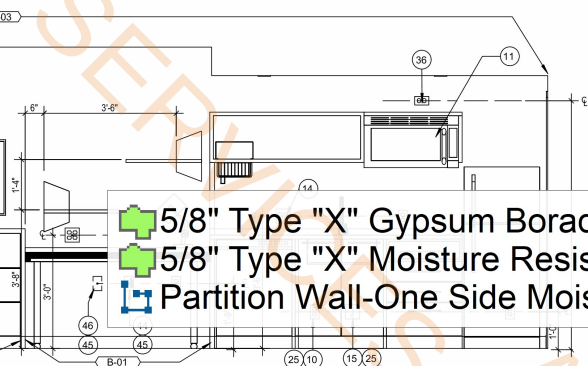

5 ENTRY
1/2" = 1'-0"

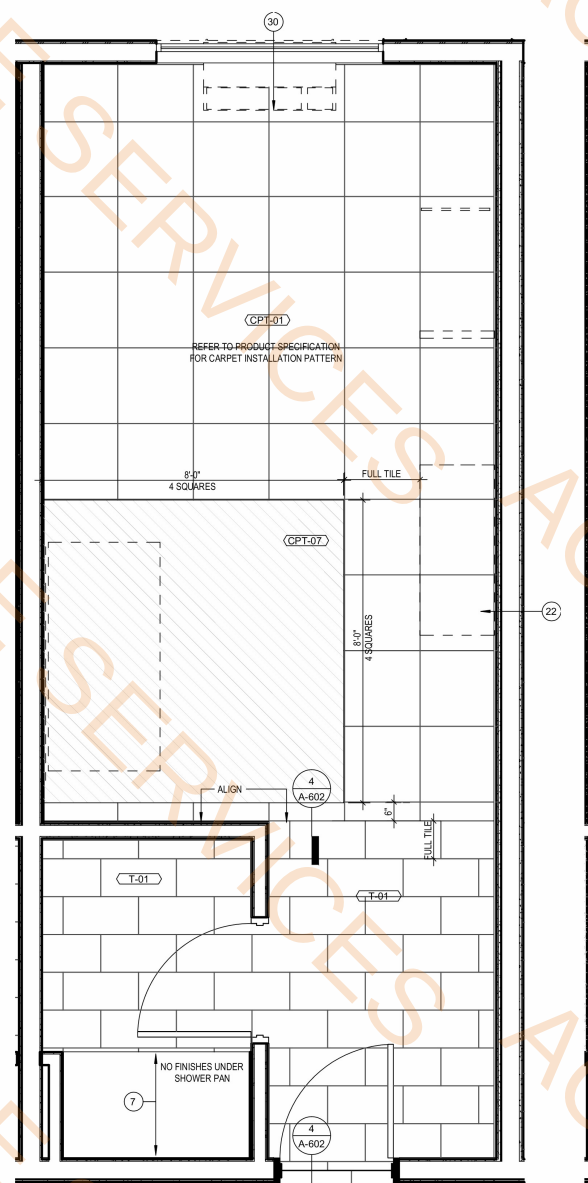

3 FINISH PLAN
1/2" = 1'-0"

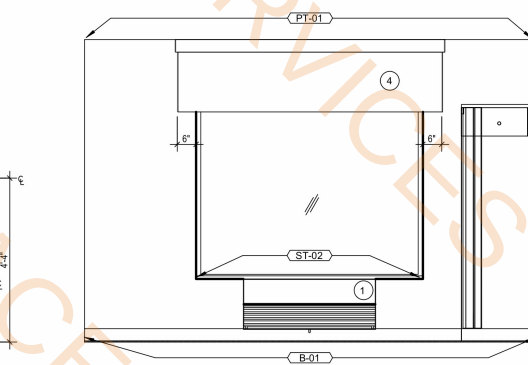


2 REFLECTED CEILING PLAN
1/2" = 1'-0"

FINISH CODE LEGEND

PT	PAINT
PL	PLASTIC LAMINATE
ST	STONE
SP	SPECIAL FINISH
CONC	CONCRETE
CPT	CARPET
T	TILE
QT	QUARRY TILE
B	WALL BASE
RF	RESILIENT FLOORING
WC	WALLCOVERING

CEILING DIMENSION LEGEND

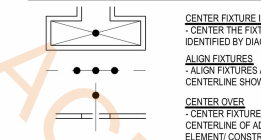

ALERT: ELECTRICAL OUTLETS MUST FIT WITHIN THE PARTITIONED SECTION OF MILLWORK AS INDICATED. ELECTRICAL CONTRACTOR MUST STAGGER OUTLETS AS PER NOTES AND DETAILS IN THESE DRAWINGS, WHILE MAINTAINING RELATIVE POSITIONS AS SHOWN.

LEGEND - FF&E PLANS

XXX-XX	FURNITURE TAG
XXX-XX	EQUIPMENT TAG

FURNISHINGS LEGEND:

GR-101	SLEEPER SOFA
GR-102	DINING CHAIR
GR-103	TASK CHAIR
GR-104	OTTOMAN
GR-105	TABLE LAMP
GR-201	DESK LAMP
GR-202	NIGHTSTAND SCONCE
GR-203	VANITY SCONCE
GR-301	WALL HOOK SCONCE
GR-302	FLOOR LAMP
GR-303	WALL SCONCE
GR-304	TABLE LAMP
GR-305	NIGHTSTAND SCONCE (ADA)
GR-306	QUEEN HEADBOARD
GR-307	KING HEADBOARD
GR-308	VANITY
GR-309	ACCESSIBLE VANITY
GR-310	WORKING WALL
GR-311	KING NIGHTSTAND
GR-312	SOFA SIDE TABLE
GR-313	DOUBLE QUEEN NIGHTSTAND
GR-400	MANUAL ROLLER SHADE
GR-401	MOTORIZED ROLLER SHADE
GR-402	ROOM DIVIDER
GR-403	CLOSET DRAPERY
GR-500	ARTWORK AT SLEEPER SOFA
GR-501	VANITY MIRROR
GR-502	FULL LENGTH MIRROR
GR-503	QUEEN MATTRESS SET
GR-504	QUEEN BOX SPRING COVER
GR-505	KING MATTRESS SET
GR-506	KING BOX SPRING COVER
GR-601	QUEEN BED BASE
GR-602	QUEEN ACCESSIBLE BED BASE
GR-603	KING BED BASE
GR-604	KING ACCESSIBLE BED BASE
GR-605	ACCESSIBLE QUEEN BED SKIRT
GR-606	ACCESSIBLE KING BED SKIRT
GR-607	REFRIGERATOR
GR-608	REFRIGERATOR
GR-609	TELEVISION
GR-610	CLOCK RADIO
GR-611	TELEPHONE
GR-612	QUEEN MATTRESS & BOXSPRING
GR-613	IT RACK

301.7 SQ FT
48.9 SQ FT
18.2 FT

GENERAL NOTES - GUESTROOMS

- REFER TO FF&E PACKAGE FOR FURNITURE, BUILT-IN MILLWORK & FINISH SPECIFICATIONS.
- SMOKE DETECTORS, SPRINKLERS, AND OTHER EMERGENCY DEVICES TO BE LOCATED PER LOCAL CODES INDICATED FOR DESIGN INTENT ONLY.
- PROVIDE EMERGENCY LIGHTING PER LOCAL CODE.
- WALL RECEPTACLE DATA PORTS TO BE MOUNTED @ 12" A.F.F. TYPICAL UNLESS OTHERWISE NOTED.
- REFER TO HOME 2 SUITES BY HILTON STANDARDS MANUAL FOR ADDITIONAL GUESTROOM, GUESTROOM BATH, GUESTROOM KITCHEN & INDOOR POOL, RECEPTION AREA, COMPLIANCE WITH ACCESSIBLE STANDARDS, OPERABLE CONTROLS LOCATED OVER AN OBSTRUCTION DEEPER THAN 10" MUST BE MOUNTED NO HIGHER THAN 48" A.F.F. ACCESSIBLE CONTROLS MUST NOT REQUIRE TIGHT GRASPING, PINCHING OR TWISTING OF THE WRIST. ACCESSIBLE CONTROLS SHALL COMPLY WITH THE HADA.
- IN ACCESSIBLE ROOMS AT LEAST ONE OUTLET & DATA CONNECTION FOR USE BY GUEST MUST BE MOUNTED @ 15" & 48" A.F.F. AND PROVIDE A CLEAR FLOOR AREA IN COMPLIANCE WITH ACCESSIBLE STANDARDS. SEE HADA FOR FURTHER REQS.
- OBJECTS MOUNTED WITHIN THE CIRCULATION PATH IN ACCESSIBLE ROOMS @ 27" & 87" A.F.F. SHALL NOT PROTRUDE FURTHER THAN 4" FROM WALL REFER TO HADA FOR FURTHER REQS.
- FOR ALL ITEMS MOUNTED TO THE WALL (SHELVES, FF&E, MIRRORS, ART, ETC., PROVIDE BLOCKING AS REQUIRED).

KEYED NOTES


- PTAC UNIT
- IN BATHROOM LOCATIONS ONLY, LIGHT SWITCH EQUIPPED WITH NIGHTLUGH MOUNTED SO TOP OF SWITCH IS 48" MAX A.F.F.
- MANUAL BLACK OUT ROLLER SHADE TO EXTEND 6" BEYOND WINDOW OPENING. SHEER ROLLER SHADE TO BE MOUNTED INSIDE WINDOW OPENING.
- SHOWER ENCLOSURE W/ TEMPERED GLASS DOOR
- FLOOR DRAIN
- PRE-MANUFACTURED SHOWER PAN
- CEILING MOUNTED DRAPERY ROD-PROVIDE BLOCKING AS REQUIRED
- ALTERNATE LOCATION OF DOOR FOR CONNECTING ROOMS TO ACCESSIBLE ROOMS-REFER TO OVERALL PLANS FOR LOCATION OF ACCESSIBLE ROOMS
- DEDICATED CIRCUIT FOR DISHWASHER
- RANGE TOP STYLE MICROWAVE AFFIXED TO WALL
- MIRROR
- BEGIN CARPET TILE THIS SIDE W/ FULL TILE-FIRST TWO ROWS OF TILE TO BE INSTALLED AROUND BUILT-IN CASEGOODS
- SWITCH CONTROLLING GARBAGE DISPOSAL GANGED WITH DUPLEX-REFER TO HADA FOR ACCESSIBLE ROOM REQUIREMENTS.
- DEDICATED CIRCUIT FOR GARBAGE DISPOSAL
- FIRE HORN IN STANDARD ROOMS. FIRE HORN STROBE IN COMMUNICATION FEATURES ROOMS
- RECESSED CEILING LIGHT FOR WET LOCATIONS W/ SHATTER PROOF LENS
- TOILET EXHAUST GRILLE
- MAKE-UP AIR DIFFUSER
- EXTENT OF SLEEPER SOFA
- APPROXIMATE LOCATIONS OF MILLWORK SUPPORTS ON FLOOR. PROVIDE SHIMS OR LEVELERS UNDER SUPPORTS TO PREVENT CARPET CRUSHING
- ROOM SIGNAGE
- HARD WIRED THERMOSTAT FOR PTAC, MOUNTED 48" MAX TO TOP OF DEVICE. COMMUNICATION BETWEEN THERMOSTAT AND PTAC MAY BE WIRELESS.
- EXTEND J-BOX, DEVICE & COVER PLATE FLUSH W/ MILLWORK BACK PANEL.
- DROPPED GYPSUM BOARD BULKHEAD @ ROUGH OPENING-WHERE PRE-MANUFACTURED SHOWER INSERT IS INDICATED MEASURE ROUGH OPENING FROM FACE OF GYPSUM BOARD
- DOORBELL ON/OFF SWITCH (COMMUNICATION FEATURES ROOMS ONLY) SIGNAGE AS REQ'D.
- EDGE OF PTAC ABOVE CARPET TILES
- MIN. CEILING HEIGHT MUST BE MAINTAINED-REFER TO HOME 2 SUITES BY HILTON STANDARDS MANUAL
- FRAMING SUBCONTRACTOR TO PROVIDE 3/4" F.R.T. PLYWOOD BLOCKING TO RECEIVE ITEM INDICATED-EXTEND FULL LENGTH OF OBJECT
- GENERAL CONTRACTOR TO COORDINATE W/ FIXTURE FABRICATOR WHERE NECESSARY TO PROVIDE PROPER BLOCKING IN WALL FOR ITEM KEYNOTED
- SWITCHES CONTROLLING MECHANICAL SHADES-REFER TO FFE MANUAL
- OUTLET ABOVE FOR MICROWAVE-REFER TO ROOM ELEVATION MOUNT DEVICE HORIZONTALLY-FACE PLATE TO BE WHITE
- REQUIRED ACCESSIBLE CLEAR FLOOR AREA DESIGNATION
- CENTER ARTWORK OVER SOFA
- COUNTERTOP MICROWAVE
- GRAPHIC ART-REFER TO ACCESSORIES LEGEND & CONSTRUCTION PLAN
- ADDITIONAL HORN STROBE LOCATED IN COMMUNICATION FEATURES BATHROOMS ONLY
- WAP IN 3-GANG BOX MOUNTED VERTICALLY UNDER DESK. MAINTAIN 6" BETWEEN ALL BOXES. TYP ALL GUESTROOMS. COORDINATE WAP LOCATION WITH CASEGOODS TO AVOID CONFLICTS. VISIT CONNECTEDROOM.HILTON.COM FOR CURRENT WIRELESS INTERNET REQS AND LIST OF APPROVED INTEGRATORS.
- EACH CABLE MUST HOMERUN BETWEEN THE GUESTROOM AND THE DOOR ON EACH FLOOR. VISIT CONNECTEDROOM.HILTON.COM FOR CURRENT REQUIREMENTS AND OPTIONS.
- OPTION WIRE DATA CONNECTION FOR GUEST USE: A) ADD CAT6 RJ-45 CABLE JACK AND PATCH CORD THROUGH DESKTOP GROMMET - OR - B) PATCH CORD FROM WAP PORT THROUGH DESKTOP GROMMET.
- TV CONNECTIONS FOR FREE-TO-GUEST CONTENT: A) NO SMART TV: COAX CABLE BEHIND TV. CAT6 RJ-45 JACK BEHIND TV. RUN IN SMURF TUBE IN WALL TO WAP UNDER DESK. PATCH CORD TO EDGE CONTROLLER FOR CONNECTED ROOM. MIN. 6" CLEARANCE FROM WALL BOXES. OR - B) SMART TV/INTERNET PROTOCOL TELEVISION (IPTV): COAX NOT REQ'D. CAT6 RJ-45 JACK BEHIND TV. RUN IN SMURF TUBE IN WALL TO WAP UNDER DESK. PATCH CORD TO EDGE CONTROLLER FOR CONNECTED ROOM. CAT6 RJ-45 JACK BEHIND TV IN ONE-BEDROOM TV. MIN. 6" CLEARANCE FROM WALL BOXES. VISIT HILTONTV.COM FOR ADDITIONAL INFORMATION.
- PROVIDE HINGE STOP AT DOOR.
- HARDWIRED BLACK OUT ROLLER SHADE WITH NO EXPOSED WIRES
- PROVIDE OUTLET FOR UNDERCABINET LIGHTING BY OTHERS

LEGEND - GUESTROOM COMPOSITE


CARPET TILE	FLOOR TILE	FINISH MATERIAL EXTENTS
-------------	------------	-------------------------

POWER & SIGNAL LEGEND


PLAN	ELEVATION	DESCRIPTION
⊕	⊕	OUTLET - DUPLEX
⊕	⊕	OUTLET - DUPLEX - GFI
⊕	⊕	OUTLET - QUAD
⊕	⊕	OUTLET - QUAD - GFI
⊕	⊕	PHONE
⊕	⊕	DATA
⊕	⊕	OPTIONAL DATA
⊕	⊕	OUTLET - TV
⊕	⊕	SWITCH, 3 WAY, 4 WAY
⊕	⊕	J BOX
⊕	⊕	ALARM STROBE
⊕	⊕	DOORBELL
⊕	⊕	SMOKE DETECTOR
⊕	⊕	THERMOSTAT
⊕	⊕	ALARM HORN AND STROBE
⊕	⊕	SIDE WALL SPRINKLER HEAD
⊕	⊕	SPRINKLER HEAD
⊕	⊕	SIDE WALL SPRINKLER HEAD
⊕	⊕	WAP
⊕	⊕	ENLARGED PLANS AND ELEVATIONS - KING STUDIO SUITE

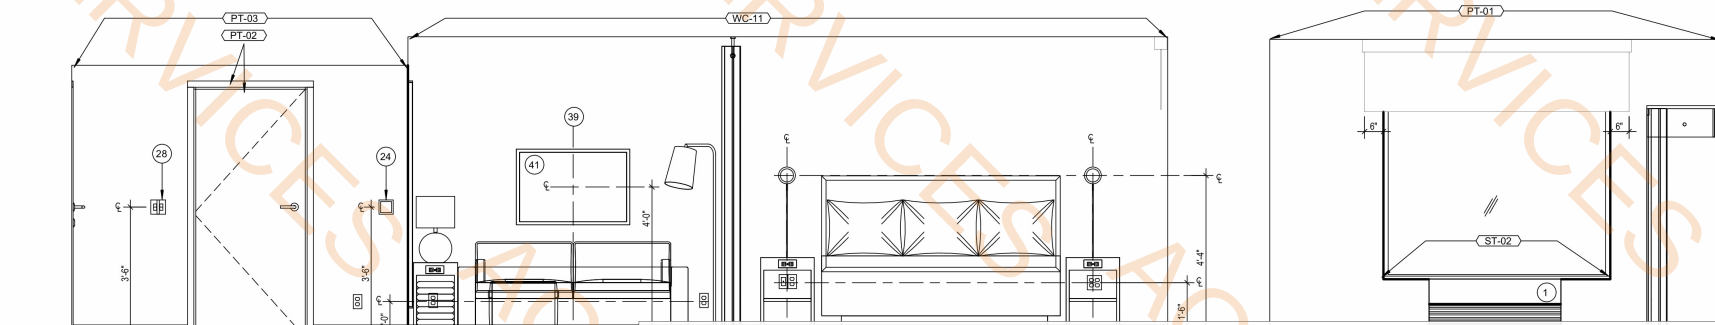

8 HEADBOARD
1/2" = 1'-0"

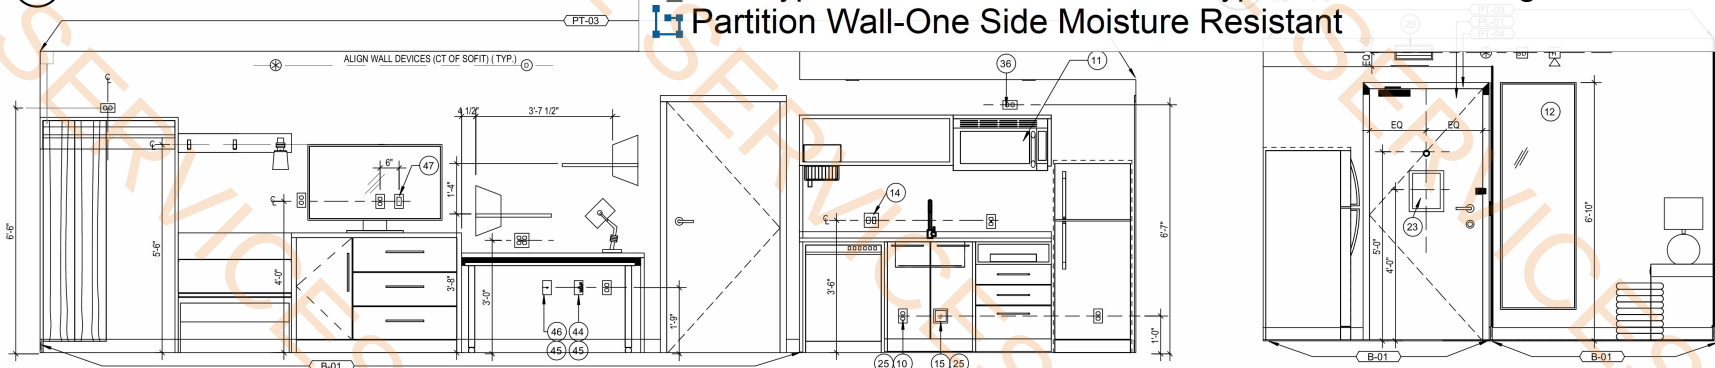


6 WORKING WALL
1/2" = 1'-0"

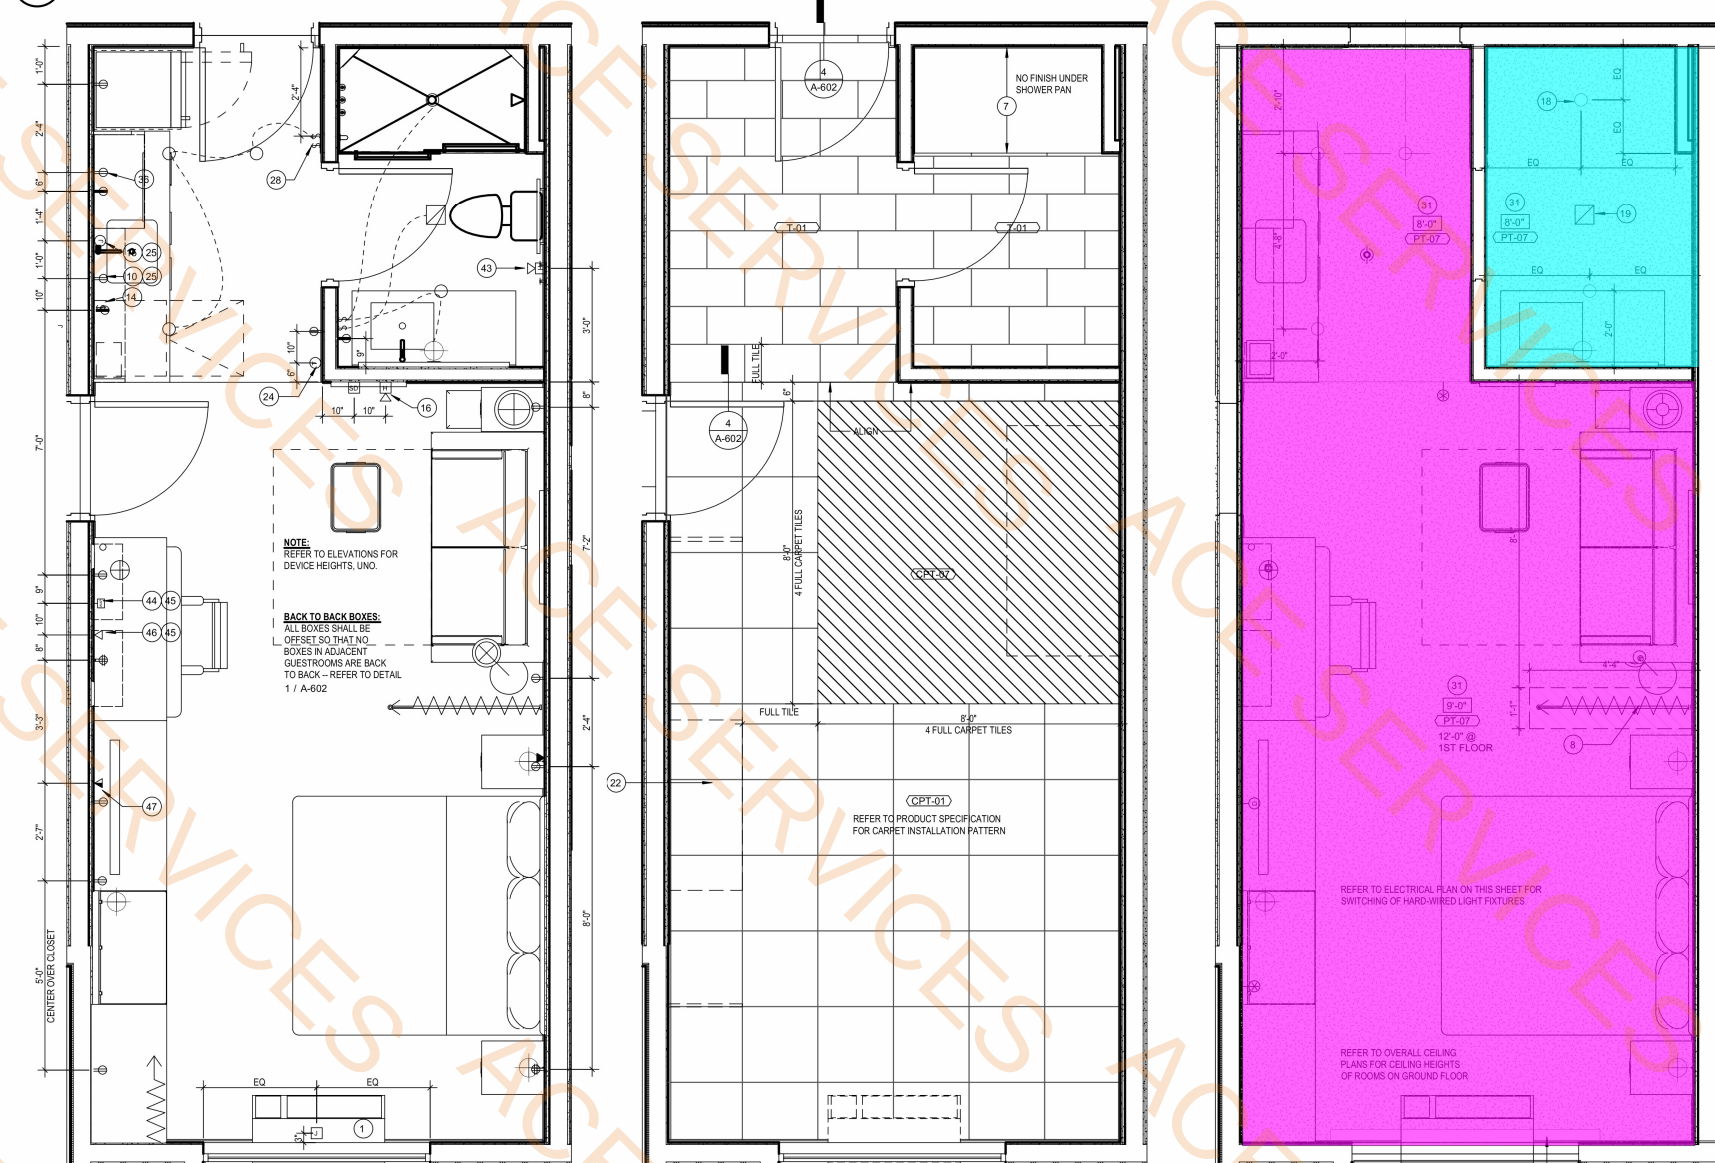

4 ELECTRICAL PLAN
1/2" = 1'-0"

3 FINISH PLAN
1/2" = 1'-0"


2 REFLECTED CEILING PLAN
1/2" = 1'-0"

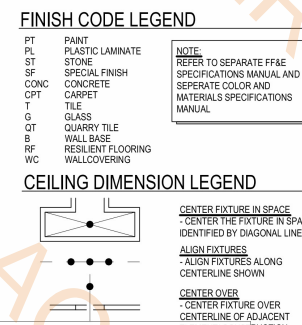

300.9 SQ FT
48.9 SQ FT
17.7 FT


- LEGEND - FF&E PLANS
- LEGEND - FURNISHINGS LEGEND:
- LEGEND - CEILING DIMENSION LEGEND

- GENERAL NOTES - GUESTROOMS
- KEYED NOTES

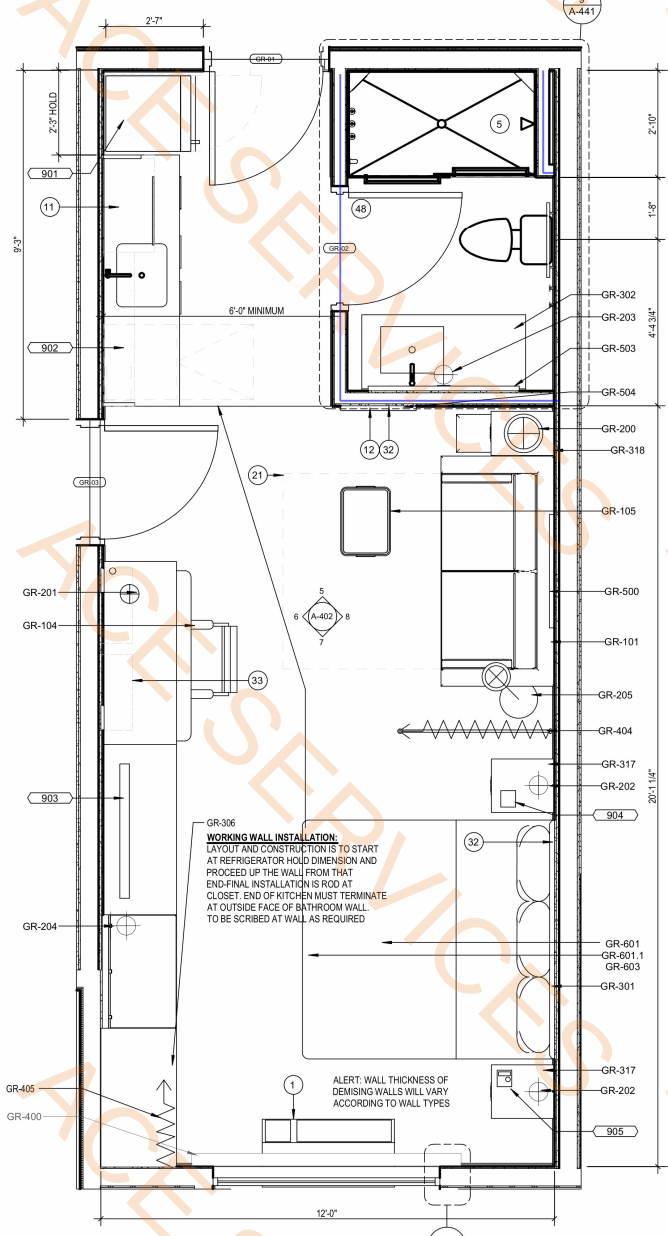


1 ARCHITECTURAL PLAN
1/2" = 1'-0"

- LEGEND - GUESTROOM COMPOSITE
- POWER & SIGNAL LEGEND

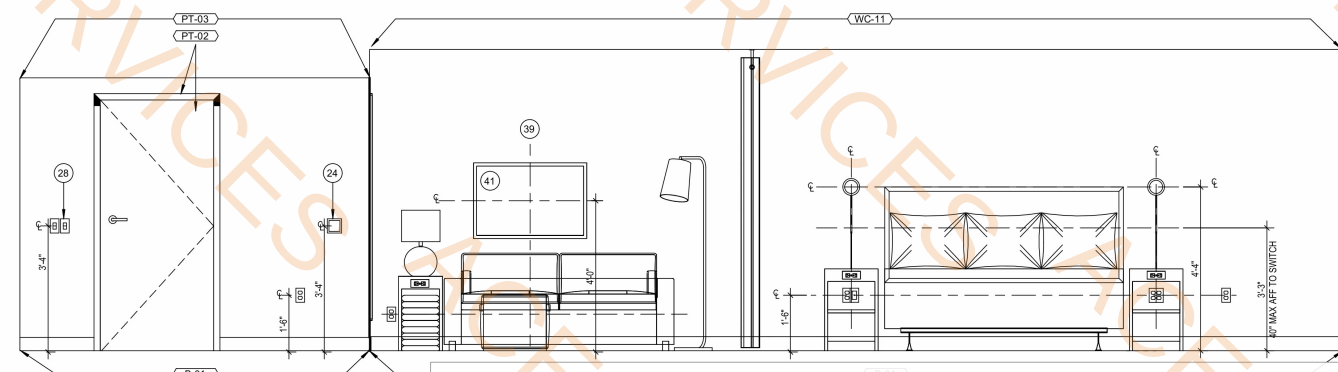


8 HEADBOARD WALL
1/2" = 1'-0"

5/8" Type "X" Gypsum Borad Ceiling- PT07
5/8" Type "X" Moisture Resistant Gypsum Borad Ceiling- PT07
Partition Wall-One Side Moisture Resistant

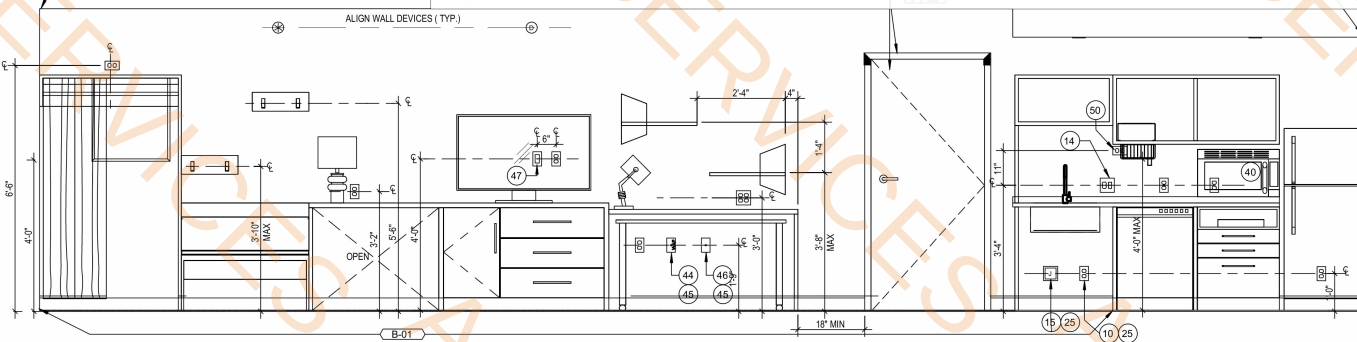


6 WORKING WALL
1/2" = 1'-0"


ALERT!
ELECTRICAL OUTLETS MUST FIT WITH THE PARTITIONED SECTION OF MILLWORK AS INDICATED.
ELECTRICAL CONTRACTOR MUST STAGGER OUTLETS AS PER NOTES AND DETAILS IN THESE DRAWINGS.
WHILE MAINTAINING RELATIVE POSITIONS AS SHOWN.

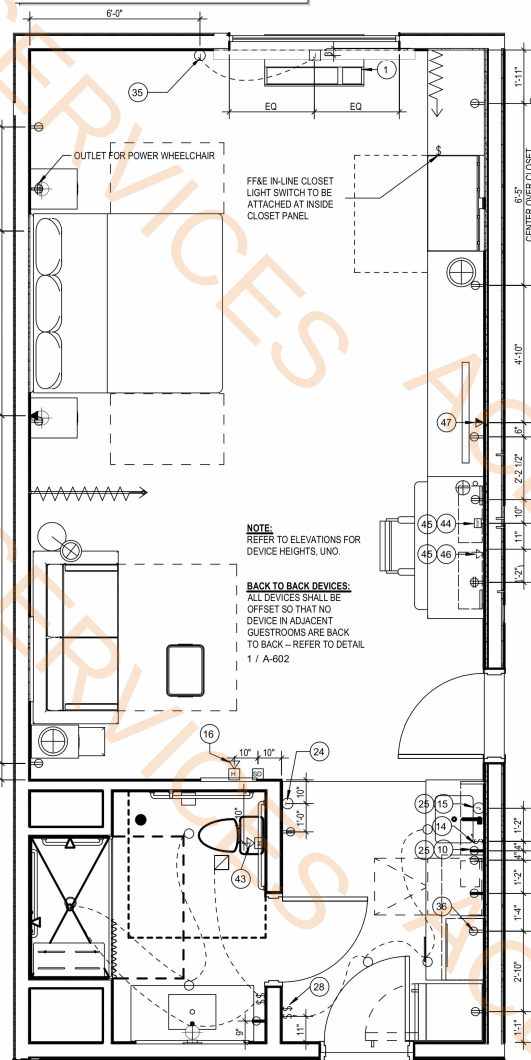


4 ELECTRICAL PLAN
3/8" = 1'-0"

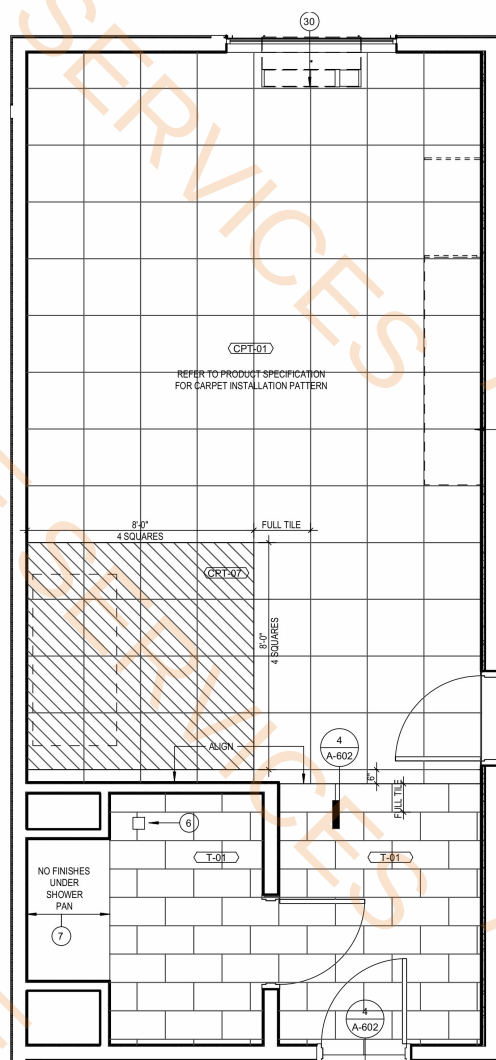

3 FINISH PLAN
3/8" = 1'-0"

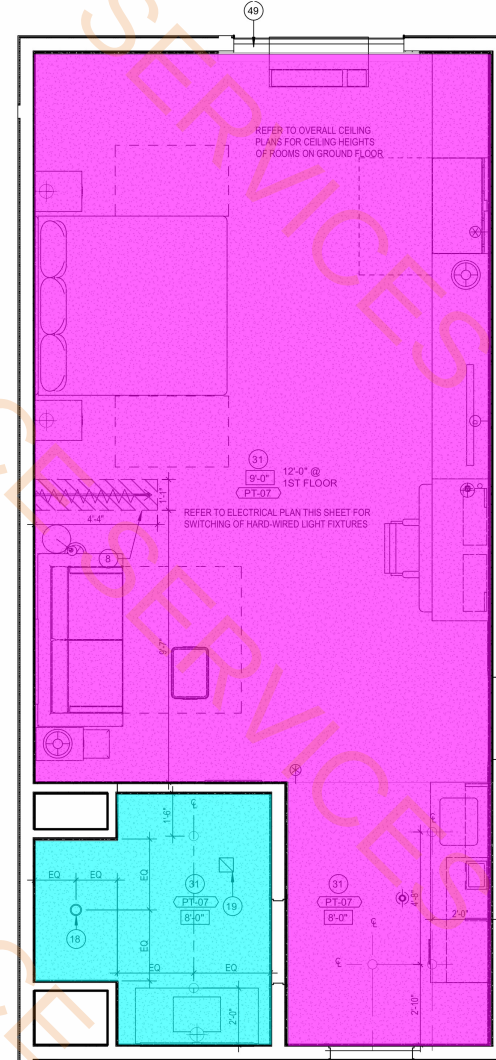

2 REFLECTED CEILING PLAN
3/8" = 1'-0"

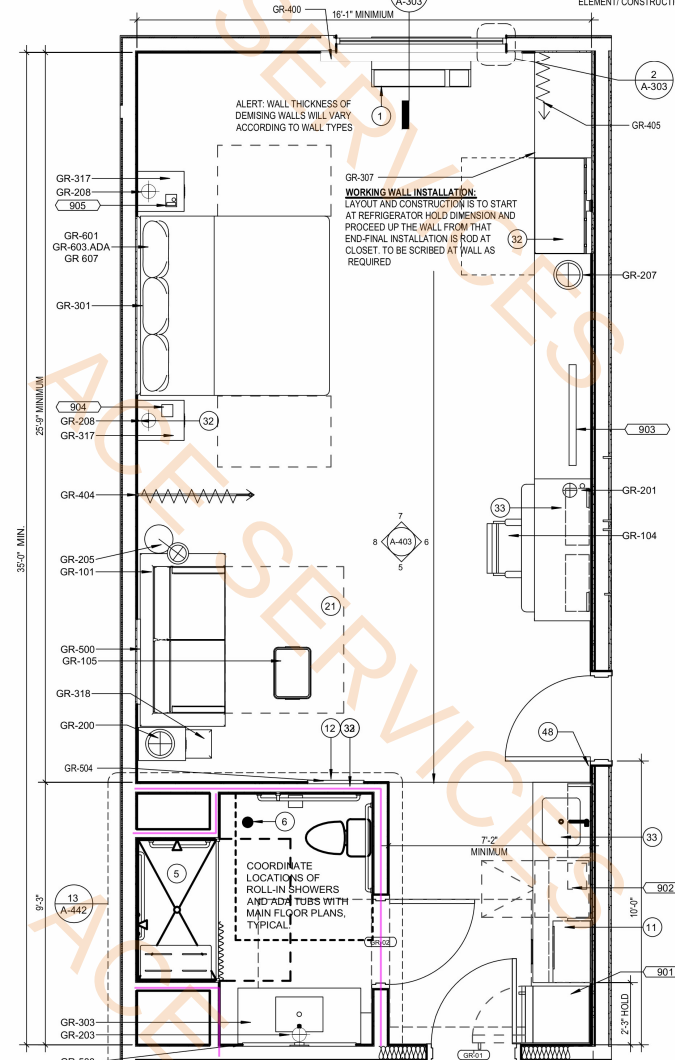

1 ARCHITECTURAL PLAN
3/8" = 1'-0"

LEGEND - FF&E PLANS

XXX-XX FURNITURE TAG
EQUIPMENT TAG

FURNISHINGS LEGEND:

GR-101 SLEEPER SOFA
GR-102 DINING CHAIR
GR-104 TASK CHAIR
GR-105 OTTOMAN
GR-200 TABLE LAMP
GR-201 NIGHTSTAND SCONCE
GR-202 VANITY SCONCE
GR-203 WALL HOOK SCONCE
GR-205 FLOOR LAMP
GR-206 WALL SCONCE
GR-207 TABLE LAMP
GR-208 NIGHTSTAND SCONCE (ADA)
GR-300 QUEEN HEADBOARD
GR-301 KING HEADBOARD
GR-302 VANITY
GR-303 ACCESSIBLE VANITY
GR-303-16 WORKING WALL
GR-317 KING NIGHTSTAND
GR-318 SOFA SIDE TABLE
GR-319 DINING TABLE
GR-322 DOUBLE QUEEN NIGHTSTAND
GR-400 MANUAL ROLLER SHADE
GR-401 MOTORIZED ROLLER SHADE
GR-404 ROOM DIVIDER
GR-405-40 CLOSET DRAPERY
GR-500 ARTWORK AT SLEEPER SOFA
GR-503 VANITY MIRROR
GR-504 FULL LENGTH MIRROR
GR-400 QUEEN MATTRESS SET
GR-401 KING BOX SPRING COVER
GR-402 QUEEN BED BASE
GR-403-ADA QUEEN ACCESSIBLE BED BASE
GR-403 KING BED BASE
GR-403-ADA KING ACCESSIBLE BED BASE
GR-408 ACCESSIBLE QUEEN BED SKIRT
GR-407 ACCESSIBLE KING BED SKIRT
901 REFRIGERATOR
902 DISHWASHER
903 TELEVISION
904 CLOCK/RADIO
905 TELEPHONE
906 QUEEN MATTRESS & BOXSPRING
907 KING MATTRESS & BOXSPRING
908 TUB SHOWER CURTAIN
909 SHOWER CURTAIN

FINISH CODE LEGEND

PT PAINT
FL PLASTIC LAMINATE
ST STONE
SF SPECIAL FINISH
CONC CONCRETE
CPT CARPET
T TILE
G GLASS
QT QUARRY TILE
B WALL BASE
RF RESILIENT FLOORING
WC WALLCOVERING

NOTE:
REFER TO SEPARATE FF&E SPECIFICATIONS MANUAL AND SPECIFIC COLOR AND MATERIALS SPECIFICATIONS MANUAL

CEILING DIMENSION LEGEND

CENTER FUTURE IN SPACE
- CENTER THE FUTURE IN SPACE IDENTIFIED BY DIAGONAL LINE
ALIGN FUTURE
- ALIGN FUTURE ALONG CENTERLINE SHOWN
CENTER OVER
- CENTER FUTURE OVER CENTERLINE OF ADJACENT ELEMENT/ CONSTRUCTION

GENERAL NOTES - GUESTROOMS

- REFER TO FF&E PACKAGE FOR FURNITURE, BUILT-IN MILLWORK & FINISH SPECS
- SMOKE DETECTORS, SPRINKLERS, AND OTHER EMERGENCY DEVICES TO BE LOCATED PER LOCAL CODE- INDICATED FOR DESIGN INTENT ONLY
- PROVIDE EMERGENCY LIGHTING PER LOCAL CODE
- WALL RECEPTACLES/ DATA PORTS TO BE MOUNTED @ 12" A.F.F. TYPICAL UNO - REFER ALSO TO HADG
- REFER TO HOME 2 SUITES BY HILTON STANDARDS MANUAL FOR ADDITIONAL GUESTROOM, GUESTROOM BATH, GUESTROOM KITCHEN & INDOOR POOL REQ'S
- ALL CONTROLS FOR USE BY GUESTS MUST BE MOUNTED @ 8" BT 15" A.F.F. & 48" A.F.F. & PROVIDE A 30"x48" CLEAR FLOOR AREA IN COMPLIANCE W/ ACCESSIBLE STANDARDS. OPERABLE CONTROLS LOCATED OVER AN OBSTRUCTION DEEPER THAN 10" MUST BE MOUNTED NO HIGHER THAN 48" A.F.F. ACCESSIBLE CONTROLS MUST NOT REQUIRE TIGHT GRASPING, PINCHING OR TWISTING OF THE WRIST. ACCESSIBLE CONTROLS SHALL COMPLY W/ THE HADG
- IN ACCESSIBLE ROOMS AT LEAST ONE OUTLET & DATA CONNECTION FOR USE BY GUEST MUST BE MOUNTED BIT 15" & 48" A.F.F. AND PROVIDE A CLEAR FLOOR AREA IN COMPLIANCE W/ ACCESSIBLE STANDARDS. SEE HADG FOR FURTHER REQ'S
- OBJECTS MOUNTED WITHIN THE CIRCULATION PATH IN ACCESSIBLE ROOMS BIT 27" & 80" A.F.F. SHALL NOT PROTRUDE FARTHER THAN 4" FROM WALL. REFER TO HADG FOR FURTHER REQ'S
- FOR ALL ITEMS MOUNTED TO THE WALL (SHELVES, FF&E, MIRRORS, ART, ETC., PROVIDE BLOCKING AS REQUIRED

KEYED NOTES

- PTAC UNIT
- IN BATHROOM LOCATIONS ONLY, LIGHT SWITCH EQUIPPED WITH NIGHTLIGHT. MOUNTED SO TOP OF SWITCH IS 48" MAX. A.F.F.
- MANUAL BLACK OUT ROLLER SHADE TO EXTEND 6" BEYOND WINDOW OPENING. SHEER ROLLER SHADE TO BE MOUNTED INSIDE WINDOW OPENING
- SHOWER ENCLOSURE W/ TEMPERED GLASS DOOR
- FLOOR DRAIN
- PRE-MANUFACTURED SHOWER PAN
- CEILING MOUNTED DRAPERY ROD-PROVIDE BLOCKING AS REQUIRED
- ALTERNATE LOCATION OF DOOR FOR CONNECTING ROOMS TO ACCESSIBLE ROOMS-REFER TO OVERALL PLANS FOR LOCATION OF ACCESSIBLE ROOMS
- DEDICATED CIRCUIT FOR DISHWASHER
- RANGE TOP STYLE MICROWAVE AFFIXED TO WALL
- MIRROR
- BEGIN CARPET TILE THIS SIDE W/ FULL TILE-FIRST TWO ROWS OF TILE TO BE INSTALLED AROUND BUILT-IN CASEGOODS
- SWITCH CONTROLLING GARBAGE DISPOSAL GANGED WITH DUPLEX - REFER TO HADG FOR ACCESSIBLE ROOM REQUIREMENTS.
- DEDICATED CIRCUIT FOR GARBAGE DISPOSAL
- FIRE HORN IN STANDARD ROOMS. FIRE HORN STROBE IN COMMUNICATION FEATURES ROOMS
- RECESSED CEILING LIGHT FOR WET LOCATIONS W/ SHATTER PROOF LENS
- TOILET EXHAUST GRILLE
- MAKE-UP AIR DIFFUSER
- EXTENT OF SLEEPER SOFA
- APPROXIMATE LOCATIONS OF MILLWORK SUPPORTS ON FLOOR. PROVIDE SHIMS OR LEVELERS UNDER SUPPORTS TO PREVENT CARPET CRUSHING
- ROOM SIGNAGE
- HARD WIRED THERMOSTAT FOR PTAC. MOUNTED 48" MAX TO TOP OF DEVICE. COMMUNICATION BETWEEN THERMOSTAT AND PTAC MAY BE WIRELESS.
- EXTEND J-BOX, DEVICE & COVER PLATE FLUSH W/ MILLWORK BACK PANEL
- DROPPED GYPSUM BOARD BULKHEAD @ ROUGH OPENING -WHERE PRE-MANUFACTURED SHOWER INSERT IS INDICATED MEASURE ROUGH OPENING FROM FACE OF GYPSUM BOARD
- DOORBELL ON/OFF SWITCH- COMMUNICATION FEATURES ROOMS ONLY/ SIGNAGE AS REQ.
- EDGE OF PTAC ABOVE CARPET TILES
- MIN. CEILING HEIGHT MUST BE MAINTAINED - REFER TO HOME 2 SUITES BY HILTON STANDARDS MANUAL
- FRAMING SUBCONTRACTOR TO PROVIDE 3/4" F.R.T. PLYWOOD BLOCKING TO RECEIVE ITEM INDICATED - EXTEND FULL LENGTH OF OBJECT
- GENERAL CONTRACTOR TO COORDINATE W/ FUTURE FABRICATOR WHERE NECESSARY TO PROVIDE PROPER BLOCKING IN WALL FOR ITEM KEYNOTED
- SWITCHES CONTROLLING MECHANICAL SHADES - REFER TO FFE MANUAL
- OUTLET ABOVE MICROWAVE - REFER TO ROOM ELEVATION MOUNT DEVICE HORIZONTALLY-FACE PLATE TO BE WHITE
- REQUIRED ACCESSIBLE CLEAR FLOOR AREA DESIGNATION
- CENTER ARTWORK OVER SOFA
- COUNTERTOP MICROWAVE
- GRAPHIC ART. REFER TO ACCESSORIES LEGEND & CONSTRUCTION PLAN
- ADDITIONAL HORN STROBE LOCATED IN COMMUNICATION FEATURES BATHROOMS ONLY
- WAP IN 3-GANG BOX MOUNTED VERTICALLY UNDER DESK. MAINTAIN 6" BETWEEN ALL BOXES. TIP ALL GUESTROOMS. COORDINATE WAP LOCATION WITH CASEGOODS TO AVOID CONFLICTS. VISIT CONNECTEDROOM.HILTON.COM FOR CURRENT WIRELESS INTERNET REQ'S AND LIST OF APPROVED INTEGRATORS.
- EACH CABLE MUST HOMERUN BETWEEN THE GUESTROOM AND THE IDF ON EACH FLOOR. VISIT CONNECTEDROOM.HILTON.COM FOR CURRENT REQUIREMENTS AND OPTIONS.
- OPTION WIRED DATA CONNECTION FOR GUEST USE. A) ADD CAT6 RJ-45 CABLE JACK AND PATCH CORD THROUGH DESKTOP GROMMET - OR - B) PATCH CORD FROM WAP PORT THROUGH DESKTOP GROMMET.
- TV CONNECTIONS FOR FREE-TO-GUEST CONTENT: A) NO SMART TV: COAX CABLE BEHIND TV. CAT6 RJ-45 JACK BEHIND TV. RUN IN SHIRT TUBE IN WALL TO WAP UNDER DESK. PATCH CORD TO EDGE CONTROLLER FOR CONNECTED ROOM. MIN. 6" CLEARANCE FROM WALL BOXES - OR - B) SMART TV-INTERNET PROTOCOL TELEVISION (IPTV). COAX NOT REQ'D. CAT6 RJ-45 JACK BEHIND TV. RUN IN SHIRT TUBE IN WALL TO WAP UNDER DESK. PATCH CORD TO EDGE CONTROLLER FOR CONNECTED ROOM. CAT6 RJ-45 JACK BEHIND TV IN ONE-BEDROOM TV MIN. 6" CLEARANCE FROM WALL BOXES. VISIT HILTON.HOTEL.COM FOR ADDITIONAL INFORMATION.
- PROVIDE HINGE STOP AT DOOR
- HARDWIRED BLACK OUT ROLLER SHADE WITH NO EXPOSED WIRES
- PROVIDE OUTLET FOR UNDERCABINET LIGHTING BY OTHERS

LEGEND - GUESTROOM COMPOSITE

CARPET TILE FLOOR TILE FINISH MATERIAL EXTENTS

POWER & SIGNAL LEGEND

PLAN	ELEVATION	DESCRIPTION
⊕	⊕	OUTLET - DUPLEX
⊕	⊕	OUTLET - DUPLEX - GFI
⊕	⊕	OUTLET - QUAD
⊕	⊕	OUTLET - QUAD - GFI
☎	☎	PHONE
▼	▼	DATA
▼	▼	OPTIONAL DATA
▼	▼	OUTLET - TV
⚡	⚡	SWITCH, 3 WAY, 4 WAY
⚡	⚡	J-BOX
⚡	⚡	ALARM STROBE
⚡	⚡	DOORBELL
⚡	⚡	SMOKE DETECTOR
⚡	⚡	THERMOSTAT
⚡	⚡	ALARM HORN AND STROBE
⚡	⚡	SIDE WALL SPRINKLER HEAD
⚡	⚡	SPRINKLER HEAD
⚡	⚡	SIDE WALL SPRINKLER HEAD
⚡	⚡	WAP

ENLARGED PLANS AND ELEVATIONS - KING STUDIO SUITE ACCESSIBLE

GENERAL NOTES - GUESTROOMS

- A. REFER TO FREE PACKAGE FOR FURNITURE, BUILT-IN MILLWORK & FINISH SPECS
- B. SMOKE DETECTORS, SPRINKLERS, AND OTHER EMERGENCY DEVICES TO BE LOCATED PER LOCAL CODE. INDICATED FOR DESIGN INTENT ONLY
- C. PROVIDE EMERGENCY LIGHTING PER LOCAL CODE
- D. WALL RECEPTION/STORAGE PORTS TO BE MOUNTED @ 12" A.F.F. TYPICAL UNLESS NOTED OTHERWISE
- E. REFER TO HOME 2 SUITES BY HILTON STANDARDS MANUAL FOR ADDITIONAL GUESTROOM, GUESTROOM BATH, GUESTROOM KITCHEN & INDOOR POOL REQ'S
- F. ALL CONTROLS FOR USE BY GUESTS MUST BE MOUNTED @ 48" B.T.F. & 48" A.F.F. & PROVIDE A 30"X48" CLEAR FLOOR AREA IN COMPLIANCE WITH ACCESSIBLE STANDARDS. OPERABLE CONTROLS LOCATED OVER AN OBSTRUCTION DEEPER THAN 10" MUST BE MOUNTED HIGHER THAN 48" A.F.F. ACCESSIBLE CONTROLS MUST NOT REQUIRE TIGHT GRASPING, PINCHING OR TWISTING OF THE WRIST. ACCESSIBLE CONTROLS SHALL COMPLY WITH THE HADS.
- G. IN ACCESSIBLE ROOMS AT LEAST ONE OUTLET & DATA CONNECTION FOR USE BY GUEST MUST BE MOUNTED BY 30"X48" AND PROVIDE A CLEAR FLOOR AREA IN COMPLIANCE WITH ACCESSIBLE STANDARDS. SEE HADS FOR FURTHER REQ'S
- H. OBJECTS MOUNTED WITHIN THE CIRCULATION PATH IN ACCESSIBLE ROOMS @ 17" & 8" A.F.F. SHALL NOT PROHIBIT FARTHER THAN 4" FROM WALL. REFER TO HADS FOR FURTHER REQ'S
- I. FOR ALL ITEMS MOUNTED TO THE WALL (SHELVES, FRAMES, MIRRORS, ETC.) PROVIDE BLOCKING AS REQUIRED

KEYED NOTES

1. PTAC UNIT
2. IN BATHROOM LOCATIONS ONLY, LIGHT SWITCH EQUIPPED WITH NIGHTLIGH MOUNTED 50" TOP OF SWITCH IS 48" MAX. A.F.F.
3. MANUAL BLACK OUT ROLLER SHADE TO EXTEND 6" BEYOND WINDOW OPENING. SHEER ROLLER SHADE TO BE MOUNTED INSIDE WINDOW OPENING
4. SHOWER ENCLOSURE W/ TEMPERED GLASS DOOR
5. FLOOR DRAIN
6. PRE-MANUFACTURED SHOWER PAN
7. CEILING MOUNTED DRAPERY ROD- PROVIDE BLOCKING AS REQUIRED
8. ALTERNATE LOCATION OF DOOR FOR CONNECTING ROOMS TO ACCESSIBLE ROOMS- REFER TO OVERALL PLANS FOR LOCATION OF ACCESSIBLE ROOMS
9. DEDICATED CIRCUIT FOR DISHWASHER
10. RANGE TOP STYLE MICROWAVE AFFIXED TO WALL
11. MIRROR
12. SEGREGATE TILE THIS SIDE W/ FULL TILE- FIRST TWO ROWS OF TILE TO BE INSTALLED AROUND BUILT-IN CASEGOODS
13. SWITCH CONTROLLING GARBAGE DISPOSAL GANGED WITH DUPLEX. REFER TO HADS FOR ACCESSIBLE ROOM REQUIREMENTS.
14. DEDICATED CIRCUIT FOR GARBAGE DISPOSAL
15. FIRE HORN IN STANDARD ROOMS. FIRE HORN/STROBE IN COMMUNICATION FEATURES ROOMS
16. RECESSED CEILING LIGHT FOR WET LOCATIONS W/ SHATTER PROOF LENS
17. FAN/EXHAUST GRILLE
18. MAKE-UP AIR DIFFUSER
19. EXTENT OF SLEEPER SOFA
20. APPROXIMATE LOCATIONS OF MILLWORK SUPPORTS ON FLOOR. PROVIDE SHIMS OR LEVELERS UNDER SUPPORTS TO PREVENT CARPET CRUSHING
21. ROOM SIGNAGE
22. HARD WIRED THERMOSTAT FOR PTAC. MOUNTED 48" MAX TO TOP OF DEVICE. COMMUNICATION BETWEEN THERMOSTAT AND PTAC MAY BE WIRELESS
23. EXTEND J-BOX DEVICE & COVER PLATE FLUSH W/ MILLWORK BACK PANEL
24. DROPPED GYPSUM BOARD BULKHEAD @ ROUGH OPENING WHERE PRE-MANUFACTURED SHOWER INSERT IS LOCATED. MEASURE ROUGH OPENING FROM FACE OF GYPSUM BOARD
25. DOORBELL ON/OFF SWITCH (COMMUNICATION FEATURES ROOMS ONLY) SIGNAGE AS REQ'D.
26. EDGE OF PTAC ABOVE CARPET TILES
27. MIN. CEILING HEIGHT MUST BE MAINTAINED - REFER TO HOME 2 SUITES BY HILTON STANDARDS MANUAL
28. FRAMING SUBCONTRACTOR TO PROVIDE SHIM & T.P. W/ BLOCKING TO RECEIVE ITEM INDICATED - EXTEND FULL LENGTH OF OBJECT
29. GENERAL CONTRACTOR TO COORDINATE W/ FURNITURE FABRICATOR WHERE NECESSARY TO PROVIDE PROPER BLOCKING IN WALL FOR ITEM KEYNOTED
30. SWITCHES CONTROLLING MECHANICAL SHADES - REFER TO FFE MANUAL
31. OUTLET ABOVE MICROWAVE - REFER TO ROOM ELEVATION MOUNT DEVICE HORIZONTALLY- FACE PLATE TO BE WHITE
32. REQUIRED ACCESSIBLE CLEAR FLOOR AREA DESIGNATION
33. CENTER ARTWORK OVER SOFA
34. COUNTERTOP MICROWAVE
35. GRAPHIC ART. REFER TO ACCESSORIES LEGEND & CONSTRUCTION PLAN
36. ADDITIONAL HORN STROBE. LOCATED IN COMMUNICATION FEATURES BATHROOMS ONLY
37. WAP IN 3-GANG BOX MOUNTED VERTICALLY UNDER DESK. MAINTAIN 6" BETWEEN ALL BOXES. TYP. ALL GUESTROOMS. COORDINATE WAP LOCATION WITH CASEGOODS TO AVOID CONFLICTS. VISIT CONNECTEDROOM.HILTON.COM FOR CURRENT WIRELESS INTERNET REQ'S AND LIST OF APPROVED INTEGRATORS.
38. EACH CABLE MUST HOMERUN BETWEEN THE GUESTROOM AND THE OPEN EACH FLOOR. VISIT CONNECTEDROOM.HILTON.COM FOR CURRENT REQUIREMENTS AND OPTIONS.
39. OPTION WIRELESS DATA CONNECTION FOR GUEST USE: A) ADD CAT6 RJ45 CABLE JACK AND PATCH CORD THROUGH DESKTOP GROMMET - GR-401. B) PATCH CORD FROM WAP PORT THROUGH DESKTOP GROMMET
40. TV CONNECTIONS FOR FREE-TO-GUEST CONTENT: A) NO SMART TV. CABLE BEHIND TV. B) 6" RJ45 JACK BEHIND TV. RUN IN SMURF TUBE IN WALL TO WAP UNDER DESK. PATCH CORD TO EDGE CONTROLLER FOR CONNECTED ROOM. MIN. 6" CLEARANCE FROM WALL BOXES. C) SMART TV. INTERNET PROTOCOL, TELEVISION (PTV), COAXIAL REQ'D. 6" RJ45 JACK BEHIND TV. RUN IN SMURF TUBE IN WALL TO WAP UNDER DESK. PATCH CORD TO EDGE CONTROLLER FOR CONNECTED ROOM. CAT6 RJ45 JACK BEHIND TV IN ONE BEDROOM TV. MIN. 6" CLEARANCE FROM WALL BOXES. VISIT HILTONHOTV.COM FOR ADDITIONAL INFORMATION
41. PROVIDE HINGE STOP AT DOOR
42. HARDWIRED BLACK OUT ROLLER SHADE WITH NO EXPOSED WIRES
43. PROVIDE OUTLET FOR UNDER-SINK LIGHTING BY OTHERS

LEGEND - GUESTROOM COMPOSITE

PLAN	ELEVATION	DESCRIPTION
		CARPET TILE
		FLOOR TILE
		FINISH MATERIAL EXTENTS

POWER & SIGNAL LEGEND


PLAN	ELEVATION	DESCRIPTION
		OUTLET - DUPLEX
		OUTLET - DUPLEX - GFI
		OUTLET - QUAD
		OUTLET - QUAD - GFI
		PHONE
		DATA
		OPTIONAL DATA
		OUTLET - TV
		SWITCH, 3 WAY, 4 WAY
		J BOX
		ALARM STROBE
		DOORBELL
		SMOKE DETECTOR
		THERMOSTAT
		ALARM HORN AND STROBE
		SIDE WALL SPRINKLER HEAD
		SPRINKLER HEAD
		SIDE WALL SPRINKLER HEAD
		WAP

ENLARGED PLANS AND ELEVATIONS - KING ONE BEDROOM SUITE

FINISH CODE LEGEND

PT	PAINT
PL	PLASTIC LAMINATE
ST	STONE
SF	SPECIAL FINISH
CONC	CONCRETE
CPT	CARPET
T	TILE
G	GLASS
QT	QUARRY TILE
W	WALL
RF	RESILIENT FLOORING
WC	WALLCOVERING

CEILING DIMENSION LEGEND

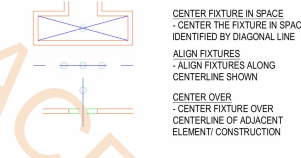

ALERT! ELECTRICAL OUTLETS MUST FIT WITHIN THE PARTITIONED SECTION OF MILLWORK AS INDICATED. ELECTRICAL CONTRACTOR MUST STAGGER OUTLETS AS PER NOTES AND DETAILS IN THESE DRAWINGS, WHILE MAINTAINING RELATIVE POSITIONS AS SHOWN.

LEGEND - FF&E PLANS


XXXX-XX FURNITURE TAG

FURNISHINGS LEGEND:

GR-101	SLEEPER SOFA
GR-102	DINING CHAIR
GR-104	TASK CHAIR
GR-105	OTTOMAN
GR-201	TABLE LAMP
GR-201	DESK LAMP
GR-202	NIGHTSTAND SCIENCE
GR-203	VANITY SCIENCE
GR-204	WALL HOOK SCIENCE
GR-205	FLOOR LAMP
GR-206	WALL SCIENCE
GR-207	TABLE LAMP
GR-208	NIGHTSTAND SCIENCE (ADA)
GR-300	QUEEN HEADBOARD
GR-301	KING HEADBOARD
GR-302	VANITY
GR-303	ACCESSIBLE VANITY
GR-302-316	WORKING WALL
GR-317	KING NIGHTSTAND
GR-318	SOFA SIDE TABLE
GR-319	DINING TABLE
GR-322	DOUBLE QUEEN NIGHTSTAND
GR-400	MANUAL ROLLER SHADE
GR-401	MOTORIZED ROLLER SHADE
GR-404	ROOM DIVIDER
GR-405-406	CLOSET DRAPERY
GR-500	ARTWORK AT SLEEPER SOFA
GR-503	VANITY MIRROR
GR-504	FULL LENGTH MIRROR
GR-601	QUEEN MATTRESS SET
GR-601.1	KING BOX SPRING COVER
GR-602	KING MATTRESS SET
GR-602.1	KING BOX SPRING COVER
GR-603	QUEEN BED BASE
GR-603 ADA	QUEEN ACCESSIBLE BED BASE
GR-603.1	KING ACCESSIBLE BED BASE
GR-606	ACCESSIBLE QUEEN BED SKIRT
GR-607	ACCESSIBLE KING BED SKIRT
901	REFRIGERATOR
902	DISHWASHER
903	TELEVISION
904	CLOCK RADIO
905	TELEPHONE
906	QUEEN MATTRESS & BOXSPRING
907	KING MATTRESS & BOXSPRING
908	TUB SHOWER CURTAIN
909	SHOWER CURTAIN


444.0 SQ FT
71.0 SQ FT
37.5 FT
32.5 FT

5/8" Type "X" Gypsum Borad Ceiling- PT07
5/8" Type "X" Moisture Resistant Gypsum Borad Ceiling- PT07
Type "X" Partition Wall
Partition Wall-One Side Moisture Resistant

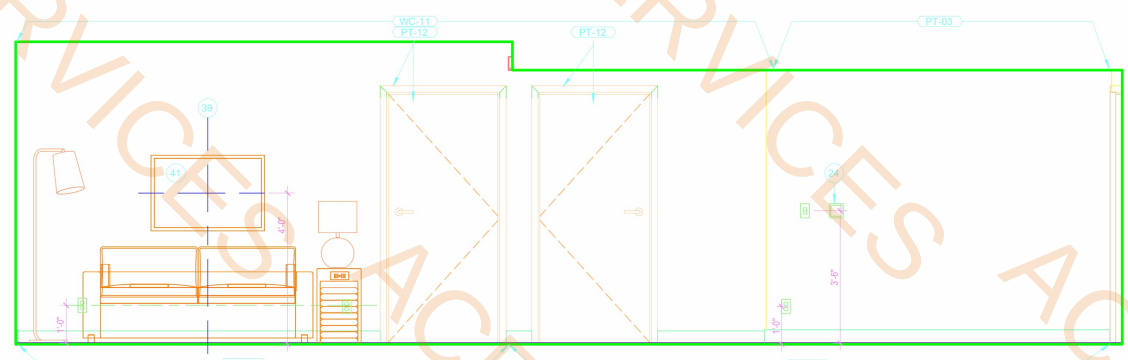

4 SOFA WALL
1/2" = 1'-0"

5 WINDOW
1/2" = 1'-0"

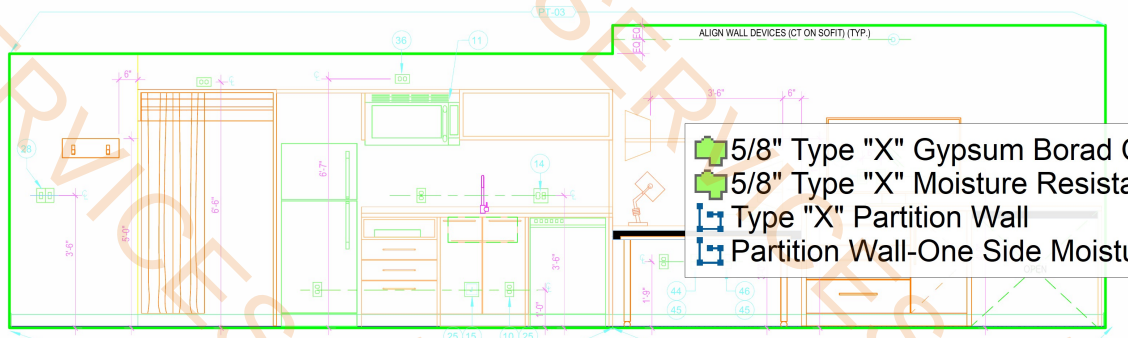


4 WORKING WALL
1/2" = 1'-0"

3 ENTRY
1/2" = 1'-0"



2 REFLECTED CEILING PLAN
1/2" = 1'-0"

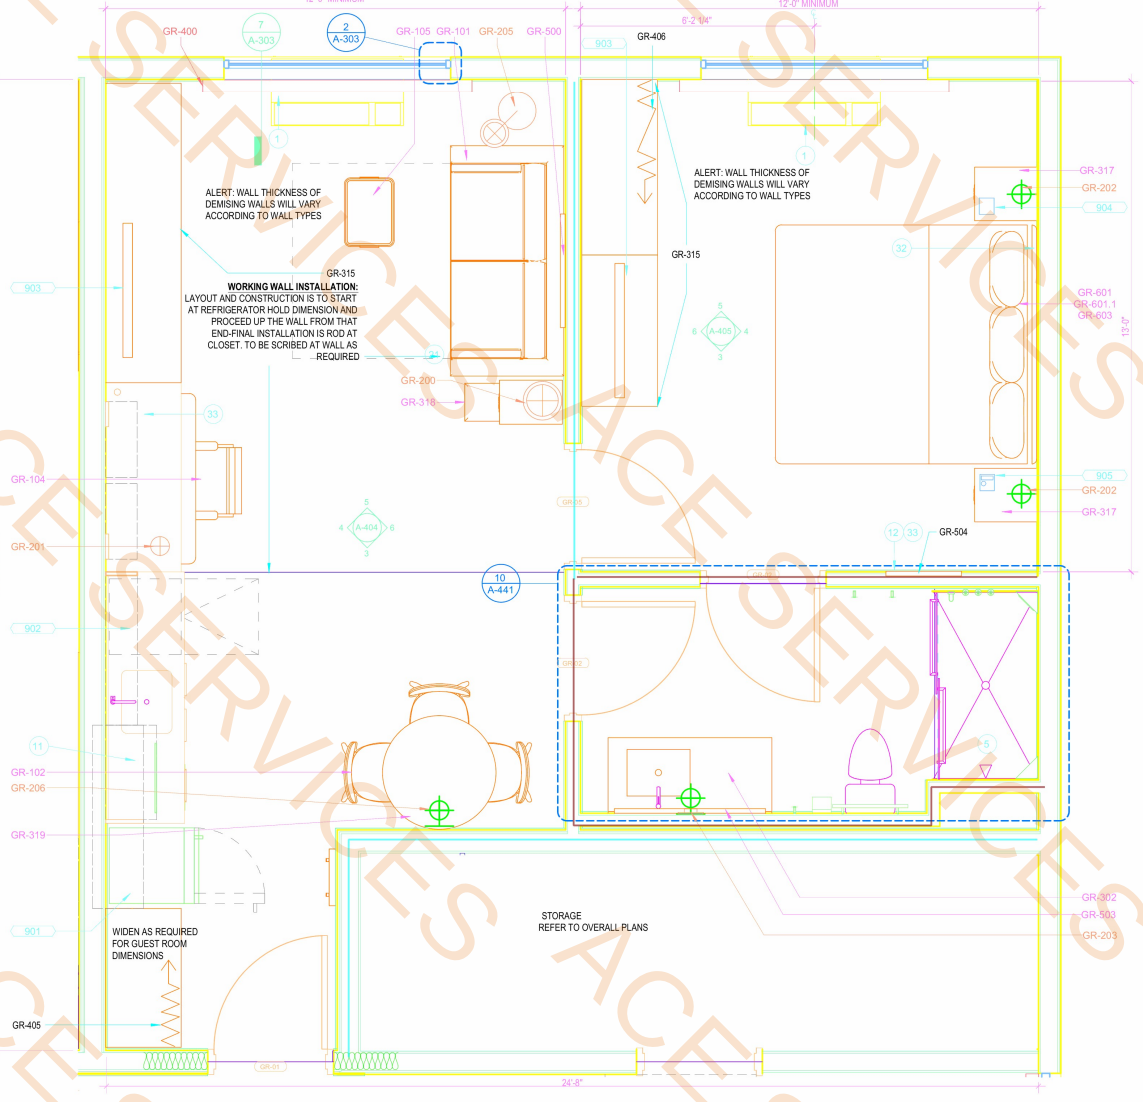

1 ARCHITECTURAL PLAN
1/2" = 1'-0"

5/8" Type "X" Gypsum Borad Ceiling- PT07
5/8" Type "X" Moisture Resistant Gypsum Borad Ceiling- PT07
Partition Wall-One Side Moisture Resistant

389.9 SQ FT
47.5 SQ FT
17.8 FT

FINISH CODE LEGEND

PT PAINT
PL PLASTIC LAMINATE
SF STONE
SP SPECIAL FINISH
CNC CONCRETE
CPT CARPET
T TILE
G GLASS
QT QUARRY TILE
B WALL BASE
RF RESILIENT FLOORING
WC WALLCOVERING

NOTE:
REFER TO SEPARATE FF&E
SPECIFICATIONS MANUAL AND
SEPARATE COLOR AND
MATERIALS SPECIFICATIONS
MANUAL

CEILING DIMENSION LEGEND

CENTER FIXTURE IN SPACE
- CENTER THE FIXTURE IN SPACE
IDENTIFIED BY DIAGONAL LINE
ALIGN FIXTURES
- ALIGN FIXTURES ALONG
CENTERLINE SHOWN
CENTER OVER
- CENTER FIXTURE OVER
CENTERLINE OF ADJACENT
ELEMENT/ CONSTRUCTION

ALERT:
ELECTRICAL OUTLETS MUST FIT WITHIN THE PARTITIONED SECTION
OF MILLWORK AS INDICATED.
ELECTRICAL CONTRACTOR MUST STAGGER OUTLETS
AS PER NOTES AND DETAILS IN THESE DRAWINGS
WHILE MAINTAINING RELATIVE POSITIONS AS SHOWN.

LEGEND - FF&E PLANS

XXXXXX FURNITURE TAG
EQUIPMENT TAG

FURNISHINGS LEGEND:

GR-101 SLEEPER SOFA
GR-102 DINING CHAIR
GR-104 TASK CHAIR
GR-105 OTTOMAN
GR-200 TABLE LAMP
GR-201 DESK LAMP
GR-202 NIGHTSTAND SCONCE
GR-203 VANITY SCONCE
GR-204 WALL HOOK SCONCE
GR-205 FLOOR LAMP
GR-206 WALL SCONCE
GR-207 TABLE LAMP
GR-208 NIGHTSTAND SCONCE (ADA)
GR-301 KING HEADBOARD
GR-302 VANITY
GR-303 ACCESSIBLE VANITY
GR-302-316 WORKING WALL
GR-317 KING NIGHTSTAND
GR-318 SOFA SIDE TABLE
GR-319 DINING TABLE
GR-322 DOUBLE QUEEN NIGHTSTAND
GR-400 MANUALLY OPERATED ROLLER SHADE
GR-401 MOTORIZED ROLLER SHADE
GR-404 ROOM DIVIDER
GR-405-406 CLOSET DRESSERY
GR-500 ARTWORK AT SLEEPER SOFA
GR-503 VANITY MIRROR
GR-504 FULL LENGTH MIRROR
GR-400 QUEEN MATTRESS SET
GR-400.1 QUEEN MATTRESS SPRING COVER
GR-401 KING MATTRESS SET
GR-401.1 KING BOX SPRING COVER
GR-402 QUEEN BED BASE
GR-402 ADA QUEEN ACCESSIBLE BED BASE
GR-403 KING BED BASE
GR-403 ADA KING ACCESSIBLE BED BASE
GR-406 ACCESSIBLE QUEEN BED SKIRT
GR-407 ACCESSIBLE KING BED SKIRT
901 REFRIGERATOR
902 DISHWASHER
903 TELEVISION
904 CLOCK/RADIO
905 TELEPHONE
906 QUEEN MATTRESS & BOXSPRING
907 KING MATTRESS & BOXSPRING
908 TUB SHOWER CURTAIN
909 SHOWER CURTAIN

GENERAL NOTES - GUESTROOMS

- REFER TO FF&E PACKAGE FOR FURNITURE, BUILT-IN MILLWORK & FINISH SPECS
- SMOKE DETECTORS, SPRINKLERS, AND OTHER EMERGENCY DEVICES TO BE LOCATED PER LOCAL CODE- INDICATED FOR DESIGN INTENT ONLY
- PROVIDE EMERGENCY LIGHTING PER LOCAL CODE
- WALL RECEPTACLE DATA PORTS TO BE MOUNTED @ 12" A.F.F. TYPICAL UNLESS NOTED OTHERWISE
- REFER TO HOME 2 SUITES BY HILTON STANDARDS MANUAL FOR ADDITIONAL GUESTROOM, GUESTROOM BATH, GUESTROOM KITCHEN & INDOOR POOL REQS
- ALL CONTROLS FOR USE BY GUESTS MUST BE MOUNTED @ 48" MAX A.F.F. & 48" A.F.F. & PROVIDE A 30"x48" CLEAR FLOOR AREA IN COMPLIANCE W/ ACCESSIBLE STANDARDS. OPERABLE CONTROLS LOCATED OVER AN OBSTRUCTION DEEPER THAN 10" MUST BE MOUNTED NO HIGHER THAN 48" A.F.F. - ACCESSIBLE CONTROLS MUST NOT REQUIRE TIGHT GRASPING, PINCHING OR TWISTING OF THE WRIST. ACCESSIBLE CONTROLS SHALL COMPLY W/ THE HADG
- IN ACCESSIBLE ROOMS AT LEAST ONE OUTLET & DATA CONNECTION FOR USE BY GUEST MUST BE MOUNTED BIT 15" A.F.F. AND PROVIDE A CLEAR FLOOR AREA IN COMPLIANCE W/ ACCESSIBLE STANDARDS. SEE HADG FOR FURTHER REQS
- OBJECTS MOUNTED WITHIN THE CIRCULATION PATH IN ACCESSIBLE ROOMS BIT 27" & 80" A.F.F. SHALL NOT PROTRUDE FARTHER THAN 4" FROM WALL REFER TO HADG FOR FURTHER REQS
- FOR ALL ITEMS MOUNTED TO THE WALL (SHELVES, FF&E, MIRRORS, ART, ETC.), PROVIDE BLOCKING AS REQUIRED

KEYED NOTES

- PTAC UNIT
- IN BATHROOM LOCATIONS ONLY, LIGHT SWITCH EQUIPPED WITH NIGHTLIGHT. MOUNTED SO TOP OF SWITCH IS 48" MAX A.F.F.
- MANUAL BLACK OUT ROLLER SHADE TO EXTEND 8" BEYOND WINDOW OPENING. SHEER ROLLER SHADE TO BE MOUNTED INSIDE WINDOW OPENING
- SHOWER ENCLOSURE W/ TEMPERED GLASS DOOR
- FLOOR DRAIN
- PRE-MANUFACTURED SHOWER PAN
- CEILING MOUNTED DRAPEY ROD-PROVIDE BLOCKING AS REQUIRED
- ALTERNATE LOCATION OF DOOR FOR CONNECTING ROOMS TO ACCESSIBLE ROOMS-REFER TO OVERALL PLANS FOR LOCATION OF ACCESSIBLE ROOMS
- DEDICATED CIRCUIT FOR DISHWASHER
- RANGE TOP STYLE MICROWAVE AFFIXED TO WALL
- MIRROR
- BEGIN CARPET TILE THIS SIDE W/ FULL TILE-FIRST TWO ROWS OF TILE TO BE INSTALLED AROUND BUILT-IN CASEGOODS
- SWITCH CONTROLLING GARBAGE DISPOSAL GANGED WITH DUPLEX - REFER TO HADG FOR ACCESSIBLE ROOM REQUIREMENTS
- DEDICATED CIRCUIT FOR GARBAGE DISPOSAL
- FIRE HORN IN STANDARD ROOMS. FIRE HORN/STROBE IN COMMUNICATION FEATURES ROOMS
- RECESSED CEILING LIGHT FOR WET LOCATIONS W/ SHATTER PROOF LENS
- TOILET EXHAUST GRILLE
- MAKE-UP AIR DIFFUSER
- EXTENT OF SLEEPER SOFA
- APPROXIMATE LOCATIONS OF MILLWORK SUPPORTS ON FLOOR. PROVIDE SHIMS OR LEVELERS UNDER SUPPORTS TO PREVENT CARPET CRUSHING
- ROOM SIGNAGE
- HARD WIRED THERMOSTAT FOR PTAC. MOUNTED 48" MAX TO TOP OF DEVICE. COMMUNICATION BETWEEN THERMOSTAT AND PTAC MAY BE WIRELESS.
- EXTEND J-BOX, DEVICE & COVER PLATE FLUSH W/ MILLWORK BACK PANEL
- DROPPED GYPSUM BOARD BULKHEAD @ ROUGH OPENING. WHERE PRE-MANUFACTURED SHOWER INSERT IS INDICATED MEASURE ROUGH OPENING FROM FACE OF GYPSUM BOARD
- DOORBELL ON/OFF SWITCH (COMMUNICATION FEATURES ROOMS ONLY) SIGNAGE AS REQD
- EDGE OF PTAC ABOVE CARPET TILES
- MIN. CEILING HEIGHT MUST BE MAINTAINED - REFER TO HOME 2 SUITES BY HILTON STANDARDS MANUAL
- FRAMING SUBCONTRACTOR TO PROVIDE 3/4" F.T. PLYWOOD BLOCKING TO RECEIVE ITEM INDICATED - EXTEND FULL LENGTH OF OBJECT
- GENERAL CONTRACTOR TO COORDINATE W/ FIXTURE FABRICATOR WHERE NECESSARY TO PROVIDE PROPER BLOCKING IN WALL FOR ITEM KEYNOTED
- SWITCHES CONTROLLING MECHANICAL SHADES - REFER TO FF&E MANUAL
- OUTLET ABOVE FOR MICROWAVE - REFER TO ROOM ELEVATION MOUNT DEVICE HORIZONTALLY-FACE PLATE TO BE WHITE
- REQUIRED ACCESSIBLE CLEAR FLOOR AREA DESIGNATION
- CENTER ARTWORK OVER SOFA
- COUNTERTOP MICROWAVE
- GRAPHIC ART. REFER TO ACCESSORIES LEGEND & CONSTRUCTION PLAN
- ADDITIONAL HORN STROBE. LOCATED IN COMMUNICATION FEATURES BATHROOMS ONLY
- WAP IN 3-GANG BOX MOUNTED VERTICALLY UNDER DESK. MAINTAIN 6" BETWEEN ALL BOXES. TYP ALL GUESTROOMS. COORDINATE WAP LOCATION WITH CASEGOODS TO AVOID CONFLICTS. VISIT CONNECTEDROOM.HILTON.COM FOR CURRENT WIRELESS INTERNET REQS AND LIST OF APPROVED INTEGRATORS
- EACH CABLE MUST HOMERUN BETWEEN THE GUESTROOM AND THE OF ON EACH FLOOR. VISIT CONNECTEDROOM.HILTON.COM FOR CURRENT REQUIREMENTS AND OPTIONS
- OPTION WIRELESS DATA CONNECTION FOR GUEST USE. A) ADD CAT5 RJ45 CABLE JACK AND PATCH CORD THROUGH DESKTOP GROMMET - OR, B) PATCH CORD FROM WAP PORT THROUGH DESKTOP GROMMET
- TV CONNECTIONS FOR FREE-TO-GUEST CONTENT. A) NO SMART TV. COAX CABLE BEHIND TV. CAT5 RJ45 JACK BEHIND TV. RUN IN SMURF TUBE IN WALL TO WAP UNDER DESK. PATCH CORD TO EDGE CONTROLLER FOR CONNECTED ROOM. MIN. 6" CLEARANCE FROM WALL BOXES - OR, B) SMART TV. INTERNET PROTOCOL TELEVISION (IPTV). COAX NOT REQD. CAT5 RJ45 JACK BEHIND TV. RUN IN SMURF TUBE IN WALL TO WAP UNDER DESK. PATCH CORD TO EDGE CONTROLLER FOR CONNECTED ROOM. CAT5 RJ45 JACK BEHIND TV IN ONE-BEDROOM TV. MIN. 6" CLEARANCE FROM WALL BOXES. VISIT HILTONHOTV.COM FOR ADDITIONAL INFORMATION
- PROVIDE HINGE STOP AT DOOR
- HARDWIRED BLACK OUT ROLLER SHADE WITH NO EXPOSED WIRES
- PROVIDE OUTLET FOR UNDERCABINET LIGHTING BY OTHERS

LEGEND - GUESTROOM COMPOSITE

CARPET TILE FLOOR TILE FINISH MATERIAL EXTENTS

POWER & SIGNAL LEGEND

PLAN	ELEVATION	DESCRIPTION
⊕	⊕	OUTLET - DUPLEX
⊕	⊕	OUTLET - DUPLEX - GFI
⊕	⊕	OUTLET - QUAD
⊕	⊕	OUTLET - QUAD - GFI
⊕	⊕	PHONE
⊕	⊕	DATA
⊕	⊕	OPTIONAL DATA
⊕	⊕	OUTLET - TV
⊕	⊕	SWITCH, 3 WAY, 4 WAY
⊕	⊕	J BOX
⊕	⊕	ALARM STROBE
⊕	⊕	DOORBELL
⊕	⊕	SMOKE DETECTOR
⊕	⊕	THERMOSTAT
⊕	⊕	ALARM HORN AND STROBE
⊕	⊕	SIDE WALL SPRINKLER HEAD
⊕	⊕	SPRINKLER HEAD
⊕	⊕	SIDE WALL SPRINKLER HEAD
⊕	⊕	WAP

ENLARGED PLANS AND ELEVATIONS -
QUEEN QUEEN STUDIO SUITE

- 5/8" Type "X" Gypsum Borad Ceiling- PT07
5/8" Type "X" Moisture Resistant Gypsum Borad Ceiling- PT07
Partition Wall-One Side Moisture Resistant


372.4 SQ FT
47.8 SQ FT
17.7 FT

FINISH CODE LEGEND

PT PAINT
PL PLASTIC LAMINATE
SF SPECIAL FINISH
CONC CONCRETE
CPT CARPET
T TILE
G GLASS
QT QUARRY TILE
S WALL BASE
RF RESILIENT FLOORING
WC WALLCOVERING

NOTE:
REFER TO SEPARATE FF&E
SPECIFICATIONS MANUAL AND
SEPARATE COLOR AND
MATERIALS SPECIFICATIONS
MANUAL.

CEILING DIMENSION LEGEND

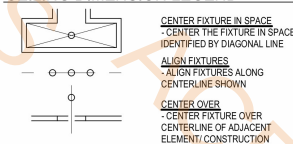

ALERT:
ELECTRICAL OUTLETS MUST FIT WITHIN THE PARTITIONED SECTION
OF MILLWORK AS INDICATED.
ELECTRICAL CONTRACTOR MUST STAGGER OUTLETS
AS PER NOTES AND DETAILS IN THESE DRAWINGS.
WHILE MAINTAINING RELATIVE POSITIONS AS SHOWN.

LEGEND - FF&E PLANS

XXX-XX FURNITURE TAG
EQUIPMENT TAG

FURNISHINGS LEGEND:

- GR-101 SLEEPER SOFA
GR-102 DINING CHAIR
GR-104 TASK CHAIR
GR-105 OTTOMAN
GR-200 TABLE LAMP
GR-201 NIGHTSTAND SCIENCE
GR-202 NIGHTSTAND SCIENCE (ADA)
GR-203 WALL HOOK SCIENCE
GR-204 FLOOR LAMP
GR-205 VANITY
GR-206 ACCESSIBLE VANITY
GR-302-318 WORKING TABLE
GR-317 KING NIGHTSTAND
GR-318 SOFA SIDE TABLE
GR-319 DINING TABLE
GR-322 DOUBLE QUEEN NIGHTSTAND
GR-400-408 CLOSET DRESSING
GR-401 MOTORIZED ROLLER SHADE
GR-404 ROOM DIVIDER
GR-405-408 CLOSET DRESSING
GR-500 ARTWORK AT SLEEPER SOFA
GR-503 VANITY MIRROR
GR-504 FULL LENGTH MIRROR
GR-600 QUEEN MATTRESS SET
GR-600.1 QUEEN MATTRESS SPRING COVER
GR-601 KING MATTRESS SET
GR-601.1 KING BOX SPRING COVER
GR-602 QUEEN BED BASE
GR-602 ADA QUEEN ACCESSIBLE BED BASE
GR-603 KING BED BASE
GR-603 ADA KING ACCESSIBLE BED BASE
GR-606 ACCESSIBLE QUEEN BED SKIRT
GR-607 ACCESSIBLE KING BED SKIRT
901 REFRIGERATOR
902 DISHWASHER
903 TELEVISION
904 CLOCK/RADIO
905 TELEPHONE
906 QUEEN MATTRESS & BOXSPRING
907 KING MATTRESS & BOXSPRING
908 TUB SHOWER CURTAIN
909 SHOWER CURTAIN

GENERAL NOTES - GUESTROOMS

- A. REFER TO FF&E PACKAGE FOR FURNITURE, BUILT-IN MILLWORK & FINISH SPECS
B. SMOKE DETECTORS, SPRINKLERS, AND OTHER EMERGENCY DEVICES TO BE LOCATED PER LOCAL CODE-INDICATED FOR DESIGN INTENT ONLY
C. PROVIDE EMERGENCY LIGHTING PER LOCAL CODE
D. WALL RECEPTACLE/OUTLET PORTS TO BE MOUNTED @ 12" A.F.F. TYPICAL, U.N.O. - REFER ALSO TO HADG
E. REFER TO HOME 2 SUITES BY HILTON STANDARDS MANUAL FOR ADDITIONAL GUESTROOM, GUESTROOM BATH, GUESTROOM KITCHEN & INDOOR POOL, REQS
F. ALL CONTROLS FOR USE BY GUESTS MUST BE MOUNTED @ BT 19" A.F.F. & 4" A.F.F. & PROVIDE A 37" X 48" CLEAR FLOOR AREA IN COMPLIANCE W/ ACCESSIBLE STANDARDS. OPERABLE CONTROLS LOCATED OVER AN OBSTRUCTION DEEPER THAN 10" MUST BE MOUNTED NO HIGHER THAN 48" A.F.F. ACCESSIBLE CONTROLS MUST NOT REQUIRE TIGHT GRASPING, PINCHING OR TWISTING OF THE WRIST. ACCESSIBLE CONTROLS SHALL COMPLY W/ THE HADG
G. IN ACCESSIBLE ROOMS AT LEAST ONE OUTLET & DATA CONNECTION FOR USE BY GUEST MUST BE MOUNTED BT 19" & 48" A.F.F. AND PROVIDE A CLEAR FLOOR AREA IN COMPLIANCE W/ ACCESSIBLE STANDARDS. SEE HADG FOR FURTHER REQS.
H. OBJECTS MOUNTED WITHIN THE CIRCULATION PATH IN ACCESSIBLE ROOMS BT 27" & 80" A.F.F. SHALL NOT PROTRUDE FARTHER THAN 4" FROM WALL. REFER TO HADG FOR FURTHER REQS.
I. FOR ALL ITEMS MOUNTED TO THE WALL (SHELVES, FF&E, MIRRORS, ART, ETC., PROVIDE BLOCKING AS REQUIRED)

KEYED NOTES

1. PTAC UNIT
2. IN BATHROOM LOCATIONS ONLY, LIGHT SWITCH EQUIPPED WITH NIGHTLIGHT. MOUNTED SO TOP OF SWITCH IS 48" MAX A.F.F.
3. MANUAL BLACK OUT ROLLER SHADE TO EXTEND 6" BEYOND WINDOW OPENING. SHEER ROLLER SHADE TO BE MOUNTED INSIDE WINDOW OPENING
4. SHOWER ENCLOSURE W/ TEMPERED GLASS DOOR
5. FLOOR DRAIN
6. PRE-MANUFACTURED SHOWER PAN
7. CEILING MOUNTED DRAPEY ROD-PROVIDE BLOCKING AS REQUIRED
8. ALTERNATE LOCATION OF DOOR FOR CONNECTING ROOMS TO ACCESSIBLE ROOMS-REFER TO OVERALL PLANS FOR LOCATION OF ACCESSIBLE ROOMS
9. DEDICATED CIRCUIT FOR DISHWASHER
10. RANGE TOP STYLE MICROWAVE AFFIXED TO WALL
11. MIRROR
12. BEGIN CARPET TILE THIS SIDE W/ FULL TILE-FIRST TWO ROWS OF TILE TO BE INSTALLED AROUND BUILT-IN CASEGOODS
13. SWITCH CONTROLLING GARBAGE DISPOSAL GANGED WITH DUPLEX - REFER TO HADG FOR ACCESSIBLE ROOM REQUIREMENTS
14. DEDICATED CIRCUIT FOR GARBAGE DISPOSAL
15. FIRE HORN IN STANDARD ROOMS. FIRE HORN/STROBE IN COMMUNICATION FEATURES ROOMS
16. RECESSED CEILING LIGHT FOR WET LOCATIONS W/ SHATTER PROOF LENS
17. TOILET EXHAUST GRILLE
18. MAKE-UP AIR DIFFUSER
19. EXTENT OF SLEEPER SOFA
20. APPROXIMATE LOCATIONS OF MILLWORK SUPPORTS ON FLOOR. PROVIDE SHIMS OR LEVELERS UNDER SUPPORTS TO PREVENT CARPET CRUSHING
21. ROOM SIGNAGE
22. HARD WIRED THERMOSTAT FOR PTAC. MOUNTED 48" MAX TO TOP OF DEVICE. COMMUNICATION BETWEEN THERMOSTAT AND PTAC MAY BE WIRELESS.
23. EXTEND J-BOX, DEVICE & COVER PLATE FLUSH W/ MILLWORK BACK PANEL
24. DROPPED GYPSUM BOARD BULKHEAD @ ROUGH OPENING-WHERE PRE-MANUFACTURED SHOWER INSERT IS INDICATED MEASURE ROUGH OPENING FROM FACE OF GYPSUM BOARD
25. DOORBELL ON/OFF SWITCH COMMUNICATION FEATURES ROOMS ONLY-SIGNAGE AS REQD.
26. EDGE OF PTAC ABOVE CARPET TILES
27. MIN. CEILING HEIGHT MUST BE MAINTAINED - REFER TO HOME 2 SUITES BY HILTON STANDARDS MANUAL
28. FRAMING SUBCONTRACTOR TO PROVIDE 3/4" F.T. PLYWOOD BLOCKING TO RECEIVE ITEM INDICATED - EXTEND FULL LENGTH OF OBJECT
29. GENERAL CONTRACTOR TO COORDINATE W/ FURNITURE FABRICATOR WHERE NECESSARY TO PROVIDE PROPER BLOCKING IN WALL FOR ITEM KEYNOTED
30. SWITCHES CONTROLLING MECHANICAL SHADES - REFER TO FFE MANUAL
31. OUTLET ABOVE FOR MICROWAVE - REFER TO ROOM ELEVATION MOUNT DEVICE HORIZONTALLY-FACE PLATE TO BE WHITE
32. REQUIRED ACCESSIBLE CLEAR FLOOR AREA DESIGNATION
33. CENTER ARTWORK OVER SOFA
34. COUNTERTOP MICROWAVE
35. GRAPHIC ART. REFER TO ACCESSORIES LEGEND & CONSTRUCTION PLAN
36. ADDITIONAL HORN STROBE. LOCATED IN COMMUNICATION FEATURES BATHROOMS ONLY
37. WAP IN 3-GANG BOX MOUNTED VERTICALLY UNDER DESK. MAINTAIN 6" BETWEEN ALL BOXES. TYP ALL GUESTROOMS. COORDINATE WAP LOCATION WITH CASEGOODS TO AVOID CONFLICTS. VISIT CONNECTEDROOM.HILTON.COM FOR CURRENT WIRELESS INTERNET REQS AND LIST OF APPROVED INTEGRATORS
38. EACH CABLE MUST HOMERUN BETWEEN THE GUESTROOM AND THE IDF ON EACH FLOOR. VISIT CONNECTEDROOM.HILTON.COM FOR CURRENT REQUIREMENTS AND OPTIONS.
39. OPTION WIRED DATA CONNECTION FOR GUEST USE: A) ADD CAT6 RJ-45 CABLE JACK AND PATCH CORD THROUGH DESKTOP GROMMET - OR - B) PATCH CORD FROM WAP PORT THROUGH DESKTOP GROMMET
40. TV CONNECTIONS FOR FREE-TO-GUEST CONTENT: A) NO SMART TV: COAX CABLE BEHIND TV. CAT6 RJ-45 JACK BEHIND TV. RUN IN SMURF TUBE IN WALL TO WAP UNDER DESK. PATCH CORD TO EDGE CONTROLLER FOR CONNECTED ROOM. MIN. 6" CLEARANCE FROM WALL BOXES -OR- B) SMART TV-INTERNET PROTOCOL, TELEVISION (IPTV): COAX NOT REQD. CAT6 RJ-45 JACK BEHIND TV. RUN IN SMURF TUBE IN WALL TO WAP UNDER DESK. PATCH CORD TO EDGE CONTROLLER FOR CONNECTED ROOM. CAT6 RJ-45 JACK BEHIND TV IN ONE-BEDROOM TV. MIN. 6" CLEARANCE FROM WALL BOXES. VISIT HILTONH2TV.COM FOR ADDITIONAL INFORMATION.
41. PROVIDE HINGE STOP AT DOOR
42. HARDWIRED BLACK OUT ROLLER SHADE WITH NO EXPOSED WIRES
43. PROVIDE OUTLET FOR UNDERCABINET LIGHTING BY OTHERS


LEGEND - GUESTROOM COMPOSITE




POWER & SIGNAL LEGEND

PLAN	ELEVATION	DESCRIPTION
		OUTLET - DUPLEX
		OUTLET - DUPLEX - GFI
		OUTLET - QUAD
		OUTLET - QUAD - GFI
		PHONE
		DATA
		OPTIONAL DATA
		OUTLET - TV
		SWITCH, 3 WAY, 4 WAY
		J BOX
		ALARM STROBE
		DOORBELL
		SMOKE DETECTOR
		THERMOSTAT
		ALARM HORN AND STROBE
		SIDE WALL SPRINKLER HEAD
		SPRINKLER HEAD
		SIDE WALL SPRINKLER HEAD
		WAP


ENLARGED PLANS AND ELEVATIONS -
QUEEN QUEEN STUDIO SUITE CONNECTOR

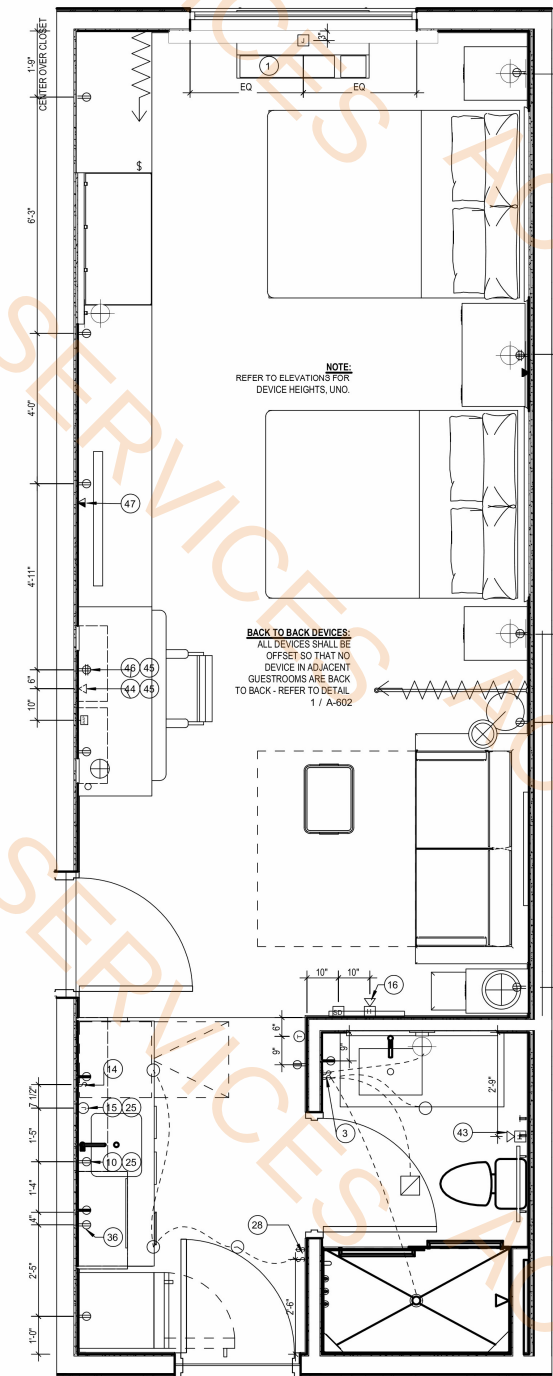


3 ELECTRICAL PLAN
1/2" = 1'-0"

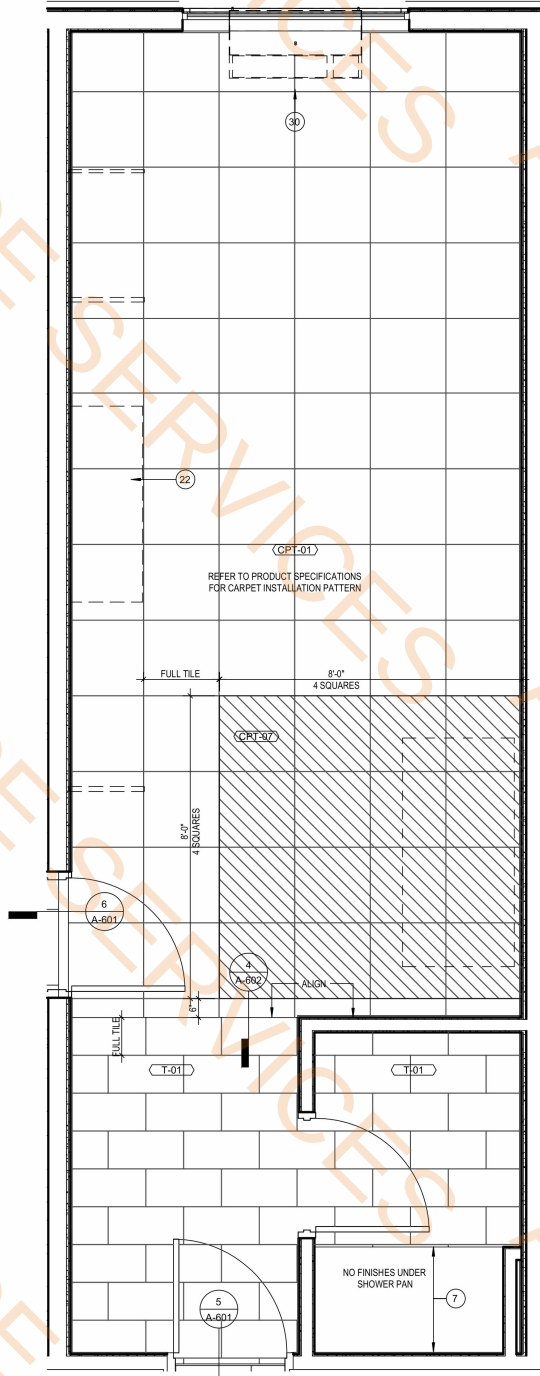

4 FINISH PLAN
1/2" = 1'-0"

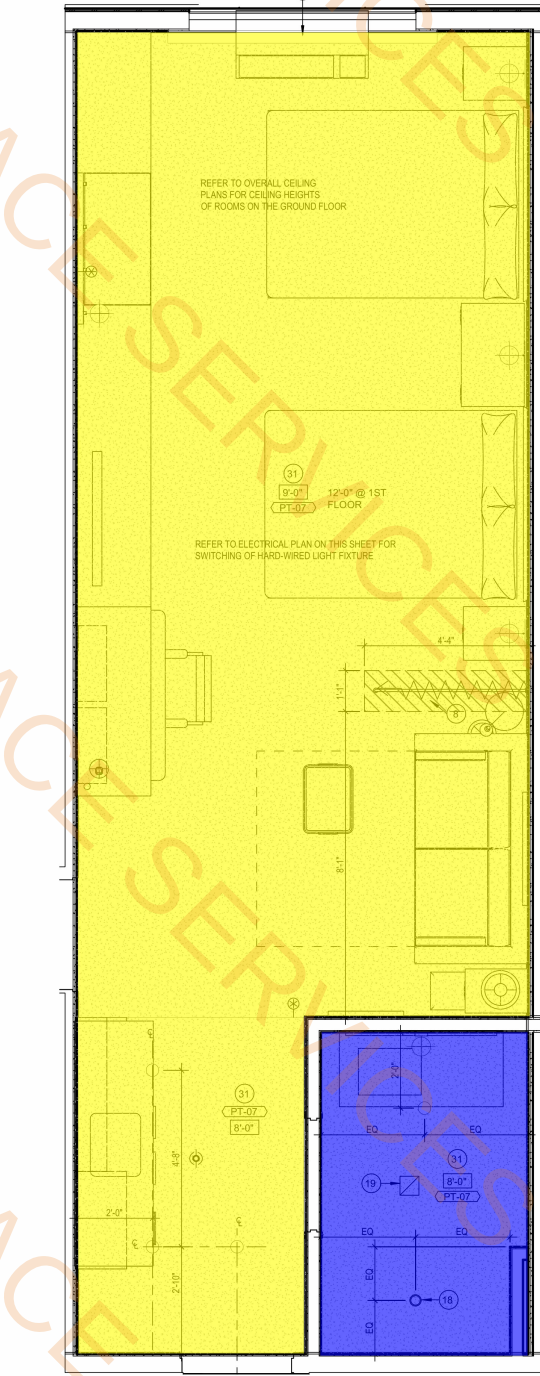

2 REFLECTED CEILING PLAN
1/2" = 1'-0"

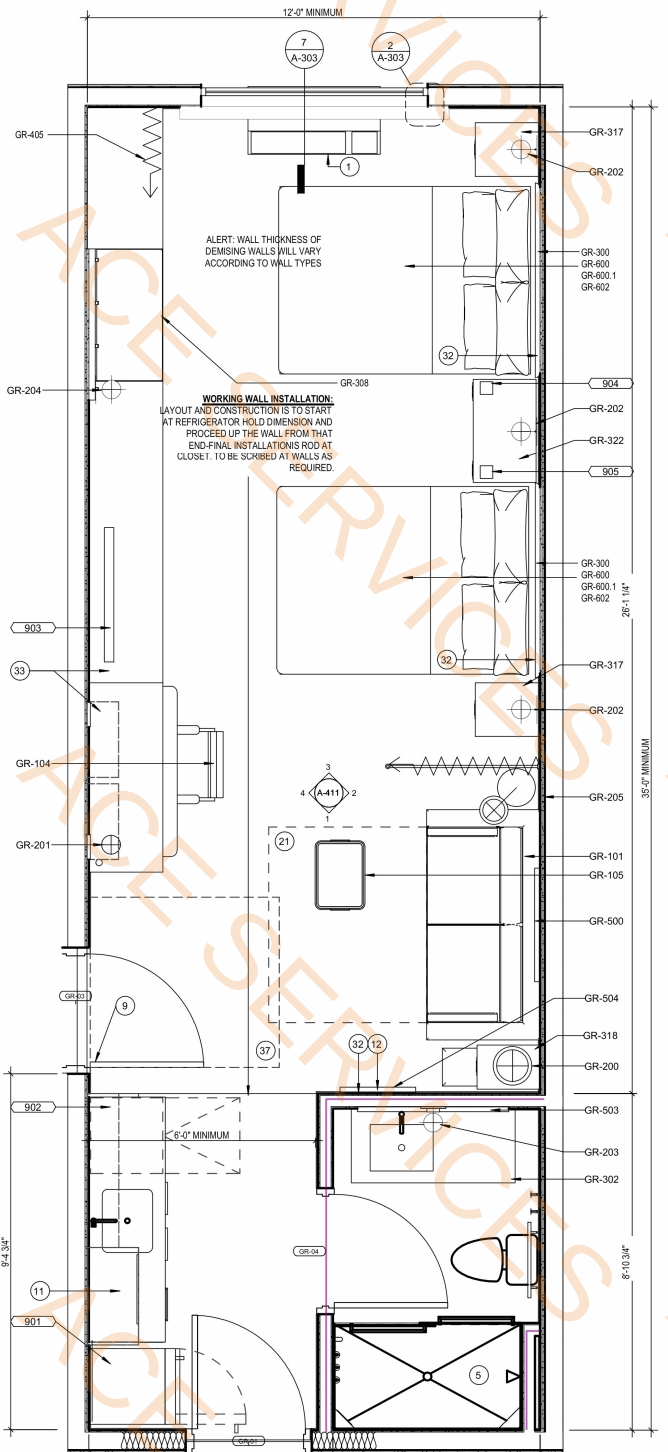

1 ARCHITECTURAL PLAN
1/2" = 1'-0"

KING STUDIO SUITE
CONNECTOR SIMILAR, TYPICAL.


Partition Wall-One Side Moisture Resistant

FINISH CODE LEGEND

PT	PART
PL	PLASTIC LAMINATE
ST	STONE
SP	SPECIAL FINISH
CONC	CONCRETE
CFT	CARPET
T	TILE
G	GLASS
QT	QUARRY TILE
B	WALL BASE
RF	RESILIENT FLOORING
WC	WALLCOVERING

NOTE:
REFER TO SEPARATE FF&E
SPECIFICATIONS MANUAL AND
SEPARATE COLOR AND
MATERIALS SPECIFICATIONS
MANUAL

CEILING DIMENSION LEGEND

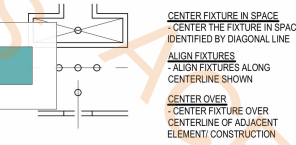

ALERT:
ELECTRICAL OUTLETS MUST FIT WITHIN THE PARTITIONED SECTION
OF MILLWORK AS INDICATED.
ELECTRICAL CONTRACTOR MUST STAGGER OUTLETS
AS PER NOTES AND DETAILS IN THESE DRAWINGS,
WHILE MAINTAINING RELATIVE POSITIONS AS SHOWN.

LEGEND - FF&E PLANS



FURNISHINGS LEGEND:

GR-101	SLEEPER SOFA	GR-600	QUEEN MATTRESS SET
GR-102	DINING CHAIR	GR-600.1	QUEEN MATTRESS SPRING COVER
GR-104	TASK CHAIR	GR-601	KING MATTRESS SET
GR-105	OTTOMAN	GR-601.1	KING BOX SPRING COVER
GR-200	TABLE LAMP	GR-602	QUEEN BED BASE
GR-201	DESK LAMP	GR-602.ADA	QUEEN ACCESSIBLE BED BASE
GR-202	NIGHTSTAND SCONCE	GR-603	KING BED BASE
GR-203	VANITY SCONCE	GR-603.ADA	KING ACCESSIBLE BED BASE
GR-204	WALL HOOK SCONCE	GR-606	ACCESSIBLE QUEEN BED SKIRT
GR-205	FLOOR LAMP	GR-607	ACCESSIBLE KING BED SKIRT
GR-206	WALL SCONCE	901	REFRIGERATOR
GR-207	TABLE LAMP	902	DISHWASHER
GR-208	NIGHTSTAND SCONCE (ADA)	903	TELEVISION
GR-300	QUEEN HEADBOARD	904	CLOCK RADIO
GR-301	KING HEADBOARD	905	TELEPHONE
GR-302	VANITY	906	QUEEN MATTRESS & BOXSPRING
GR-303	ACCESSIBLE VANITY	907	KING MATTRESS & BOXSPRING
GR-303.16	WORKING WALL	908	TUB MATTRESS & BOXSPRING
GR-317	KING NIGHTSTAND	909	SHOWER CURTAIN
GR-318	SOFA SIDE TABLE		
GR-319	DINING TABLE		
GR-322	DOUBLE QUEEN NIGHTSTAND		
GR-400	MANUAL ROLLER SHADE		
GR-401	MOTORIZED ROLLER SHADE		
GR-404	ROOM DIVIDER		
GR-405-406	CLOSET DRESSING		
GR-500	ARTWORK AT SLEEPER SOFA		
GR-503	VANITY MIRROR		
GR-504	FULL LENGTH MIRROR		

 
GENERAL NOTES - GUESTROOMS

- REFER TO FF&E PACKAGE FOR FURNITURE, BUILT-IN MILLWORK & FINISH SPECIFICATIONS.
- SMOKE DETECTORS, SPRINKLERS, AND OTHER EMERGENCY DEVICES TO BE LOCATED PER LOCAL CODE. INDICATED FOR DESIGN INTENT ONLY.
- PROVIDE EMERGENCY LIGHTING PER LOCAL CODE.
- WALL RECEPTACLE DATA PORTS TO BE MOUNTED @ 12" A.F.F. TYPICAL UNLESS NOTED OTHERWISE.
- REFER TO HOME 2 SUITES BY HILTON STANDARDS MANUAL FOR ADDITIONAL GUESTROOM, GUESTROOM BATH, GUESTROOM KITCHEN & INDOOR POOL REQ'S.
- ALL CONTROLS FOR USE BY GUESTS MUST BE MOUNTED @ 48" A.F.F. & 48" A.F.F. & PROVIDE A 30"x48" CLEAR FLOOR AREA IN COMPLIANCE WITH ACCESSIBLE STANDARDS. OPERABLE CONTROLS LOCATED OVER AN OBSTRUCTION DEEPER THAN 10" MUST BE MOUNTED NO HIGHER THAN 48" A.F.F. ACCESSIBLE CONTROLS MUST NOT REQUIRE TIGHT GRASPING, PINCHING OR TWISTING OF THE WRIST. ACCESSIBLE CONTROLS SHALL COMPLY WITH THE HADG.
- IN ACCESSIBLE ROOMS AT LEAST ONE OUTLET & DATA CONNECTION FOR USE BY GUEST MUST BE MOUNTED @ 15" & 48" A.F.F. AND PROVIDE A CLEAR FLOOR AREA IN COMPLIANCE WITH ACCESSIBLE STANDARDS. SEE HADG FOR FURTHER REQ'S.
- OBJECTS MOUNTED WITHIN THE CIRCULATION PATH IN ACCESSIBLE ROOMS @ 27" & 80" A.F.F. SHALL NOT PROTRUDE FURTHER THAN 4" FROM WALL REFER TO HADG FOR FURTHER REQ'S.
- FOR ALL ITEMS MOUNTED TO THE WALL (SHELVES, FF&E, MIRRORS, ART, ETC.), PROVIDE BLOCKING AS REQUIRED.

KEYED NOTES

- PTAC UNIT
- IN BATHROOM LOCATIONS ONLY LIGHT SWITCH EQUIPPED WITH NIGHTLIGHT MOUNTED TO TOP OF SWITCH IS 48" MAX. A.F.F.
- MANUAL BLACK OUT ROLLER SHADE TO EXTEND 6" BEYOND WINDOW OPENING. SHEER ROLLER SHADE TO BE MOUNTED INSIDE WINDOW OPENING.
- SHOWER ENCLOSURE W/ TEMPERED GLASS DOOR
- FLOOR DRAIN
- PRE-MANUFACTURED SHOWER PAN
- CEILING MOUNTED DRAPERY ROD-PROVIDE BLOCKING AS REQUIRED
- ALTERNATE LOCATION OF DOOR FOR CONNECTING ROOMS TO ACCESSIBLE ROOMS-REFER TO OVERALL PLANS FOR LOCATION OF ACCESSIBLE ROOMS
- DEDICATED CIRCUIT FOR DISHWASHER
- RANGE TOP STYLE MICROWAVE AFFIXED TO WALL
- MIRROR
- BEGIN CARPET TILE THIS SIDE W/ FULL TILE-FIRST TWO ROWS OF TILE TO BE INSTALLED AROUND BUILT-IN CASEGOODS
- SWITCH CONTROLLING GARBAGE DISPOSAL GANGED WITH DUPLEX - REFER TO HADG FOR ACCESSIBLE ROOM REQUIREMENTS.
- DEDICATED CIRCUIT FOR GARBAGE DISPOSAL
- FIRE HORN IN STANDARD ROOMS. FIRE HORN STROBE IN COMMUNICATION FEATURES ROOMS
- RECESSED CEILING LIGHT FOR WET LOCATIONS W/ SHATTER PROOF LENS
- TOILET EXHAUST GRILLE
- MAKE UP AIR DIFFUSER
- EXTENT OF SLEEPER SOFA
- APPROXIMATE LOCATIONS OF MILLWORK SUPPORTS ON FLOOR. PROVIDE SHIMS OR LEVELERS UNDER SUPPORTS TO PREVENT CARPET CRUSHING
- ROOM SIGNAGE
- HARD WIRED THERMOSTAT FOR PTAC. MOUNTED 48" MAX TO TOP OF DEVICE. COMMUNICATION BETWEEN THERMOSTAT AND PTAC MAY BE WIRELESS.
- EXTEND J-BOX, DEVICE & COVER PLATE FLUSH W/ MILLWORK BACK PANEL
- DROPPED GYPSUM BOARD BULKHEAD @ ROUGH OPENING - WHERE PRE-MANUFACTURED SHOWER INSERT IS INDICATED MEASURE ROUGH OPENING FROM FACE OF GYPSUM BOARD
- DOORBELL ON/OFF SWITCH (COMMUNICATION FEATURES ROOMS ONLY) SIGNAGE AS REQ'D.
- EDGE OF PTAC ABOVE CARPET TILES
- MIN. CEILING HEIGHT MUST BE MAINTAINED - REFER TO HOME 2 SUITES BY HILTON STANDARDS MANUAL
- FRAMING SUBCONTRACTOR TO PROVIDE 3/4" F.T. PLYWOOD BLOCKING TO RECEIVE ITEM INDICATED - EXTEND FULL LENGTH OF OBJECT
- GENERAL CONTRACTOR TO COORDINATE W/ FIXTURE FABRICATOR WHERE NECESSARY TO PROVIDE PROPER BLOCKING IN WALL FOR ITEM KEYNOTED
- SWITCHES CONTROLLING MECHANICAL SHADES - REFER TO FFE MANUAL
- OUTLET ABOVE FOR MICROWAVE - REFER TO ROOM ELEVATION MOUNT DEVICE HORIZONTALLY-FACE PLATE TO BE WHITE
- REQUIRED ACCESSIBLE CLEAR FLOOR AREA DESIGNATION
- CENTER ARTWORK OVER SOFA
- COUNTERTOP MICROWAVE
- GRAPHIC ART-REFER TO ACCESSORIES LEGEND & CONSTRUCTION PLAN
- ADDITIONAL HORN STROBE. LOCATED IN COMMUNICATION FEATURES BATHROOMS ONLY
- WAP IN 3-GANG BOX MOUNTED VERTICALLY UNDER DESK. MAINTAIN 6" BETWEEN ALL BOXES. TYP ALL GUESTROOMS. COORDINATE WAP LOCATION WITH CASEGOODS TO AVOID CONFLICTS. VISIT CONNECTEDROOM.HILTON.COM FOR CURRENT WIRELESS INTERNET REQ'S AND LIST OF APPROVED INTEGRATORS.
- EACH CABLE MUST HOMERUN BETWEEN THE GUESTROOM AND THE 10' ON EACH FLOOR. VISIT CONNECTEDROOM.HILTON.COM FOR CURRENT REQUIREMENTS AND OPTIONS.
- OPTION WIRED DATA CONNECTION FOR GUEST USE. A) ADD CAT6 RJ-45 CABLE JACK AND PATCH CORD THROUGH DESKTOP GROMMET - OR - B) PATCH CORD FROM WAP PORT THROUGH DESKTOP GROMMET.
- TV CONNECTIONS FOR FREE-TO-GUEST CONTENT: A) NO SMART TV: COAX CABLE BEHIND TV. CAT6 RJ-45 JACK BEHIND TV. RUN IN SMURF TUBE IN WALL TO WAP UNDER DESK. PATCH CORD TO EDGE CONTROLLER FOR CONNECTED ROOM. MIN. 6" CLEARANCE FROM WALL BOXES - OR - B) SMART TV-INTERNET PROTOCOL. TELEVISION (IPTV): COAX NOT REQ'D. CAT6 RJ-45 JACK BEHIND TV. RUN IN SMURF TUBE IN WALL TO WAP UNDER DESK. PATCH CORD TO EDGE CONTROLLER FOR CONNECTED ROOM. CAT6 RJ-45 JACK BEHIND TV IN ONE-BEDROOM TV. MIN. 6" CLEARANCE FROM WALL BOXES. VISIT HILTONHDTV.COM FOR ADDITIONAL INFORMATION.
- PROVIDE HINGE STOP AT DOOR
- HARDWIRED BLACK OUT ROLLER SHADE WITH NO EXPOSED WIRES
- PROVIDE OUTLET FOR UNDERCABINET LIGHTING BY OTHERS


LEGEND - GUESTROOM COMPOSITE




POWER & SIGNAL LEGEND

PLAN	ELEVATION	DESCRIPTION
⊕	⊕	OUTLET - DUPLEX
⊕	⊕	OUTLET - DUPLEX - GFI
⊕	⊕	OUTLET - QUAD
⊕	⊕	OUTLET - QUAD - GFI
⊕	⊕	PHONE
⊕	⊕	DATA
⊕	⊕	OPTIONAL DATA
⊕	⊕	OUTLET - TV
⊕	⊕	SWITCH, 3 WAY, 4 WAY
⊕	⊕	J BOX
⊕	⊕	ALARM STROBE
⊕	⊕	DOORBELL
⊕	⊕	SMOKE DETECTOR
⊕	⊕	THERMOSTAT
⊕	⊕	ALARM HORN AND STROBE
⊕	⊕	SIDE WALL SPRINKLER HEAD
⊕	⊕	SPRINKLER HEAD
⊕	⊕	SIDE WALL SPRINKLER HEAD
⊕	⊕	WAP


ENLARGED PLANS AND ELEVATIONS -
QUEEN QUEEN STUDIO SUITE ACCESSIBLE

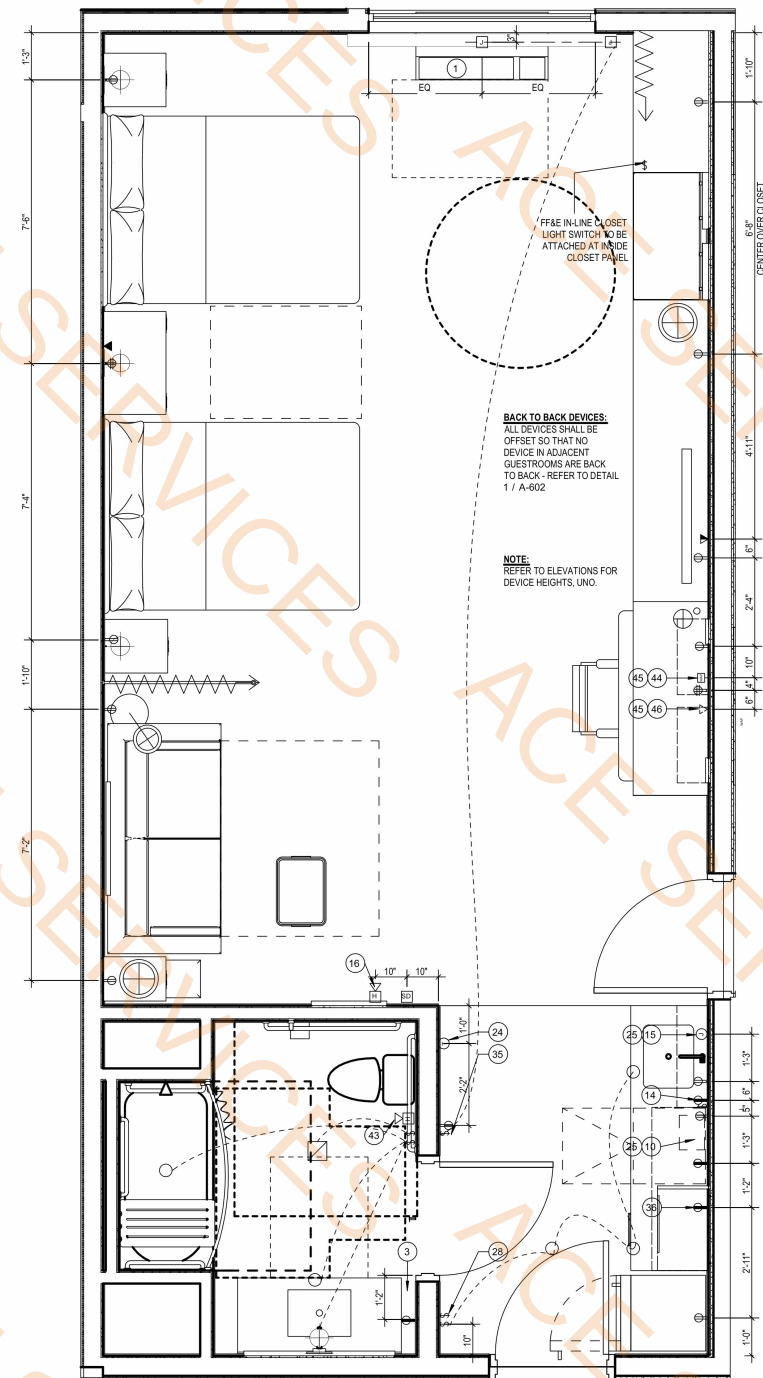

3 ELECTRICAL PLAN
1/2" = 1'-0"

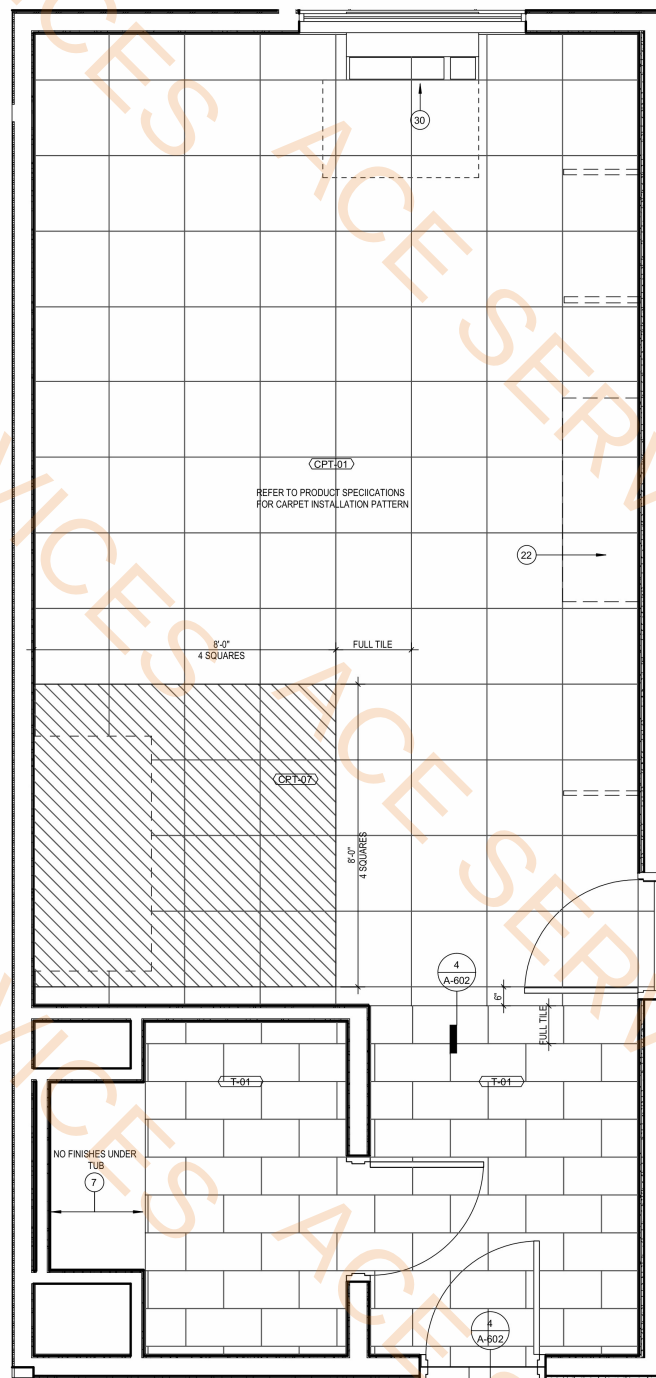

2 FINISH PLAN
1/2" = 1'-0"

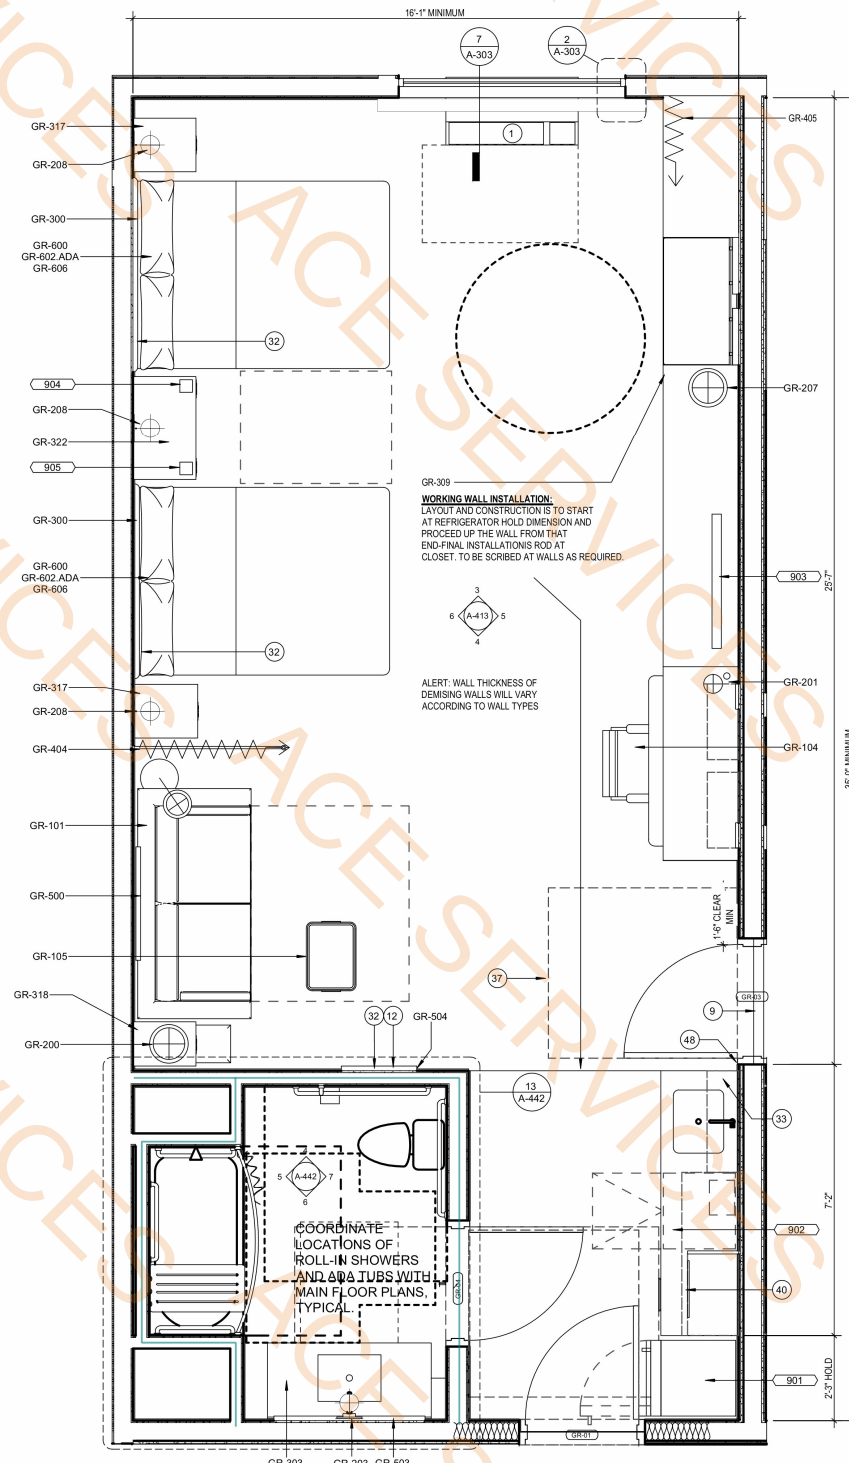


1 ARCHITECTURAL PLAN
1/2" = 1'-0"

FINISH CODE LEGEND

PT	PAINT
PL	PLASTIC LAMINATE
ST	STONE
SF	SPECIAL FINISH
CONC	CONCRETE
CPT	CARPET
T	TILE
G	GLASS
QT	QUARRY TILE
B	WALL BASE
RF	RESILIENT FLOORING
WC	WALL COVERING

NOTE:
REFER TO SEPARATE FF&E
SPECIFICATIONS MANUAL AND
SEPARATE COLOR AND
MATERIALS SPECIFICATIONS
MANUAL

CEILING DIMENSION LEGEND

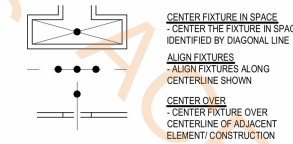

ALERT!
ELECTRICAL OUTLETS MUST FIT WITHIN THE PARTITIONED SECTION
OF MILLWORK AS INDICATED.
ELECTRICAL CONTRACTOR MUST STAGGER OUTLETS
AS PER NOTES AND DETAILS IN THESE DRAWINGS.
WHILE MAINTAINING RELATIVE POSITIONS AS SHOWN.

LEGEND - FF&E PLANS

---	XXX-XX	FURNITURE TAG
---	---	EQUIPMENT TAG

FURNISHINGS LEGEND:

GR-101	SLEEPER SOFA	GR-600	QUEEN MATTRESS SET
GR-102	DINING CHAIR	GR-601	QUEEN MATTRESS SPRING COVER
GR-104	TASK CHAIR	GR-602	KING MATTRESS SET
GR-105	OTTOMAN	GR-603	KING BOX SPRING COVER
GR-200	TABLE LAMP	GR-604	QUEEN BED BASE
GR-201	DESK LAMP	GR-605	QUEEN ACCESSIBLE BED BASE
GR-202	NIGHTSTAND SCONCE	GR-606	KING BED BASE
GR-203	VANITY SCONCE	GR-607	ACCESSIBLE QUEEN BED SKIRT
GR-204	WALL HOOK SCONCE	GR-608	ACCESSIBLE QUEEN BED SKIRT
GR-205	FLOOR LAMP	GR-609	REFRIGERATOR
GR-206	WALL SCONCE	GR-610	DISHWASHER
GR-207	TABLE LAMP	GR-611	TELEVISION
GR-208	NIGHTSTAND SCONCE (ADA)	GR-612	CLOCK/RADIO
GR-300	QUEEN HEADBOARD	GR-613	TELEPHONE
GR-301	KING HEADBOARD	GR-614	QUEEN MATTRESS & BOXSPRING
GR-302	VANITY	GR-615	KING MATTRESS & BOXSPRING
GR-303	ACCESSIBLE VANITY	GR-616	TUB SHOWER CURTAIN
GR-304	WORKING WALL	GR-617	SHOWER CURTAIN
GR-317	KING NIGHTSTAND		
GR-318	SOFA SIDE TABLE		
GR-319	DINING TABLE		
GR-322	DOUBLE QUEEN NIGHTSTAND		
GR-400	MANUAL ROLLER SHADE		
GR-401	MOTORIZED ROLLER SHADE		
GR-404	ROOM DIVIDER		
GR-405-406	CLOSET DRAPEY		
GR-500	ARTWORK AT SLEEPER SOFA		
GR-503	VANITY MIRROR		
GR-504	FULL LENGTH MIRROR		

GENERAL NOTES - GUESTROOMS

- REFER TO FF&E PACKAGE FOR FURNITURE, BUILT-IN MILLWORK & FINISH SPECS
- SMOKE DETECTORS, SPRINKLERS, AND OTHER EMERGENCY DEVICES TO BE LOCATED PER LOCAL CODE - INDICATED FOR DESIGN INTENT ONLY
- PROVIDE EMERGENCY LIGHTING PER LOCAL CODE
- WALL RECEPTACLE/ DATA PORTS TO BE MOUNTED @ 12" F.F.T. TYPICAL UNLESS OTHERWISE NOTED
- REFER TO HOME 2 SUITES BY HILTON STANDARDS MANUAL FOR ADDITIONAL GUESTROOM, GUESTROOM BATH, GUESTROOM KITCHEN & INDOOR POOL, RECIOS
- ALL CONTROLS FOR USE BY GUESTS MUST BE MOUNTED @ 48" F.F.T. & 48" A.F.F. & PROVIDE A 30"x48" CLEAR FLOOR AREA IN COMPLIANCE W/ ACCESSIBLE STANDARDS. OPERABLE CONTROLS LOCATED OVER AN OBSTRUCTION DEEPER THAN 10" MUST BE MOUNTED NO HIGHER THAN 48" A.F.F. - ACCESSIBLE CONTROLS MUST NOT REQUIRE TIGHT GRASPING, PINCHING OR TWISTING OF THE WRIST. ACCESSIBLE CONTROLS SHALL COMPLY W/ THE HADG
- IN ACCESSIBLE ROOMS AT LEAST ONE OUTLET & DATA CONNECTION FOR USE BY GUEST MUST BE MOUNTED @ 15" & 48" A.F.F. AND PROVIDE A CLEAR FLOOR AREA IN COMPLIANCE W/ ACCESSIBLE STANDARDS. SEE HADG FOR FURTHER RECS
- OBJECTS MOUNTED WITHIN THE CIRCULATION PATH IN ACCESSIBLE ROOMS @ 27" & 80" A.F.F. SHALL NOT PROTRUDE FARTHER THAN 4" FROM WALL. REFER TO HADG FOR FURTHER RECS
- FOR ALL ITEMS MOUNTED TO THE WALL (SHELVES, FF&E, MIRRORS, ART, ETC.) PROVIDE BLOCKING AS REQUIRED

KEYED NOTES

- PTAC UNIT
- IN BATHROOM LOCATIONS ONLY, LIGHT SWITCH EQUIPPED WITH NIGHTLIGHT. MOUNTED SO TOP OF SWITCH IS 48" MAX A.F.F.
- MANUAL BLACK OUT ROLLER SHADE TO EXTEND 6" BEYOND WINDOW OPENING. SHEER ROLLER SHADE TO BE MOUNTED INSIDE WINDOW OPENING
- SHOWER ENCLOSURE W/ TEMPERED GLASS DOOR
- FLOOR DRAIN
- PRE-MANUFACTURED SHOWER PAN
- CEILING MOUNTED DRAPEY ROD-PROVIDE BLOCKING AS REQUIRED
- ALTERNATE LOCATION OF DOOR FOR CONNECTING ROOMS TO ACCESSIBLE ROOMS-REFER TO OVERALL PLANS FOR LOCATION OF ACCESSIBLE ROOMS
- DEDICATED CIRCUIT FOR DISHWASHER
- RANGE TOP STYLE MICROWAVE AFFIXED TO WALL
- MIRROR
- BEGIN CARPET TILE THIS SIDE W/ FULL TILE-FIRST TWO ROWS OF TILE TO BE INSTALLED AROUND BUILT-IN CASEGOODS
- SWITCH CONTROLLING GARBAGE DISPOSAL GANGED WITH DUPLEX REFER TO HADG FOR ACCESSIBLE ROOM REQUIREMENTS.
- DEDICATED CIRCUIT FOR GARBAGE DISPOSAL
- FIRE HORN IN STANDARD ROOMS. FIRE HORN/STROBE IN COMMUNICATION FEATURES ROOMS
- RECESSED CEILING LIGHT FOR WET LOCATIONS W/ SHATTER PROOF LENS
- TOILET EXHAUST GRILLE
- MAKE-UP AIR DIFFUSER
- EXTENT OF SLEEPER SOFA
- APPROXIMATE LOCATIONS OF MILLWORK SUPPORTS ON FLOOR. PROVIDE SHIMS OR LEVELERS UNDER SUPPORTS TO PREVENT CARPET CRUSHING
- ROOM SIGNAGE
- HARD WIRED THERMOSTAT FOR PTAC. MOUNTED 48" MAX TO TOP OF DEVICE. COMMUNICATION BETWEEN THERMOSTAT AND PTAC MAY BE WIRELESS.
- EXTEND J-BOX, DEVICE & COVER PLATE FLUSH W/ MILLWORK BACK PANEL
- DROPPED GYPSUM BOARD BULKHEAD @ ROUGH OPENING - WHERE PRE-MANUFACTURED SHOWER INSERT IS INDICATED MEASURE ROUGH OPENING FROM FACE OF GYPSUM BOARD
- DOORBELL ON/OFF SWITCH (COMMUNICATION FEATURES ROOMS ONLY) SIGNAGE AS REQD.
- EDGE OF PTAC ABOVE CARPET TILES
- MIN. CEILING HEIGHT MUST BE MAINTAINED - REFER TO HOME 2 SUITES BY HILTON STANDARDS MANUAL
- FRAMING SUBCONTRACTOR TO PROVIDE 3/4" F.R.T. PLYWOOD BLOCKING TO RECEIVE ITEM INDICATED - EXTEND FULL LENGTH OF OBJECT
- GENERAL CONTRACTOR TO COORDINATE W/ FIXTURE FABRICATOR WHERE NECESSARY TO PROVIDE PROPER BLOCKING IN WALL FOR ITEM KEYNOTED
- SWITCHES CONTROLLING MECHANICAL SHADES - REFER TO FFE MANUAL
- OUTLET ABOVE FOR MICROWAVE - REFER TO ROOM ELEVATION MOUNT DEVICE HORIZONTALLY-FACE PLATE TO BE WHITE
- REQUIRED ACCESSIBLE CLEAR FLOOR AREA DESIGNATION
- CENTER ARTWORK OVER SOFA
- COUNTERTOP MICROWAVE
- GRAPHIC ART. REFER TO ACCESSORIES LEGEND & CONSTRUCTION PLAN
- ADDITIONAL HORN STROBE LOCATED IN COMMUNICATION FEATURES BATHROOMS ONLY
- WAP IN 3-GANG BOX MOUNTED VERTICALLY UNDER DESK. MAINTAIN 6" BETWEEN ALL BOXES. TYP ALL GUESTROOMS. COORDINATE WAP LOCATION WITH CASEGOODS TO AVOID CONFLICTS. VISIT CONNECTEDROOM.HILTON.COM FOR CURRENT WIRELESS INTERNET RECS AND LIST OF APPROVED INTEGRATORS.
- EACH CABLE MUST HOMERUN BETWEEN THE GUESTROOM AND THE IDF ON EACH FLOOR. VISIT CONNECTEDROOM.HILTON.COM FOR CURRENT REQUIREMENTS AND OPTIONS.
- OPTION WIRE DATA CONNECTION FOR GUEST USE. A) ADD CAT6 RJ-45 CABLE JACK AND PATCH CORD THROUGH DESKTOP GROMMET - OR - B) PATCH CORD FROM WAP PORT THROUGH DESKTOP GROMMET.
- TV CONNECTIONS FOR FREE-TO-GUEST CONTENT: A) NO SMART TV: COAX CABLE BEHIND TV. CAT6 RJ-45 JACK BEHIND TV. RUN IN SHURF TUBE IN WALL TO WAP UNDER DESK. PATCH CORD TO EDGE CONTROLLER FOR CONNECTED ROOM. MIN. 6" CLEARANCE FROM WALL BOXES - OR - B) SMART TV-INTERNET PROTOCOL TELEVISION (IPTV): COAX NOT REQD. CAT6 RJ-45 JACK BEHIND TV RUN IN SHURF TUBE IN WALL TO WAP UNDER DESK. PATCH CORD TO EDGE CONTROLLER FOR CONNECTED ROOM. CAT6 RJ-45 JACK BEHIND TV IN ONE-BEDROOM TV. MIN. 6" CLEARANCE FROM WALL BOXES. VISIT HILTONTV.COM FOR ADDITIONAL INFORMATION.
- PROVIDE HINGE STOP AT DOOR
- HARDWIRED BLACK OUT ROLLER SHADE WITH NO EXPOSED WIRES
- PROVIDE OUTLET FOR UNDERCABINET LIGHTING BY OTHERS

LEGEND - GUESTROOM COMPOSITE

CARPET TILE	FLOOR TILE	FINISH MATERIAL EXTENTS


POWER & SIGNAL LEGEND

PLAN	ELEVATION	DESCRIPTION
		OUTLET - DUPLEX
		OUTLET - DUPLEX - GFI
		OUTLET - QUAD
		OUTLET - QUAD - GFI
		PHONE
		DATA
		OPTIONAL DATA
		OUTLET - TV
		SWITCH, 3 WAY, 4 WAY
		J BOX
		ALARM STROBE
		DOORBELL
		SMOKE DETECTOR
		THERMOSTAT
		ALARM HORN AND STROBE
		SIDE WALL SPRINKLER HEAD
		SPRINKLER HEAD
		SIDE WALL SPRINKLER HEAD
		WAP


ENLARGED PLANS AND ELEVATIONS -
QUEEN QUEEN STUDIO SUITE ACCESSIBLE

- 5/8" Type "X" Gypsum Borad Ceiling- PT07
- 5/8" Type "X" Moisture Resistant Gypsum Borad Ceiling- PT07


490.9 SQ FT
63.9 SQ FT

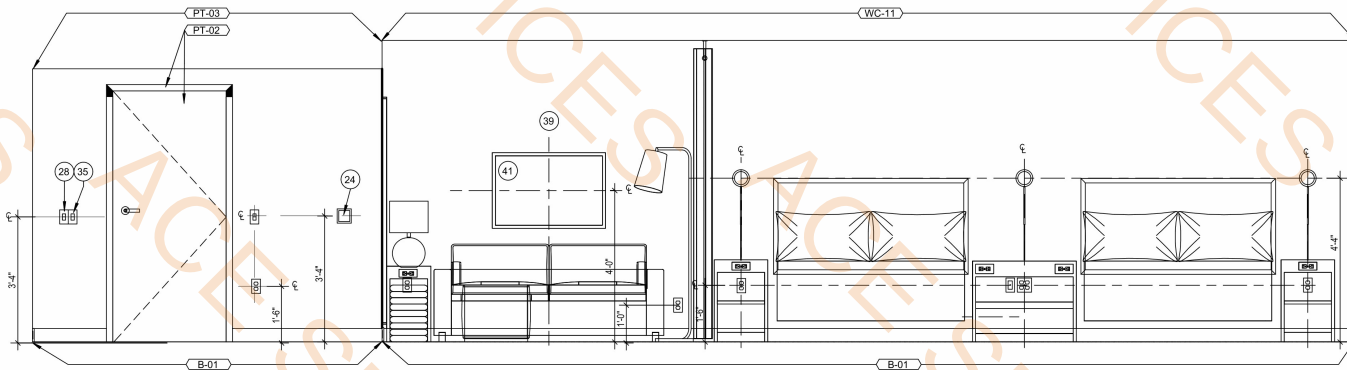


6 HEADBOARD
1/2" = 1'-0"

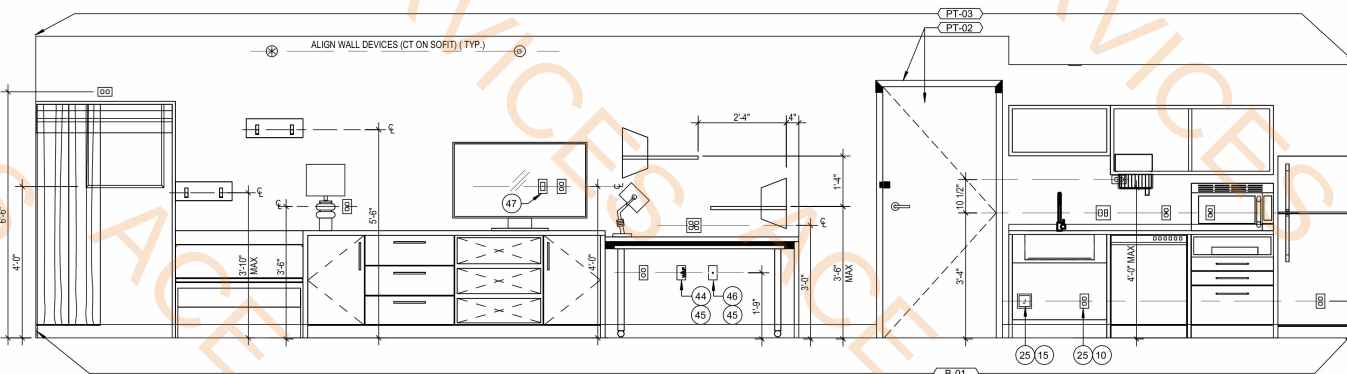


5 WORKING WALL
1/2" = 1'-0"

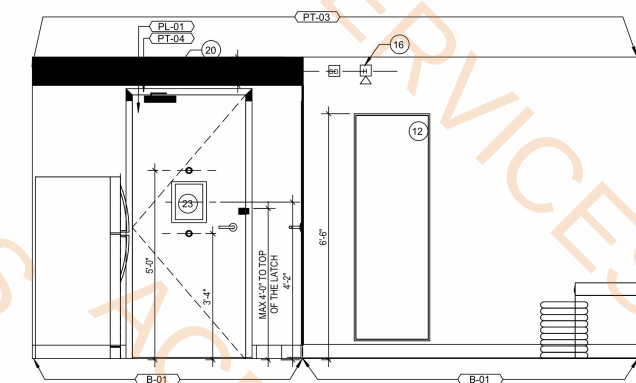


4 ENTRY
1/2" = 1'-0"

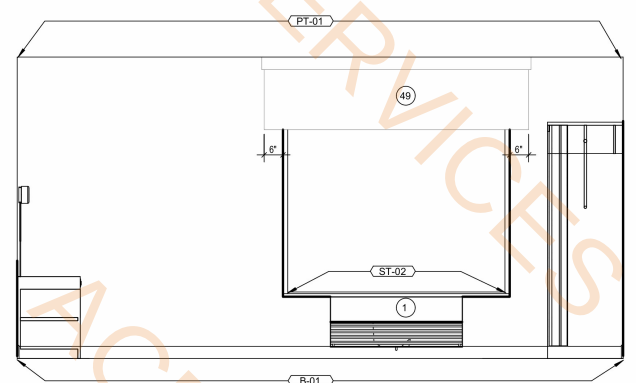


3 WINDOW
1/2" = 1'-0"

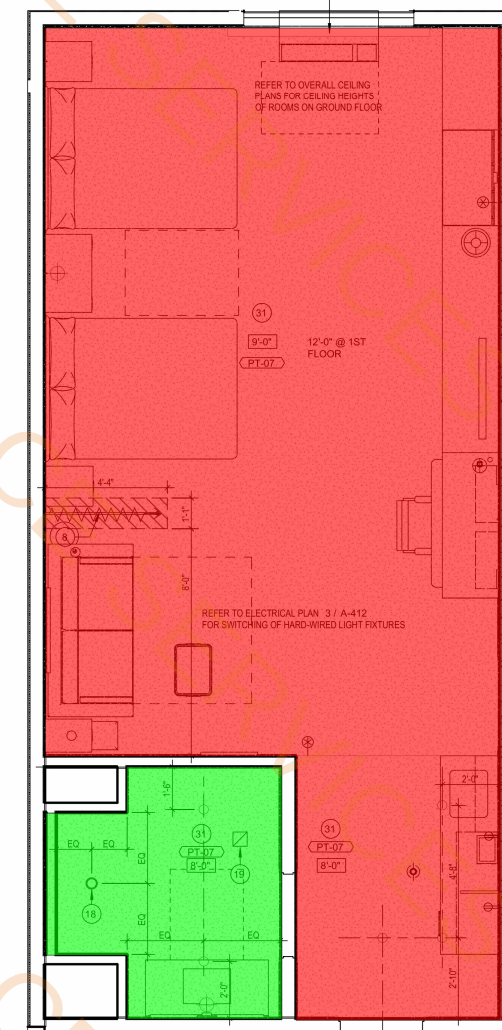

1 REFLECTED CEILING PLAN
3/8" = 1'-0"

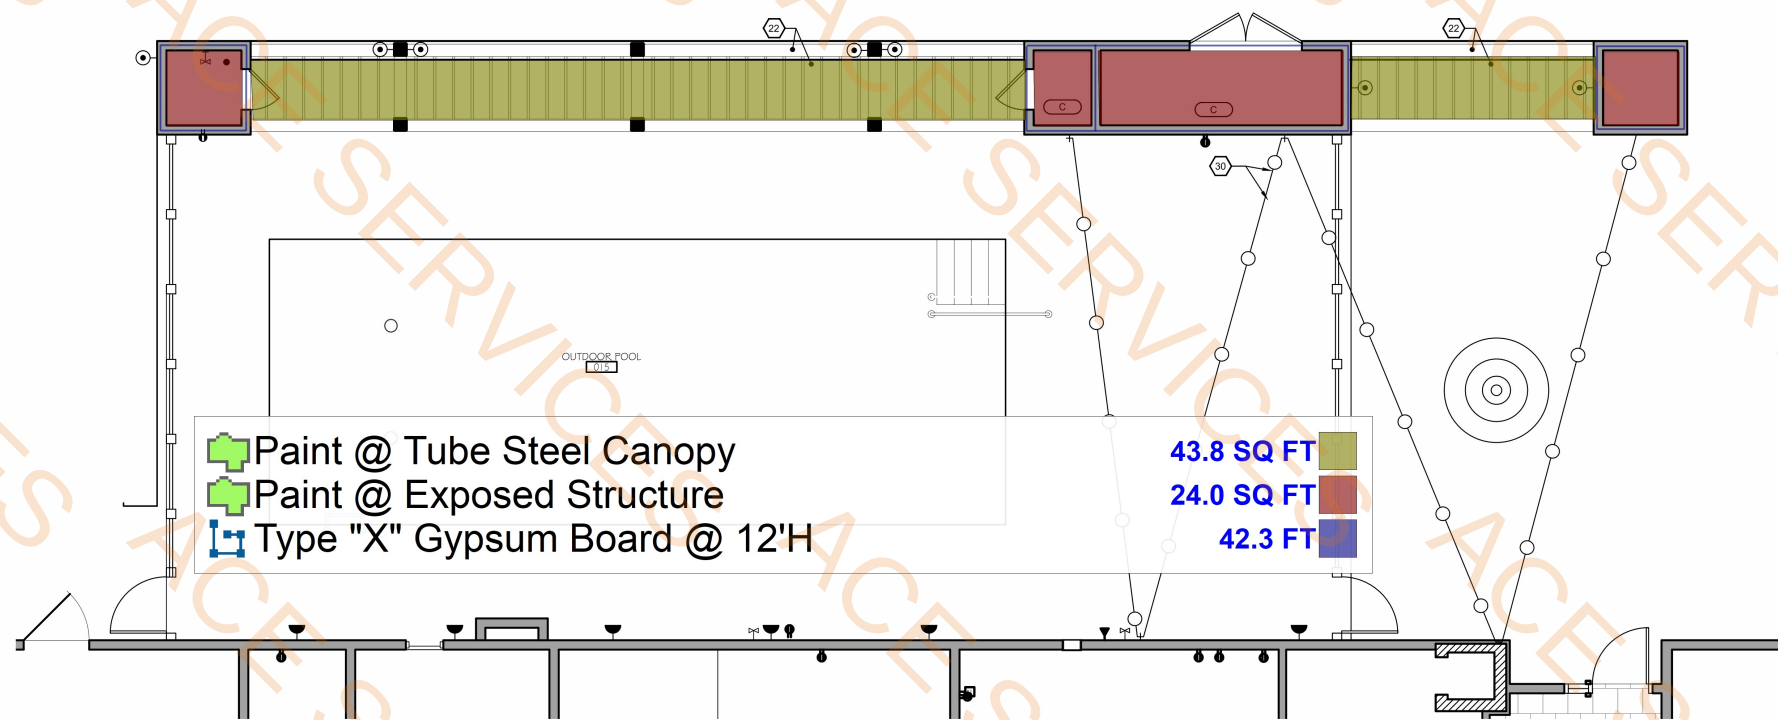

ENLARGED CEILING AND POWER PLAN - EXTERIOR POOL
SCALE: 1/2" = 1'-0"

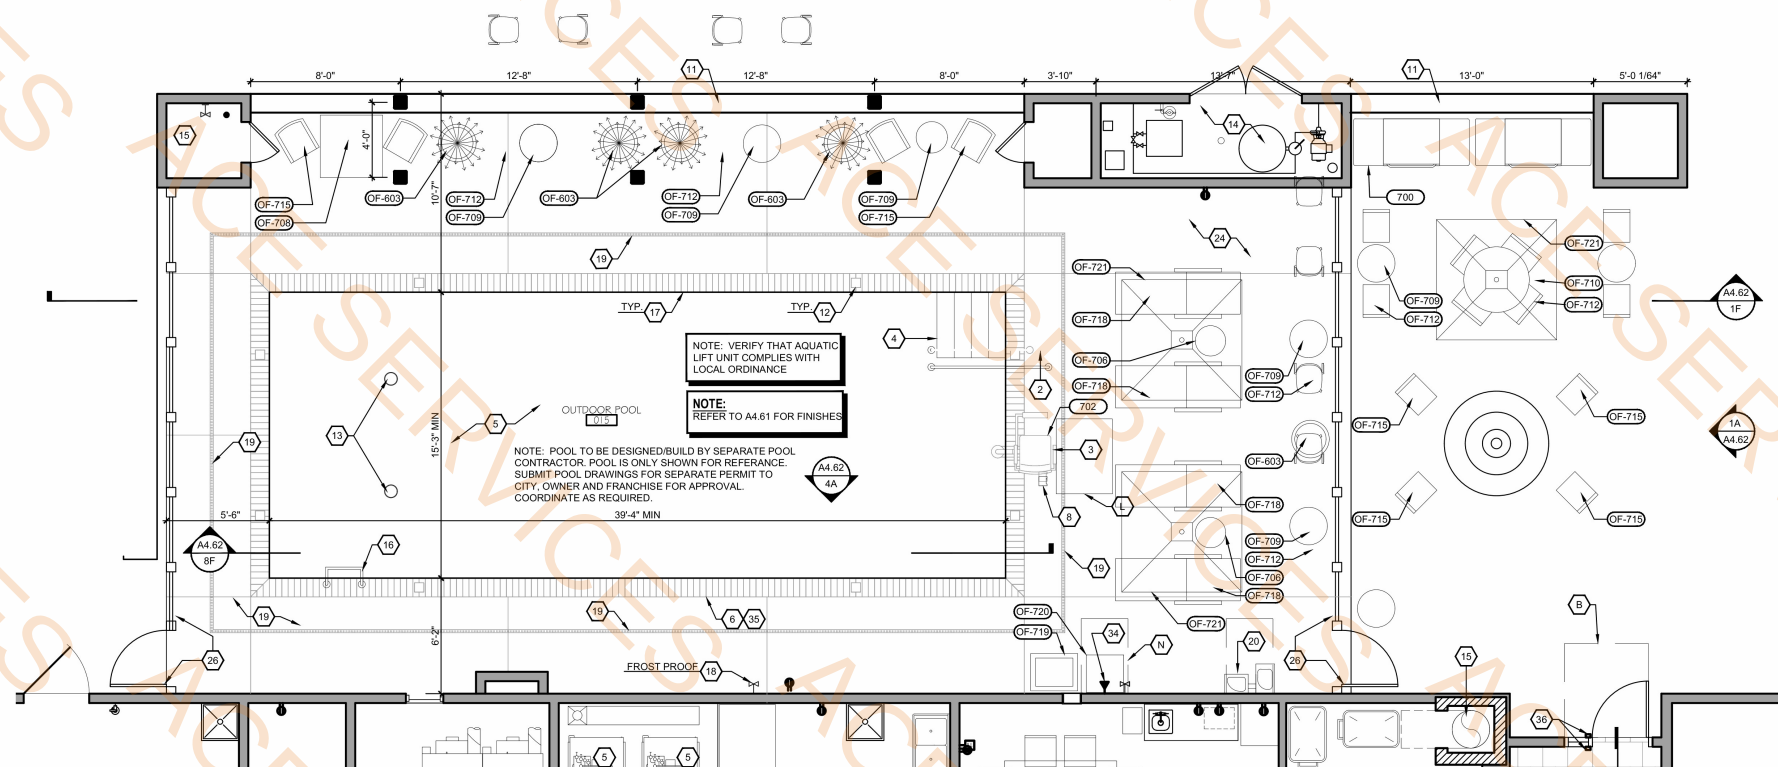

ENLARGED CONSTRUCTION AND FURNITURE PLAN - EXTERIOR POOL
SCALE: 1/2" = 1'-0"

FURNISHINGS LEGEND:	
OF-603	PLANTER
OF-709	SIDE TABLE
OF-709	TABLE
OF-710	DINING UMBRELLA TABLE
OF-711	COUNTER TABLE
OF-712	DINING CHAIR
OF-713	COUNTER STOOL
OF-714	COUNTER STOOL
OF-715	DINING CHAIR
OF-716	CHANCE
OF-717	TOWEL RACK/BIN
OF-718	TOWEL BIN
OF-721	UMBRELLA
700	GAS GRILL
701	TREE GRATE
702	AQUATIC LIFT

POWER AND SIGNAL LEGEND:	
PLAN:	
POWER OUTLET	
QUAD OUTLET	
GFI OUTLET	
DATA OUTLET	
VOICE OUTLET	
TV DEVICE WITH HSA CONNECTION	
SMOKE DETECTOR	
ENERGY SAVER PANEL / KEY TAG	
TO EMERGENCY CONTROLS DEVICES (GANGED AT SPANEL)	
TO ELEVATOR CONTROLS DEVICES	
CENTERLINE OF ACCESSIBLE FLOOR IDENTIFICATION SIGNAGE - LOCATE (1) ON EACH LOBBY DOOR JAMB, EVERY FLOOR, EVERY ELEVATOR	
TO ELEVATOR JAMB SIGNAGE	
FLOOR MOUNTED JUNCTION BOX	
FLOOR MOUNTED FLOOR OUTLET BOX	
FIRE SPEAKER	

KEY NOTES:	
1	FLUSH MOUNTED SPOONER RATES FOR DAMP ENVIRONMENTS
2	STAINLESS STEEL HANDRAIL TO COMPLY WITH ACCESSIBILITY REQUIREMENTS
3	PROVIDE A FIXED POOL LIFT TO PROVIDE AN ACCESSIBLE MEANS OF ENTRY TO THE POOL. PROVIDE LIFT LOCATION TO COMPLY WITH ACCESSIBILITY STANDARDS. REFER TO HAOG FOR FURTHER REQS.
4	STAR ENTRY TO POOL TO COMPLY WITH ACCESSIBILITY REQUIREMENTS
5	SWIMMING POOL
6	JOINTS WHERE THE DECK MEET THE POOL MUST BE WATERTIGHT
7	STAINLESS STEEL HVAC DUCT
8	FLUSH BOX HYDRANT
9	RECESSED C.G. LIGHT FOR WET LOCATIONS W/ SHATTER PROOF LENSES
10	EXPOSED WOOD CEILING STRUCTURE OVER POOL, GLULAM BEAMS WITH 6" GLOSS CLEAR COAT WITH TAG DECOR
11	PARTIAL HEIGHT WALL W/ PRECAST CORING - REFER TO ELEV.
12	POOL DEPTH MARKERS AS REQUIRED BY CODE. INSERT FLUSH WITH POOL COPING. DECK LOCATION ALSO INDICATES CORRESPONDING POOL WALL TILE LOCATION. DECK AND WALL TILES TO BE ALIGNED. POOL CONTRACTOR TO VERIFY POOL DEPTHS PRIOR TO INSTALLING TILES
13	POOL BOTTOM DRAIN
14	POOL EQUIPMENT
15	POOL CHEMICAL CLOSET - EVERYTHING IN THIS ROOM TO BE RATED FOR CORROSIVE ENVIRONMENTS (DOOR, DOOR FRAME AND HANDRAILS, PIPES, PIPE SUPPORTS, SHELVES, LIGHTS, ETC.)
16	LADDER
17	BRICK COPING AT PERIMETER OF POOL
18	TAMPER RESISTANT, RECESSED HOSE BIBB - MOUNT TOP AT +12' A.F.F.
19	SLOPE POOL DECK TOWARD AREA DRAIN EXTEND WATERPROOFING OVER STRUCTURE, BEAM AND INTO LOWER BODY OF DRAIN. SLOPE OF POOL DECK NOT TO EXCEED 1/4" (1/4" RECOMMENDED) IN EITHER DIRECTION PER ACCESSIBILITY REQUIREMENTS
20	DRAINING FOUNTAINS, LEADING EDGES OF BOTH ACCESSIBLE AND NON-ACCESSIBLE FOUNTAINS SHOULD BE NO HIGHER THAN 2" PER ACCESSIBILITY REQUIREMENTS
21	SURFACE MOUNTED DOWNLIGHT - RUN EXPOSED POWER SUPPLY CONDUIT UP TIGHT AGAINST CORNER OF DECKING AND BEAM TO MINIMIZE SIGHT LINES
22	PRIMED AND PAINTED TUBE STEEL CANOPY WITH STAINED WOOD TRELLIS IN-TILE - SYSTEM TO BE UPLIGHTED BY SPOONERS
23	UNDERWATER LIGHTING - WATERTIGHT PER LOCAL CODE
24	DECKS MUST BE INSTALLED W/ RELIEF JOINTS FOR THERMAL MOVEMENT & POTENTIAL SETTLING
25	PROVIDE CONT. VAPOR BARRIER BEHIND POOL CEILING FINISHES
26	POOL PERIMETER FENCE AS REQUIRED BY CODE W/ 3'-0" GATE
27	EDGE OF POOL BELOW DASHED IN FOR REFERENCE
28	SLOPE CONCRETE DECK AWAY FROM BUILDING. SLOPE OF POOL DECK NOT TO EXCEED 1/4" (1/4" RECOMMENDED) IN EITHER DIRECTION PER ACCESSIBILITY REQUIREMENTS
29	WALL RETURN GRILLE - REFER TO ELEVATIONS
30	EXTERIOR LIGHT STRING - ENSURE THAT ADEQUATE BLOCKING IS PROVIDED FOR STRING LIGHTS
31	GY. 80, VEE REVEAL
32	ROOF MOUNTED EXHAUST FAN GRILLE
33	EXPANSION JOINT IN COPING 10" MAX SEPARATION
34	HOUSE TELEPHONE LOCATION
35	JOINTS WHERE THE POOL OR WHIRLPOOL COPING MEETS THE DECK MUST BE PROTECTED FROM THE RELATIVE PRESSURE OF ADJOINING DECK MOVEMENT
36	EXTERIOR POOL REQUIRES INTERIOR AND EXTERIOR CARD READER ACCESS FOR BUILDING SECURITY AND POOL SAFETY

ACCESSIBILITY NOTES:	
DESIGNATED RECD CLEAR FLOOR SPACE PER ACCESSIBILITY	
RECD. REFER TO DETAIL ON SHEET A2.01 IN REFERENCE TO DOOR APPROACH CLEARANCES. VERIFY RECD CLEAR FLOOR SPACE FOR ALL ACCESSIBLE EQUIPMENT, FURNITURE & AREAS AS DEFINED BY ACCESSIBILITY. AS INDICATED WITH A LETTER KEYNOTE. REFER TO HAOG FOR FURTHER INFO.	

CEILING - FIXTURE LEGEND: SYMBOLS ARE NOT TO SCALE	
--	--

DECORATIVE WALL SCONCE - REFER TO FF&E PACKAGE	
DECORATIVE ROUND SUSPENDED LIGHT FIXTURE - REFER TO FF&E PACKAGE	
DECORATIVE SQUARE SURFACE MOUNT LIGHT FIXTURE - REFER TO FF&E PACKAGE	
DECORATIVE SUSPENDED LIGHT FIXTURE - REFER TO FF&E PACKAGE	
(R-1) RECESSED DOWNLIGHT	
(R-2) RECESSED WALL WASH	
(R-3) RECESSED DOWNLIGHT W/ LENS (FLUORESCENT LAMP) - UL WET LABELED	
(R-4) SMALL RECESSED DOWNLIGHT (HALOGEN LAMP) NARROW BEAM SPREAD	
(R-5) SURFACE MOUNTED FIXTURE	
(R-7) EXT. RECESSED DOWNLIGHT WALL WASHER - (UL WET LABEL)	
(T-1) 2X2 LAY-IN FLUORESCENT FIXTURE	
(T-2) 2X4 LAY-IN FLUOR. FIXTURE	
(T-3) 3X4 SURFACE MOUNTED FLUORESCENT FIXTURE	
(C-1) RECESSED FLUORESCENT COVE FIXTURE - 4FT	
(W-1) WALL MOUNTED STRIP LIGHT - 4FT	
(S-1) WALL SCONCE @ POOL AREA (UL WET LABEL)	
(S-2) WALL SCONCE @ REAR ENTRY (UL WET LABEL)	
(S-3) EXTERIOR SCONCE (UPLIGHT)	
(S-5) EXTERIOR FLOODLIGHT	
(O-1) EXTERIOR HEAVY DUTY LIGHT STRING	
SPEAKER	
MECHANICAL EXHAUST GRILLE	
2X2 MECHANICAL RETURN GRILLE	
2X2 MECHANICAL SUPPLY GRILLE	
MECHANICAL SUPPLY GRILLE	
MECHANICAL RETURN GRILLE	
SMOKE DETECTOR	
SPRINKLER HEAD	
SIDE WALL SPRINKLER HEAD	
'VEE' CONTROL JOINT	
(P-3) IN-GROUND UPLIGHT	

FINISHES LEGEND:	
PT	PAINT
PL	PLASTIC LAMINATE
ST	STONE
SP	SPECIAL FINISH
CO	CONCRETE
CP	CARPET
CT	TILE
G	GLASS
Q	QUARRY TILE
VB	VINYL BASE
VCT	VINYL FLOORING
WC	WALLCOVERING

CEILING LEGEND:	
C	CEILING HEIGHT
C-X	CEILING FINISH
A	PRIMED & PAINTED GYPSUM BOARD - MOISTURE RESISTANT
B	PRIMED & PAINTED GYPSUM BOARD - MOISTURE RESISTANT
C	OPEN TO UNDERSIDE OF FLOOR / ROOF SYSTEM ABOVE - PAINT ALL ELEMENTS - ELEVATION INDICATED MAY BE APPROXIMATE & FOR GEN. REF. ONLY - REFER TO SECTIONS
D	3X4 LAY-IN ACoustical C.G. TILE SUSPENDED FROM STRUCT.
E	3X4 LAY-IN CEILING GRID SYSTEM SUSPENDED FROM STRUCTURE - INFILLED WITH 1/2" VINYL FACED GYPSUM BOARD PANELS
F	UNDERSIDE OF FLOOR / ROOF SYSTEM - PRIMED & PAINTED TO RECEIVE FINAL FINISH

GENERAL NOTES:	
1	REFER TO FF&E PACKAGE FOR FURNITURE, BUILT-IN MILLWORK & FINISH UPRES.
2	SMOKE DETECTORS & OTHER EMERGENCY DEVICES TO BE LOCATED PER LOCAL CODE
3	PROVIDE EMERGENCY LIGHTING PER LOCAL CODE
4	WALL DEVICES TO BE MOUNTED AT 18" A.F.F. TYPICAL UNLESS NOTED OTHERWISE
5	REFER TO HAOG 2.01 BY THE TON STANDARDS MANUAL FOR ADDITION GUESTROOM, GUESTROOM BATH, GUESTROOM KITCHEN & HOOKUP POOL DECK
6	POOL ENCLOSURE TO BE SEPARATED FROM THE REST OF THE BLDG. BY A VAPOR BARRIER ON THE POOL SIDE OF THE WALL. LOCATE POOL AREA EXTERIOR WALL VAPOR BARRIER ON THE POOL SIDE OF THE WALL. CARE MUST BE TAKEN TO AVOID MOISTURE BUILD-UP IN THE WALL OR CEILING CAVITY. ANY PENETRATIONS OF THE BARRIER MUST BE MINIMIZED.