


PROJECT RELEASE DATE:
AUGUST 8, 2025

THE JOE WEBB MEMORIAL BRANCH LIBRARY
FOR
THE CLAIBORNE PARISH LIBRARY
HAYNESVILLE, LOUISIANA

LOCATED AT
1337, 1345 & 1363 MAIN STREET
HAYNESVILLE, LOUISIANA

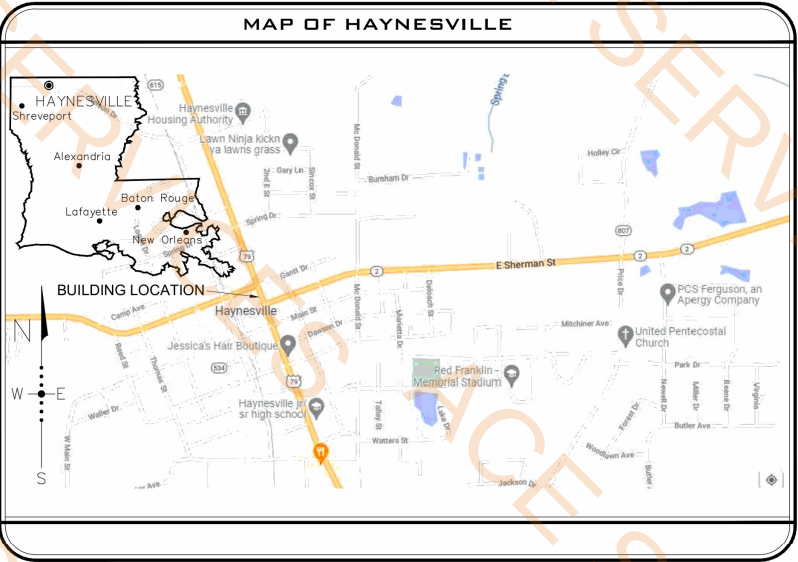

ACKNOWLEDGMENTS

CLAIBORNE PARISH LIBRARY BOARD OF CONTROL

DENICE OWENS, PRESIDENT
DIANNE SPIGENER, VICE PRESIDENT
FRANK T. SPEER, TREASURER
TRUDY W. CLARK
PATRICIA E. DAVIS
SANDRA HINES
SCOTT DAVIDSON, EX OFFICIO
PAM SUGGS, LIBRARY DIRECTOR

CLAIBORNE PARISH POLICE JURY

SCOTT DAVIDSON, PRESIDENT - DISTRICT 6
MARK FURLOW, VICE PRESIDENT - DISTRICT 2
LARRY FORD, DISTRICT 1
KEVIN GRAY, DISTRICT 3
MARY McDANIEL, DISTRICT 4
PAUL R. COOK, DISTRICT 5
JOSEPH MERRITT, JR., DISTRICT 7
MALCOM COOPER, DISTRICT 8
GIL DOWLES, DISTRICT 9
WILLIE J. YOUNG, SR., DISTRICT 10
DWAYNE R. WOODARD, SECRETARY-TREASURER

INDEX OF DRAWINGS

- ARCHITECTURAL DRAWINGS:**
COVER SHEET
C1.1 EXISTING SITE SURVEY
A1.1 PROPOSED SITE PLAN
A1.2 SITE DETAILS
A2.1 PROPOSED FLOOR PLAN
A3.1 INTERIOR FINISHES & OPENING SCHEDULES
A3.2 OPENING ELEVATIONS & DETAILS
A3.3 OPENING DETAILS
A4.1 PROPOSED EXTERIOR ELEVATIONS
A4.2 PROPOSED EXTERIOR ELEVATIONS
A5.1 BUILDING SECTIONS
A5.2 BUILDING SECTION & DETAILS
A5.3 TYPICAL WALL SECTIONS
A6.1 INTERIOR ELEVATIONS
A6.2 INTERIOR ELEVATIONS
A6.3 MILLWORK & DETAILS
A7.1 REFLECTED CEILING PLAN
A7.2 FURNITURE & EQUIPMENT PLAN
A7.3 ROOF FRAMING PLAN
- STRUCTURAL DRAWINGS:**
S2.1 FOUNDATION PLAN & DETAILS
S2.2 FOUNDATION DETAILS
- MECHANICAL DRAWINGS:**
M2.1 MECHANICAL PLAN & NOTES
M3.1 MECHANICAL SCHEDULES
M4.1 MECHANICAL DETAILS
- PLUMBING DRAWINGS:**
P1.1 PLUMBING SITE PLAN
P2.1 PLUMBING PLAN
P3.1 PLUMBING SCHEDULES
P4.1 PLUMBING DETAILS
- ELECTRICAL DRAWINGS:**
E1.1 ELECTRICAL SITE PLAN
E2.1 ELECTRICAL LIGHTING PLAN & FIXTURE SCHEDULE
E3.1 ELECTRICAL POWER PLAN & DETAILS
E4.1 ELECTRICAL LEGEND & PANEL SCHEDULE

BUILDING SUMMARY

APPLICABLE CODES: INTERNATIONAL BUILDING CODE - 2012 EDITION NFPA 101 - LIFE SAFETY CODE - 2012 EDITION AMERICANS WITH DISABILITIES ACT - ACC. GUIDELINES - 2010 EDITION LOUISIANA STATE PLUMBING CODE - 2000 EDITION	
BUILDING AREA: TOTAL AREA 3,703 SQ. FT.	
CONSTRUCTION TYPE & ALLOWABLE AREA: (IBC) TYPE II - B - NON-SPRINKLED - GROUP A-3 (NFPA) TYPE III-000 - NON-SPRINKLED	
ALLOWABLE AREA = 9,500 SQ. FT. (PER STORY)	ACTUAL 9,500 SQ. FT.
ALLOWABLE HEIGHT = 55' (FEET ABOVE GRADE PLANE)	25'-0"
STRUCTURAL FRAME	0 HOUR FIRE RATING
BEARING WALLS (INTERIOR & EXTERIOR)	0 HOUR FIRE RATING
FLOOR-CEILING ASSEMBLIES	0 HOUR FIRE RATING
ROOF-CEILING ASSEMBLIES	0 HOUR FIRE RATING
OCCUPANT LOAD: IBC: ASSEMBLY GROUP A-3 (LIBRARY)	
LIBRARY STACK AREA (100 GROSS)	10 PERSONS
LIBRARY READING AREA (50 GROSS)	5 PERSONS
ASSEMBLY AREA (7 NET)	160 PERSONS
IBC TOTAL = 175 PERSONS	
NFPA: ASSEMBLY USE	
LIBRARY STACK AREA (100 GROSS)	10 PERSONS
LIBRARY READING AREA (50 NET)	5 PERSONS
UNCONCENTRATED ASSEMBLY AREA (15 NET)	160 PERSONS
NFPA TOTAL = 175 PERSONS	

MECH & ELEC ENGINEER



ASSOCIATED DESIGN
GROUP, INC.
CONSULTING ENGINEERS

3909 W. CONGRESS ST. - SUITE 201
LAFAYETTE, LOUISIANA 70506
(337) 234-5710 / FAX (337) 237-1467

ARCHITECT



Coco & Company

WAYNE LAWRENCE COCO, AIA,
ARCHITECT, L.L.C.


P.O. BOX 111 - 510 MAIN ST.
SIMMESPORT, LA 71369
(318) 941-2392 / FAX (318) 941-2821



Project No. 0024
Drawn By: BP
Approved By: WAYNE L. COCO
Preliminary Date: 06.08.2025
Release Date: 06.08.2025
File:

WAYNE LAWRENCE COCO, AIA, ARCHITECT, L.L.C.
P.O. BOX 111 - 510 MAIN ST.
SIMMESPORT, LOUISIANA 71369
(318) 941-2392 / FAX (318) 941-2821
Coco & Company
a professional architectural company

THE JOE WEBB MEMORIAL BRANCH LIBRARY
FOR
THE CLAIBORNE PARISH LIBRARY
HAYNESVILLE, LOUISIANA

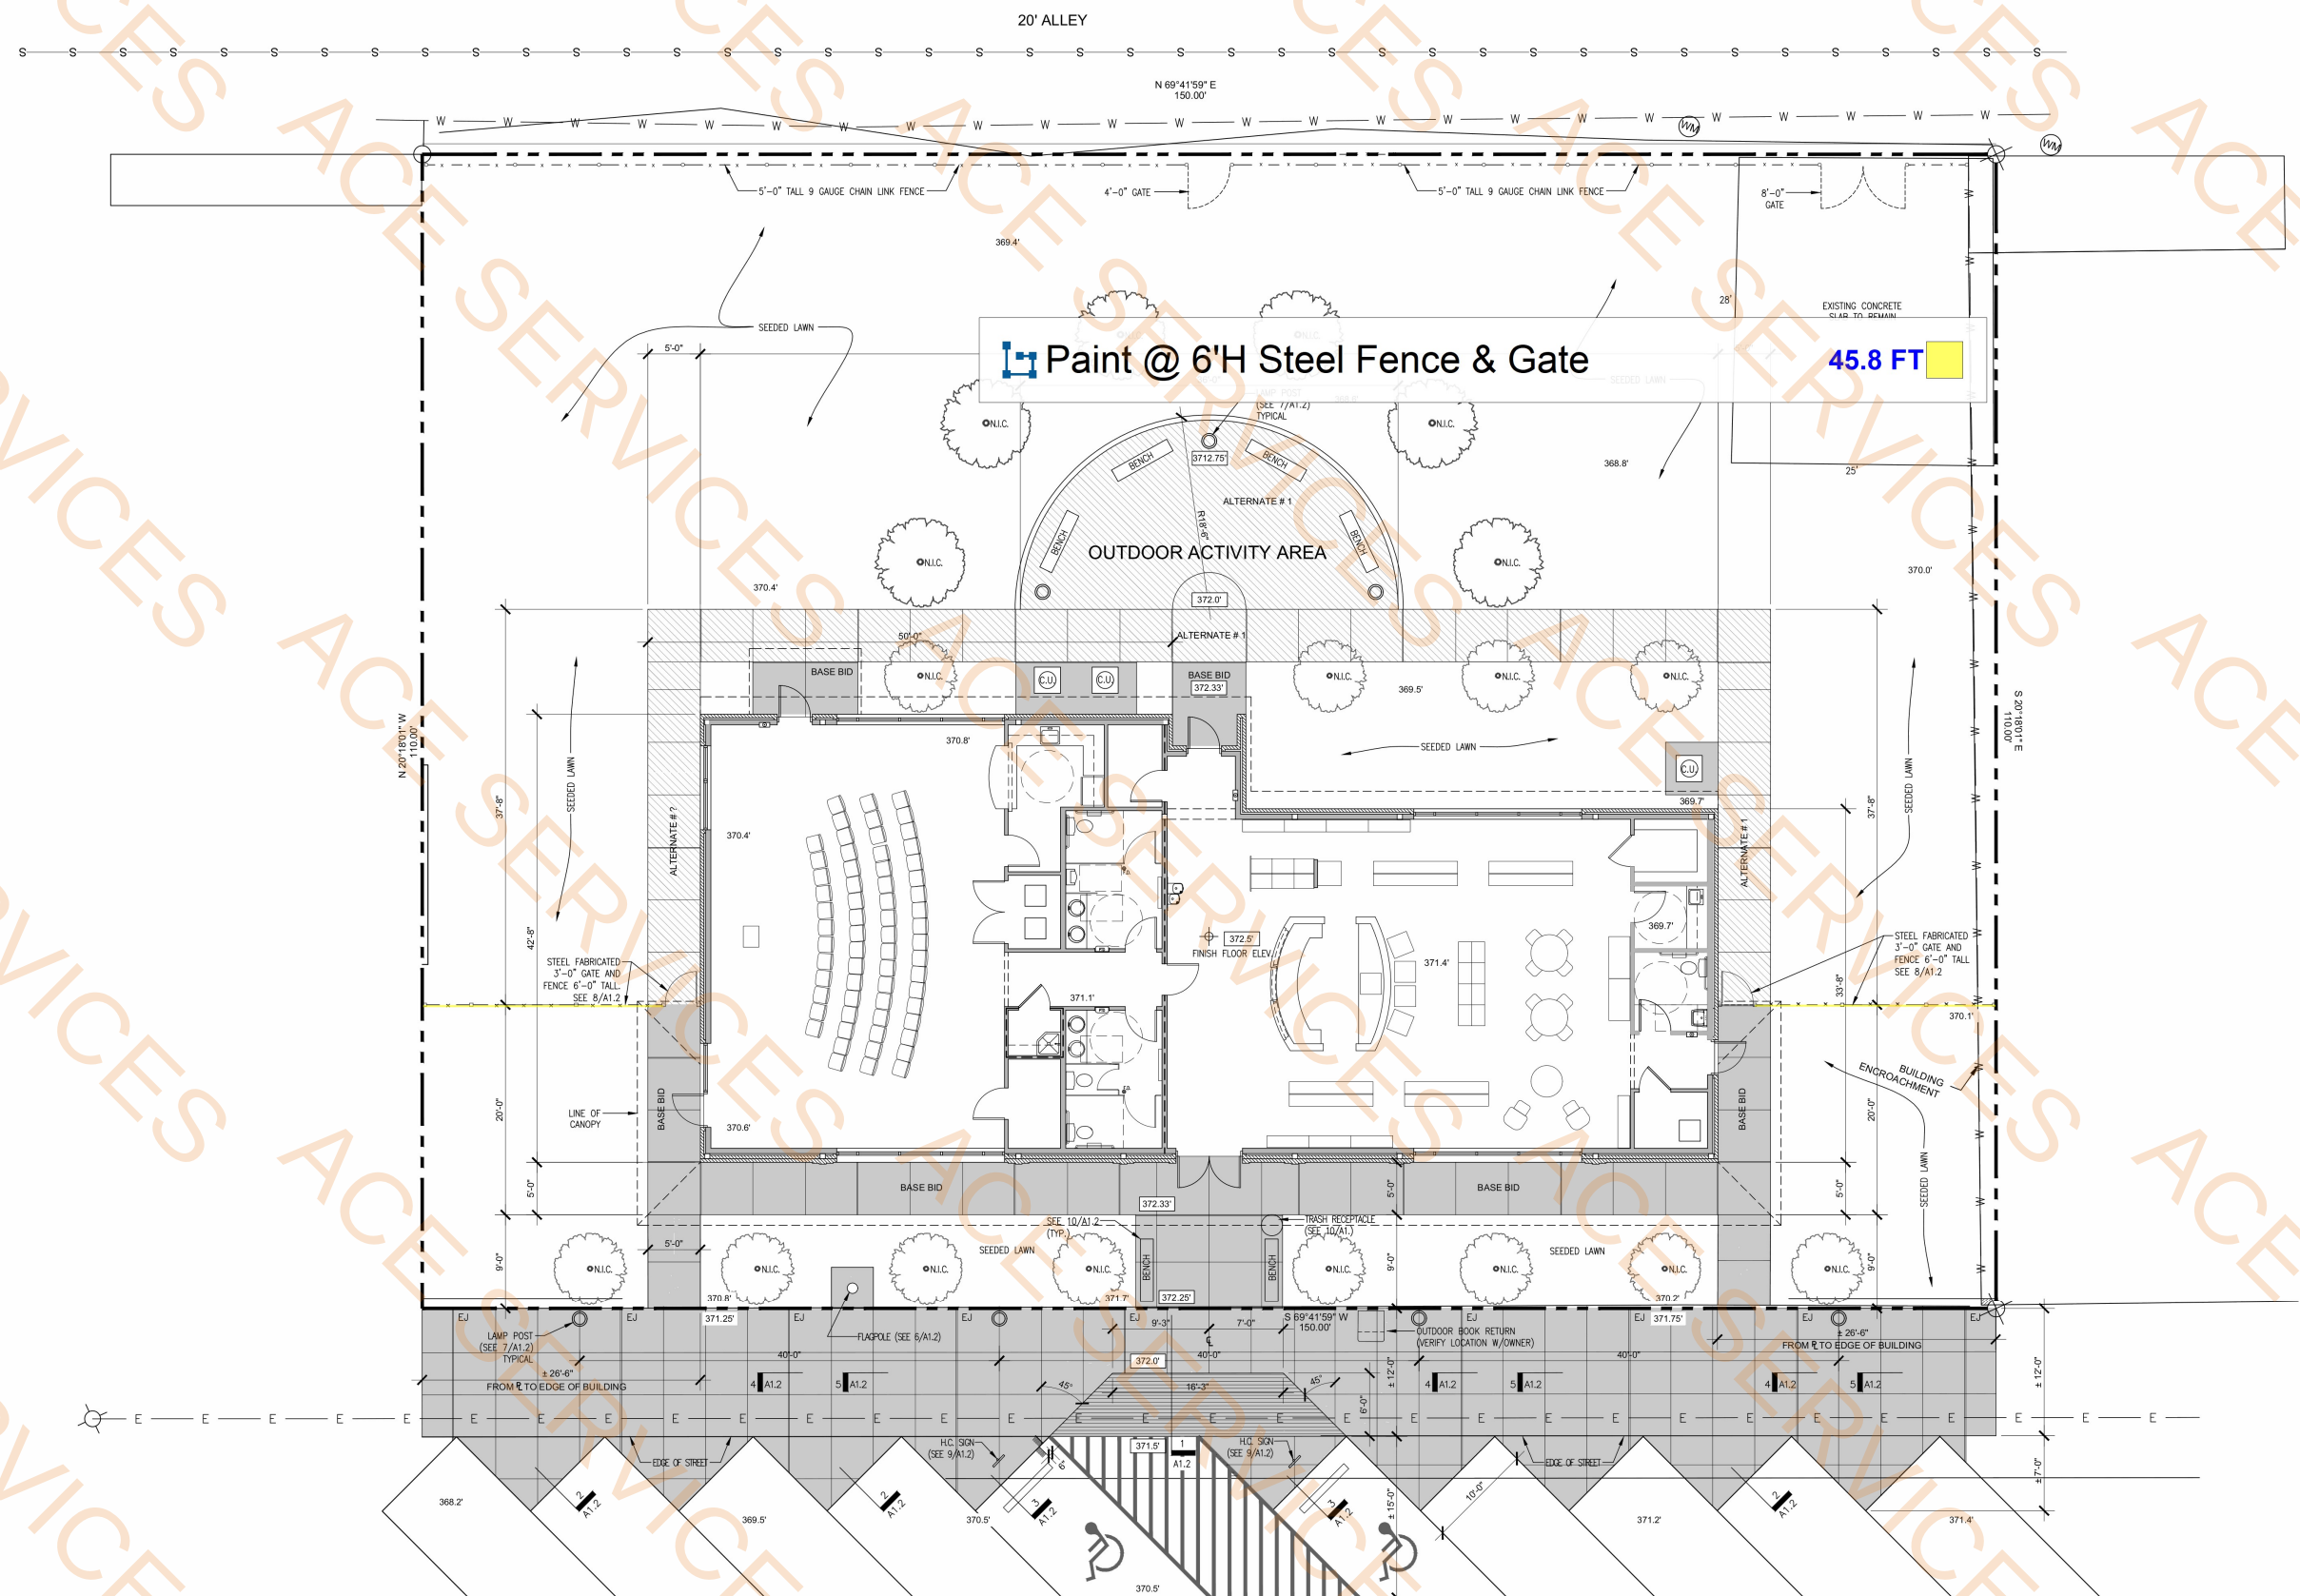

1 PROPOSED SITE PLAN
SCALE = 1/8" = 1'-0"




Project No.	0524
Drawn By	BP
Approved By	WAYNE L. COCO
Preliminary Date	08/08/2025
Release Date	
File	

WAYNE LAWRENCE COCO, AIA, ARCHITECT, L.L.C.
Coco & Company
P.O. BOX 111 - 510 MAIN ST.
SIMMESPORT, LOUISIANA 71369
(318) 941-2392 / FAX (318) 941-2821
a professional architectural company

THE JOE WEBB MEMORIAL BRANCH LIBRARY
FOR
THE CLAIBORNE PARISH LIBRARY
HAYNESVILLE, LOUISIANA

Sheet Number:
A1.1
3 of 32

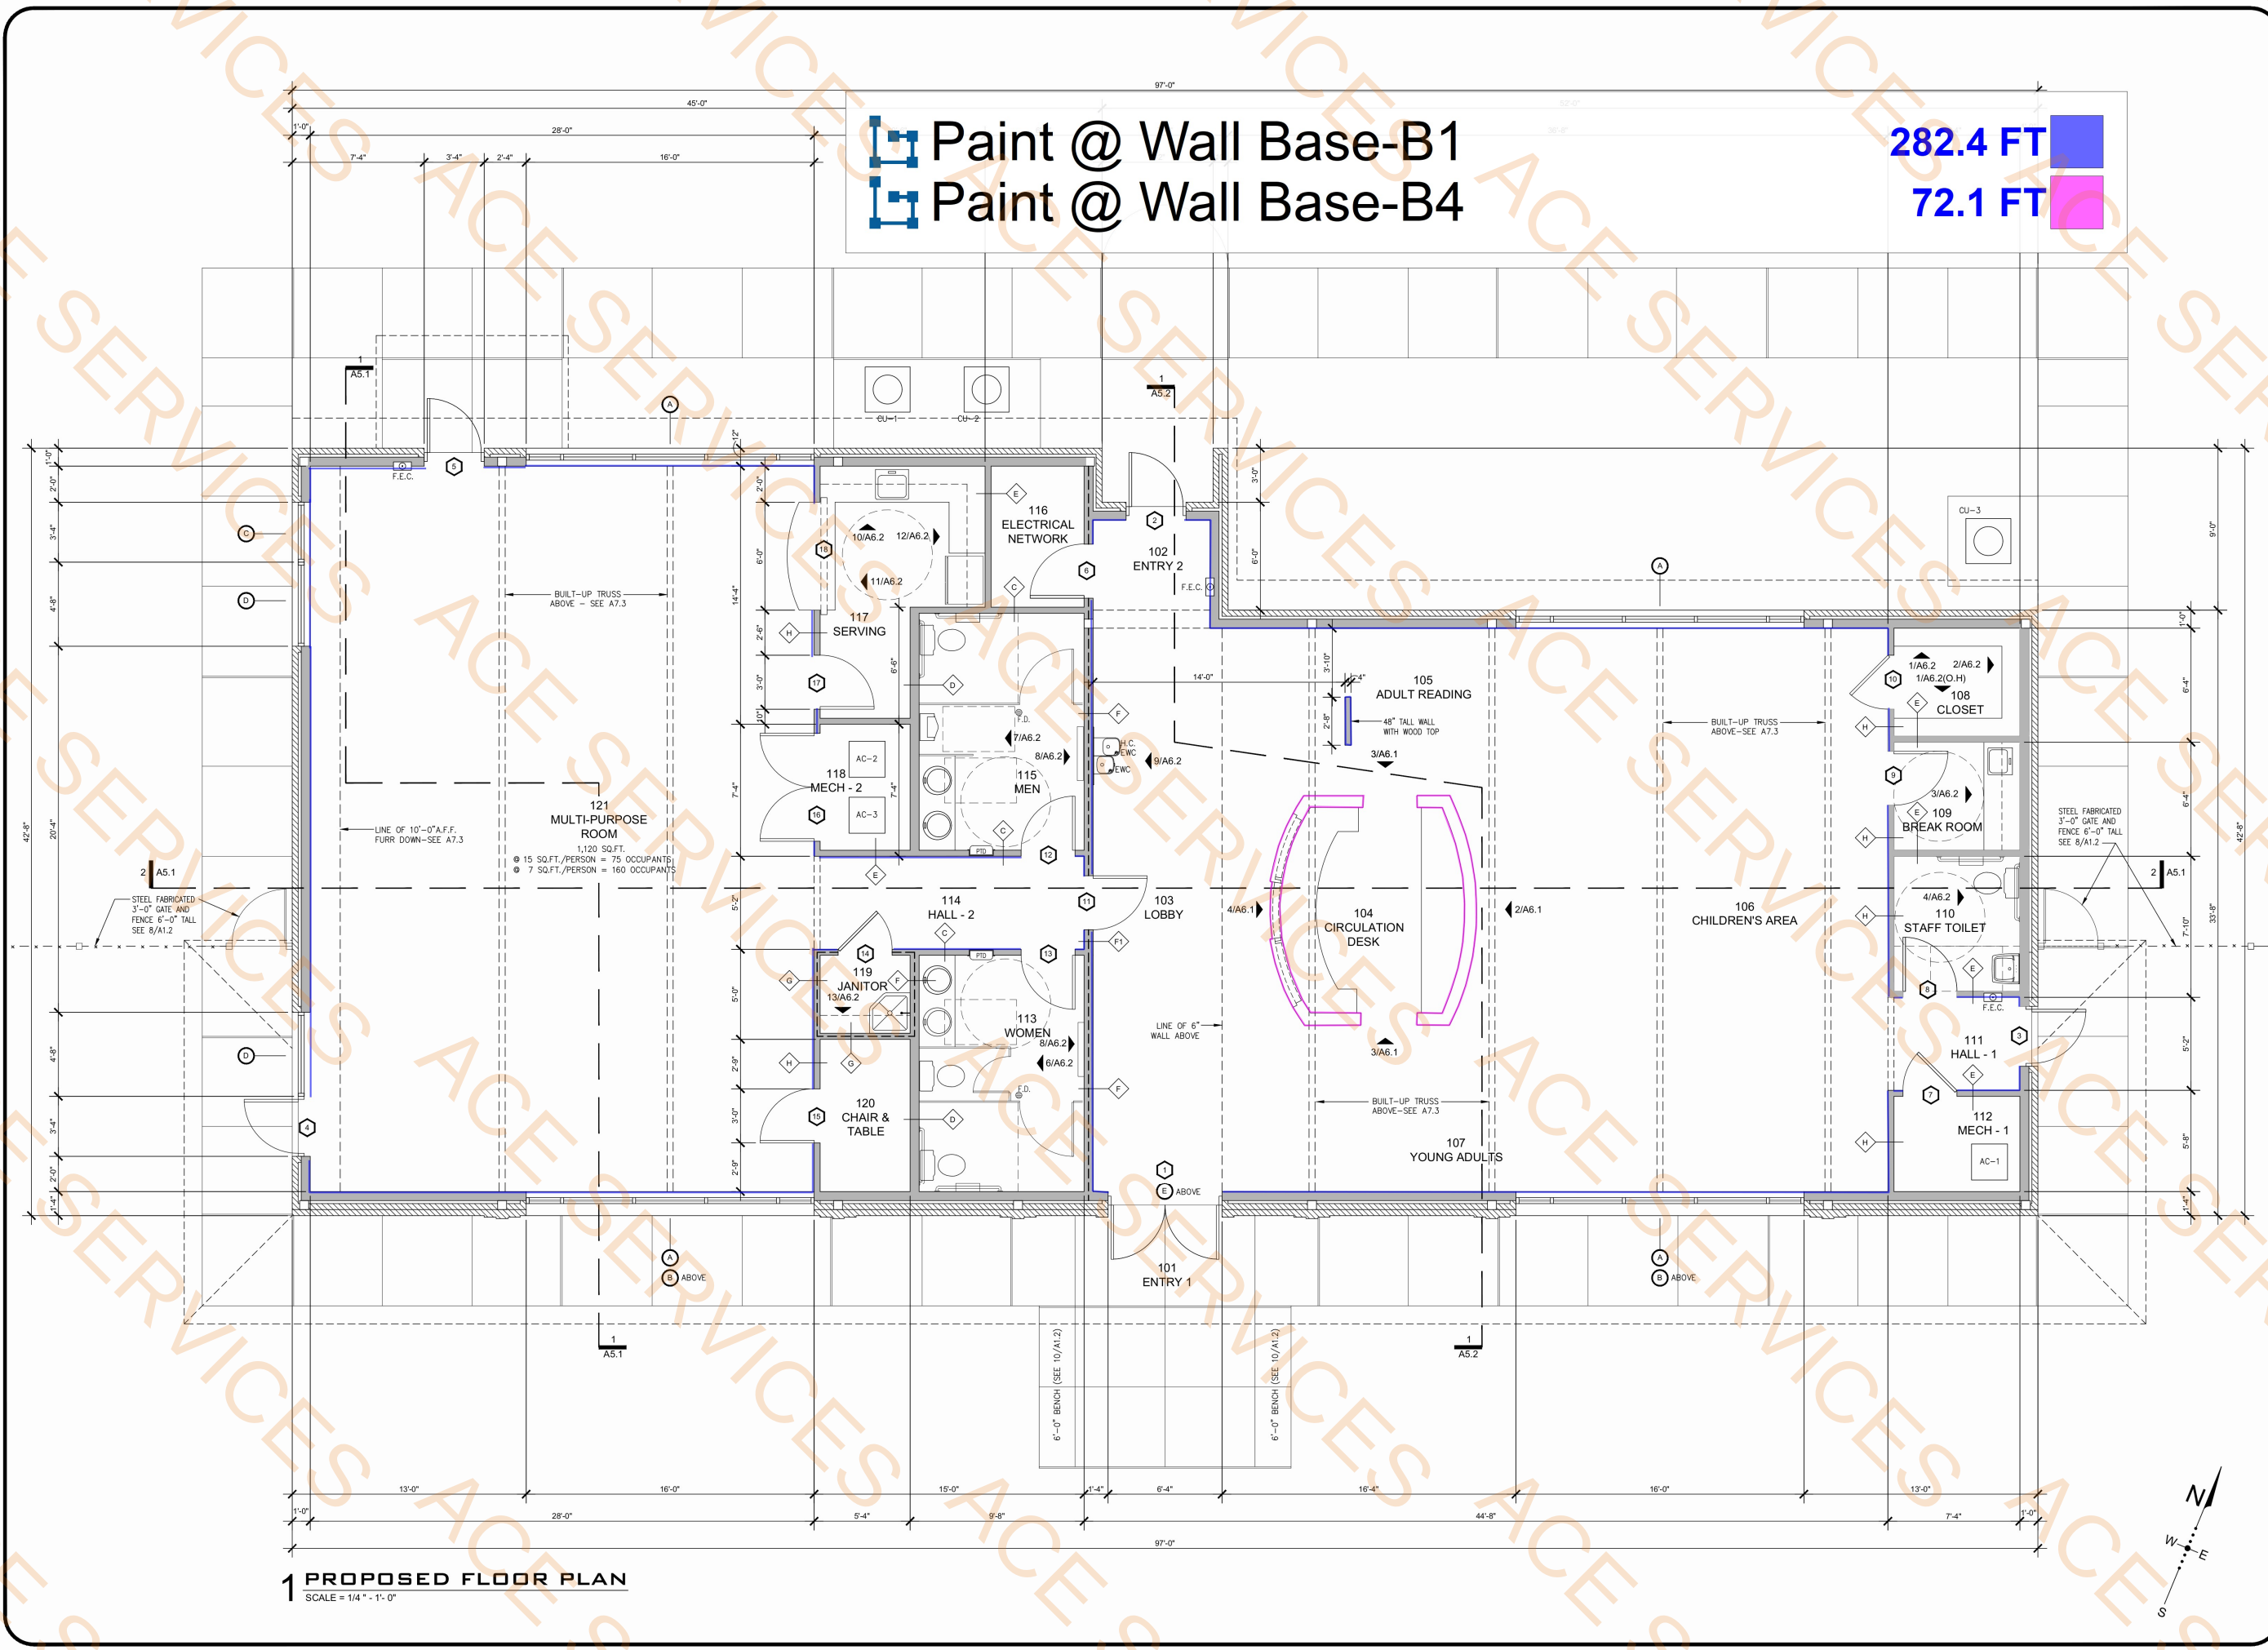

1 PROPOSED FLOOR PLAN
SCALE = 1/4" = 1'-0"

Paint @ Wall Base-B1
Paint @ Wall Base-B4

282.4 FT
72.1 FT




Project No.	0524
Drawn By	BP
Approved By	WAYNE L. COCO
Preliminary Date	08/08/2025
Release Date	
File	

WAYNE LAWRENCE COCO, AIA, ARCHITECT, L.L.C.
Coco & Company
P.O. BOX 111-510 MAIN ST.
SIMMESPORT, LOUISIANA 71969
(318) 941-2392 / FAX (318) 941-2821
a professional architectural company

THE JOE WEBB MEMORIAL BRANCH LIBRARY
FOR
THE CLAIBORNE PARISH LIBRARY
HAYNESVILLE, LOUISIANA

Sheet Number:
A2.1
5 of 32

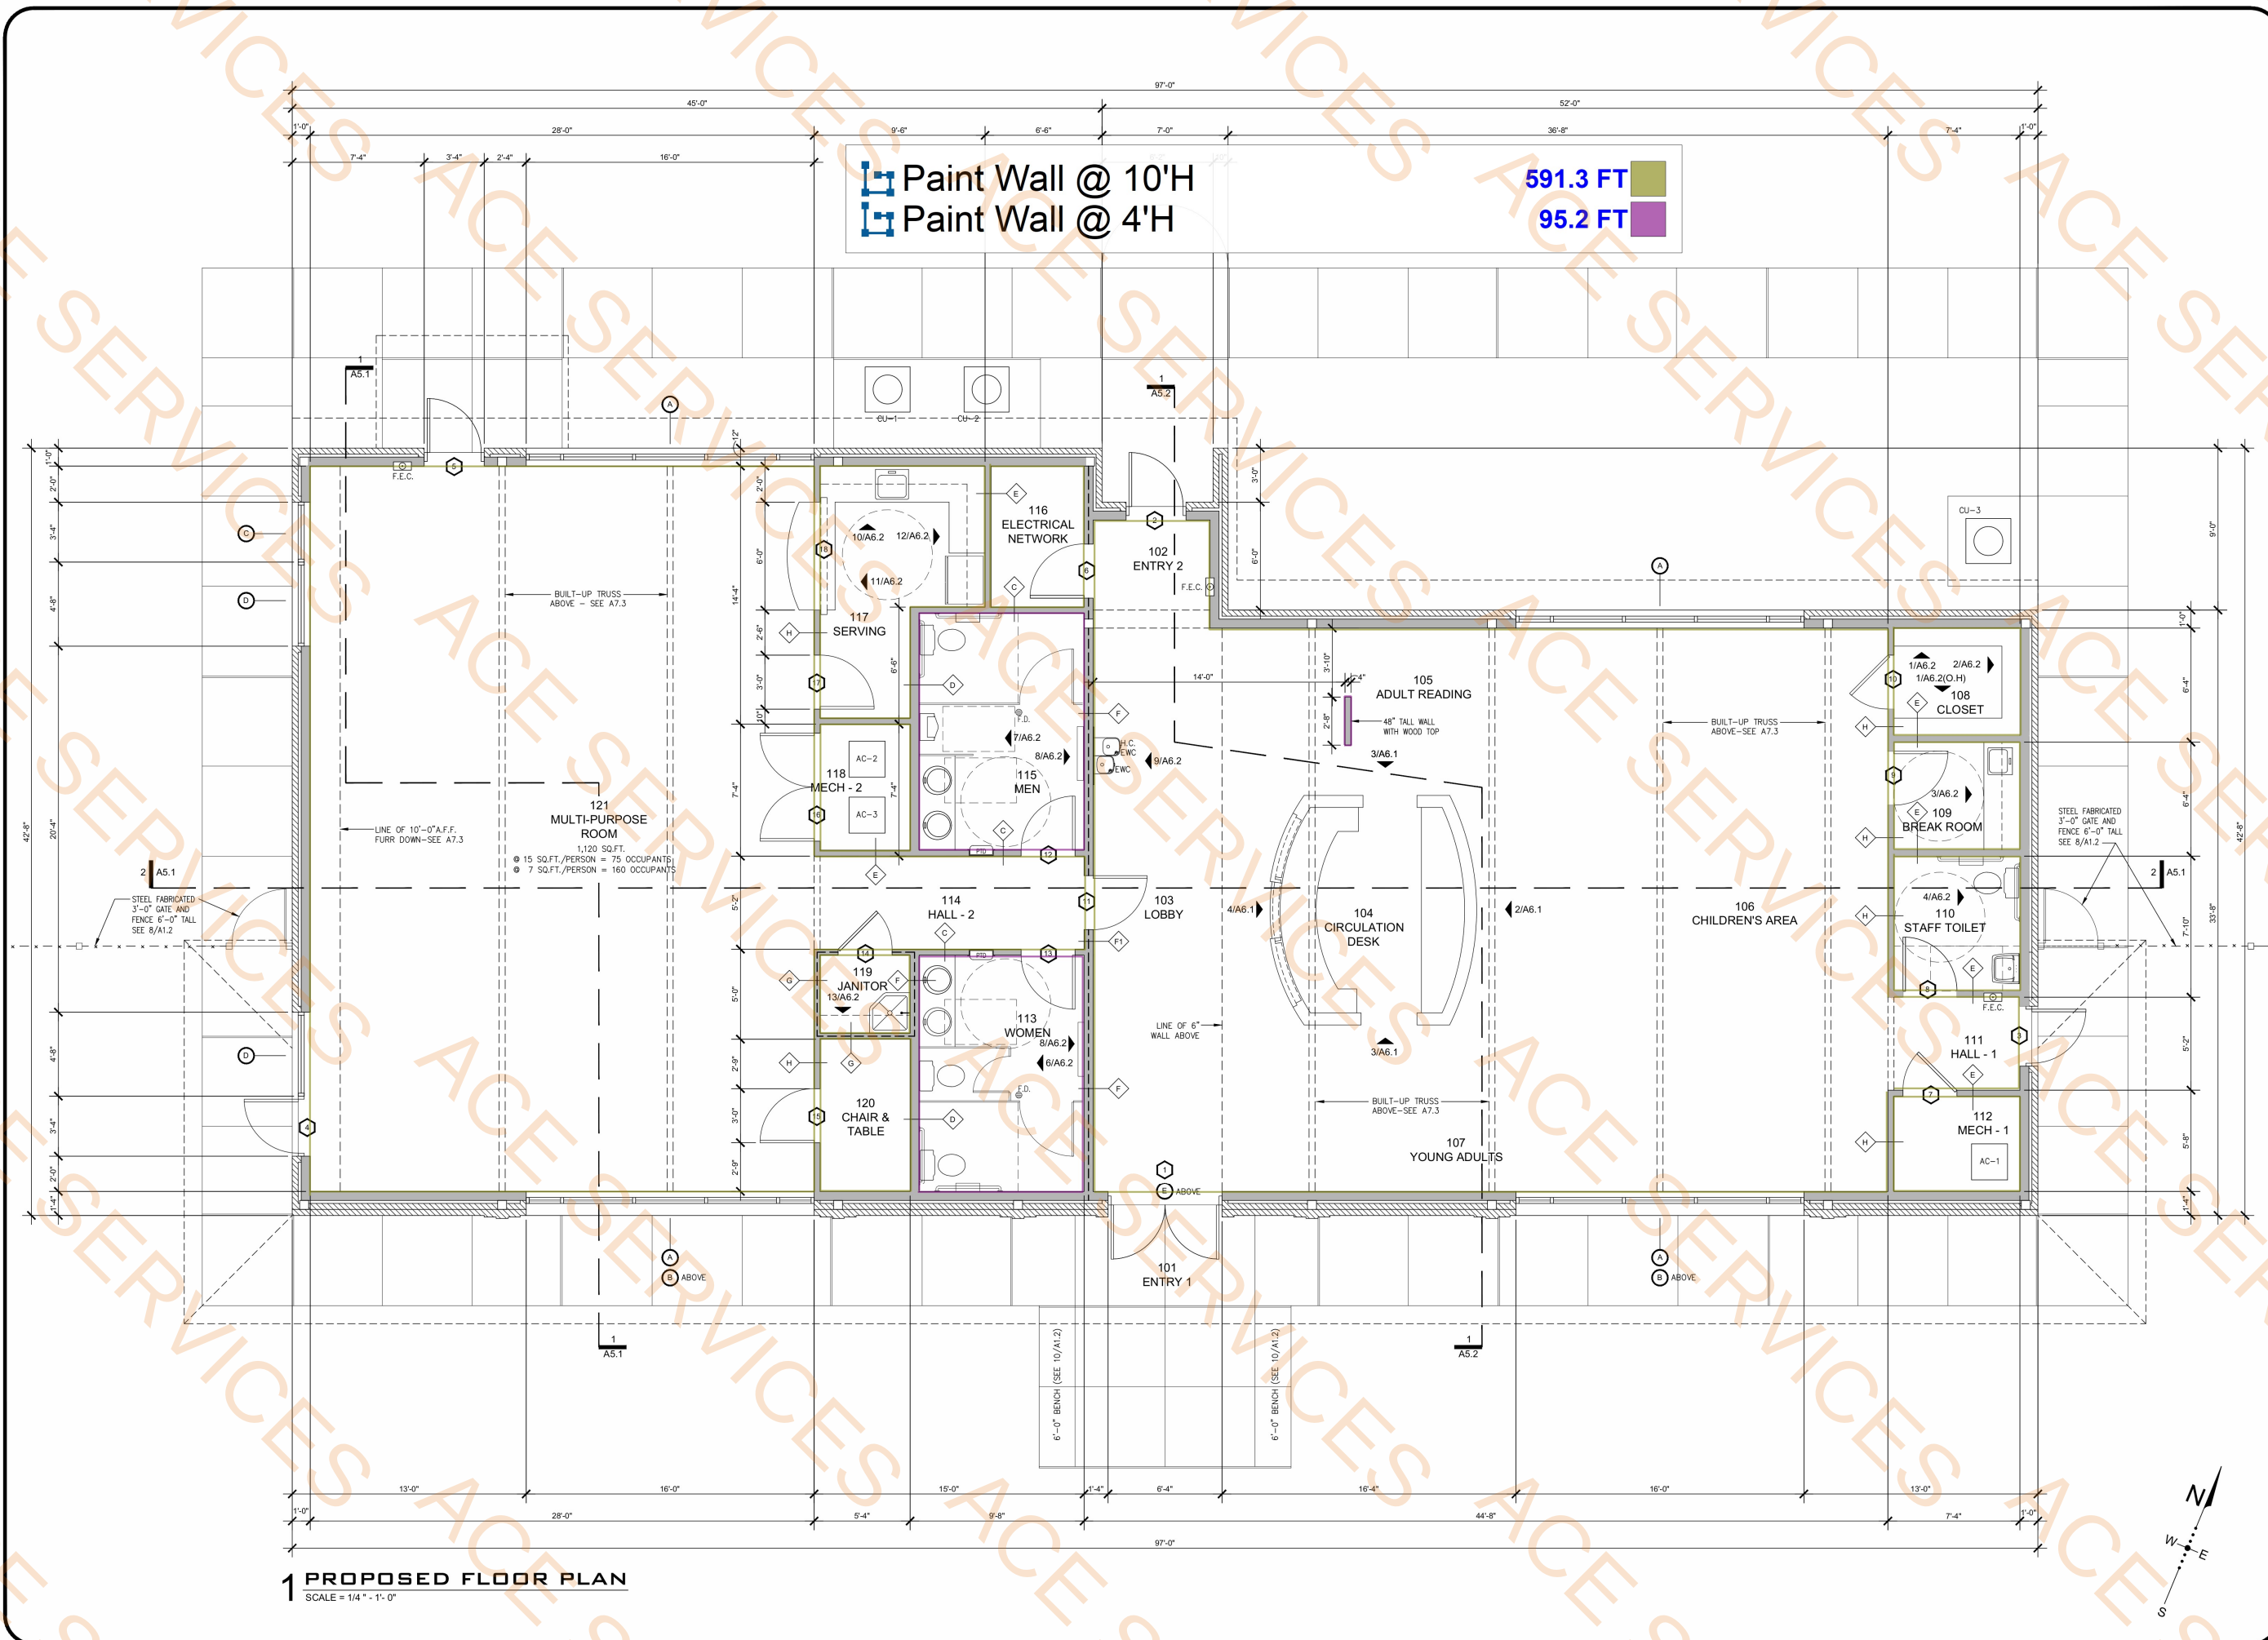

1 PROPOSED FLOOR PLAN
SCALE = 1/4" = 1'-0"



Project No.	0524
Drawn By	BP
Approved By	WAYNE L. COCO
Preliminary Date	08/08/2025
Release Date	
File	

WAYNE LAWRENCE COCO, AIA, ARCHITECT, L.L.C.
Coco & Company
P.O. BOX 111-510 MAIN ST.
SIMMESPORT, LOUISIANA 71969
(318) 941-2392 / FAX (318) 941-2821
a professional architectural company

THE JOE WEBB MEMORIAL BRANCH LIBRARY
FOR
THE CLAIBORNE PARISH LIBRARY
HAYNESVILLE, LOUISIANA

Sheet Number:
A2.1
5 of 32

Paint @ Gypsum Board Ceiling

Paint @ Exposed Structure

2327.0 SQ FT

72.2 SQ FT



1 PROPOSED REFLECTED CEILING PLAN
SCALE = 1/4" = 1'-0"

CEILING FINISH SCHEDULE	
MARK	DESCRIPTION
A	BASE BID: 2' x 2' SUSPENDED CEILING TILE AS SHOWN
B	BASE BID: 1x6 #2 SYP T&G BOARDS STAINED IN LOBBY
C	BASE BID: 5/8" TYPE X GWB - PAINTED
D	ALTERNATE #2: 1x6 #2 SYP T&G BOARDS STAINED
E	ALTERNATE #3: 2' x 2' SUSPENDED CEILING TILE (REFER TO INTERIOR FINISH SCHED)

LIGHTING SCHEDULE	
MARK	DESCRIPTION
A	2 x 2 LAY-IN
B	2 x 4 LAY-IN
C	2 x 4 LAY-IN
D	6" CYLINDER PENDANT LED
D1	6" CYLINDER PENDANT LED
EM	EMERGENCY LIGHT
F	32" LINEAR PENDANT
G	VAPORTIGHT
J	CANOPY FIXTURE W/ EMERGENCY DRIVER
X	EXIT SIGN



Project No.	0524
Drawn By	BP
Approved By	WAYNE L. COCO
Preliminary Date	06.08.2025
Release Date	File

WAYNE LAWRENCE COCO, AIA, ARCHITECT, L.L.C.
 P.O. BOX 111 - 510 MAIN ST.
 SIMESPORTE, LOUISIANA 71669
 (318) 941-2392 / FAX (318) 941-2821
 a professional architectural company

THE JOE WEBB MEMORIAL BRANCH LIBRARY
 FOR
 THE CLAIBORNE PARISH LIBRARY
 HAYNESVILLE, LOUISIANA