

CLUB 4 FITNESS - EL PASO MONTWOOD

11705 MONTWOOD DR, EL PASO, TX 79936

JUNE 05, 2025

Brent Barron Architect

P 6 0 1 . 7 5 0 . 1 7 7 8
14 WOODY HILLS DR., MADISON, MS 39110



Brent Barron Architect

P 6 0 1 . 7 5 0 . 1 7 7 8
114 WOODY HILLS DR., MADISON, MS 39110

CLUB 4 FITNESS - EL PASO MONTWOOD


11705 MONTWOOD DR, EL PASO, TX 79936

20250321

FOR CONSTRUCTION
JUNE 05, 2025

Fire Extinguisher

12.0 EA

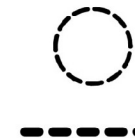

FIRE EXTINGUISHER LOCATION: 2-A EXTINGUISHERS, EXTINGUISHERS ON WALLS SHOULD BE IN SEMI-RECESSED ALUMINUM FINISHED BOXES. EXTINGUISHERS ON COLUMNS SHOULD BE MOUNTED WITH BRACKETS ON COLUMNS.


LIFE SAFETY LEGEND
1/4" = 1'-0"

GENERAL LIFE SAFETY NOTES:
1. FULLY CONSTRUCT ALL FIRE RATED PARTITIONS BEFORE ADJACENT PARTITIONS.
2. PROVIDE UL-APPROVED FIRE RATED SEALANTS AND OR DAMPERS AT PENETRATIONS OF FIRE RATED ASSEMBLIES.
3. CONTRACTOR TO PROVIDE FIRE EXTINGUISHERS IN ACCORDANCE WITH NFPA 10. AUTHORITY HAVING JURISDICTION WILL APPROVE FIRE EXTINGUISHER LOCATIONS.

SPECIFIC FIRE WALL NOTES:
1. IF THERE IS A CONFLICT BETWEEN THE INFORMATION ON THIS PAGE AND INFORMATION CONTAINED ON OTHER PAGES CONSULT THE ARCHITECT FOR DIRECTION. IN THE EVENT OF A CONFLICT THE MORE RESTRICTIVE OR EXTENSIVE OPTION SHOULD BE AVAILABLE FOR USE WITH NO INCREASE IN THE CONTRACT AMOUNT OR CONTRACT TIME.
2. REFERENCE PARTITION SCHEDULE FOR PARTITION ASSEMBLIES.
3. IF A WALL IS INDICATED TO BE A FIRE RATED WALL ON THE LIFE SAFETY PLANS IT SHOULD BE MADE SUCH REGARDLESS OF WHAT IS INDICATED ON THE PARTITION SCHEDULE.
4. ALL FIRE RATED WALLS EXTEND AT A MINIMUM FROM THE FLOOR STRUCTURE TO THE STRUCTURAL DECK ABOVE OR TO A RATED HORIZONTAL ASSEMBLY. WHEN RATED WALLS PASS THROUGH STRUCTURAL MEMBERS THE WALL SHALL BE THOROUGHLY SEALED TO THE STRUCTURAL MEMBER WITH APPROPRIATE FIRE SEALING MATERIALS.

FIRE SPRINKLER NOTES:
1. CONTRACTOR TO ENGAGE A FIRE SPRINKLER SUB-CONTRACTOR TO DESIGN AND EXECUTE MODIFICATIONS TO THE EXISTING FIRE ALARM SYSTEM TO MEET NFPA 13 REQUIREMENTS AND ANY ADDITIONAL REQUIREMENTS OF THE LOCAL JURISDICTION.
2. FIRE SPRINKLER SYSTEM TO BE MONITORED PER 903.4 OF THE IFC 2015.
3. CONTRACTOR TO FIELD VERIFY FDC IS LOCATED WITHIN 100' OF A FIRE-HYDRANT.

FIRE ALARM SYSTEM:
1. PROVIDE A FIRE ALARM SYSTEM TO BE MONITORED PER 907.6.6 OF THE IFC 2015.

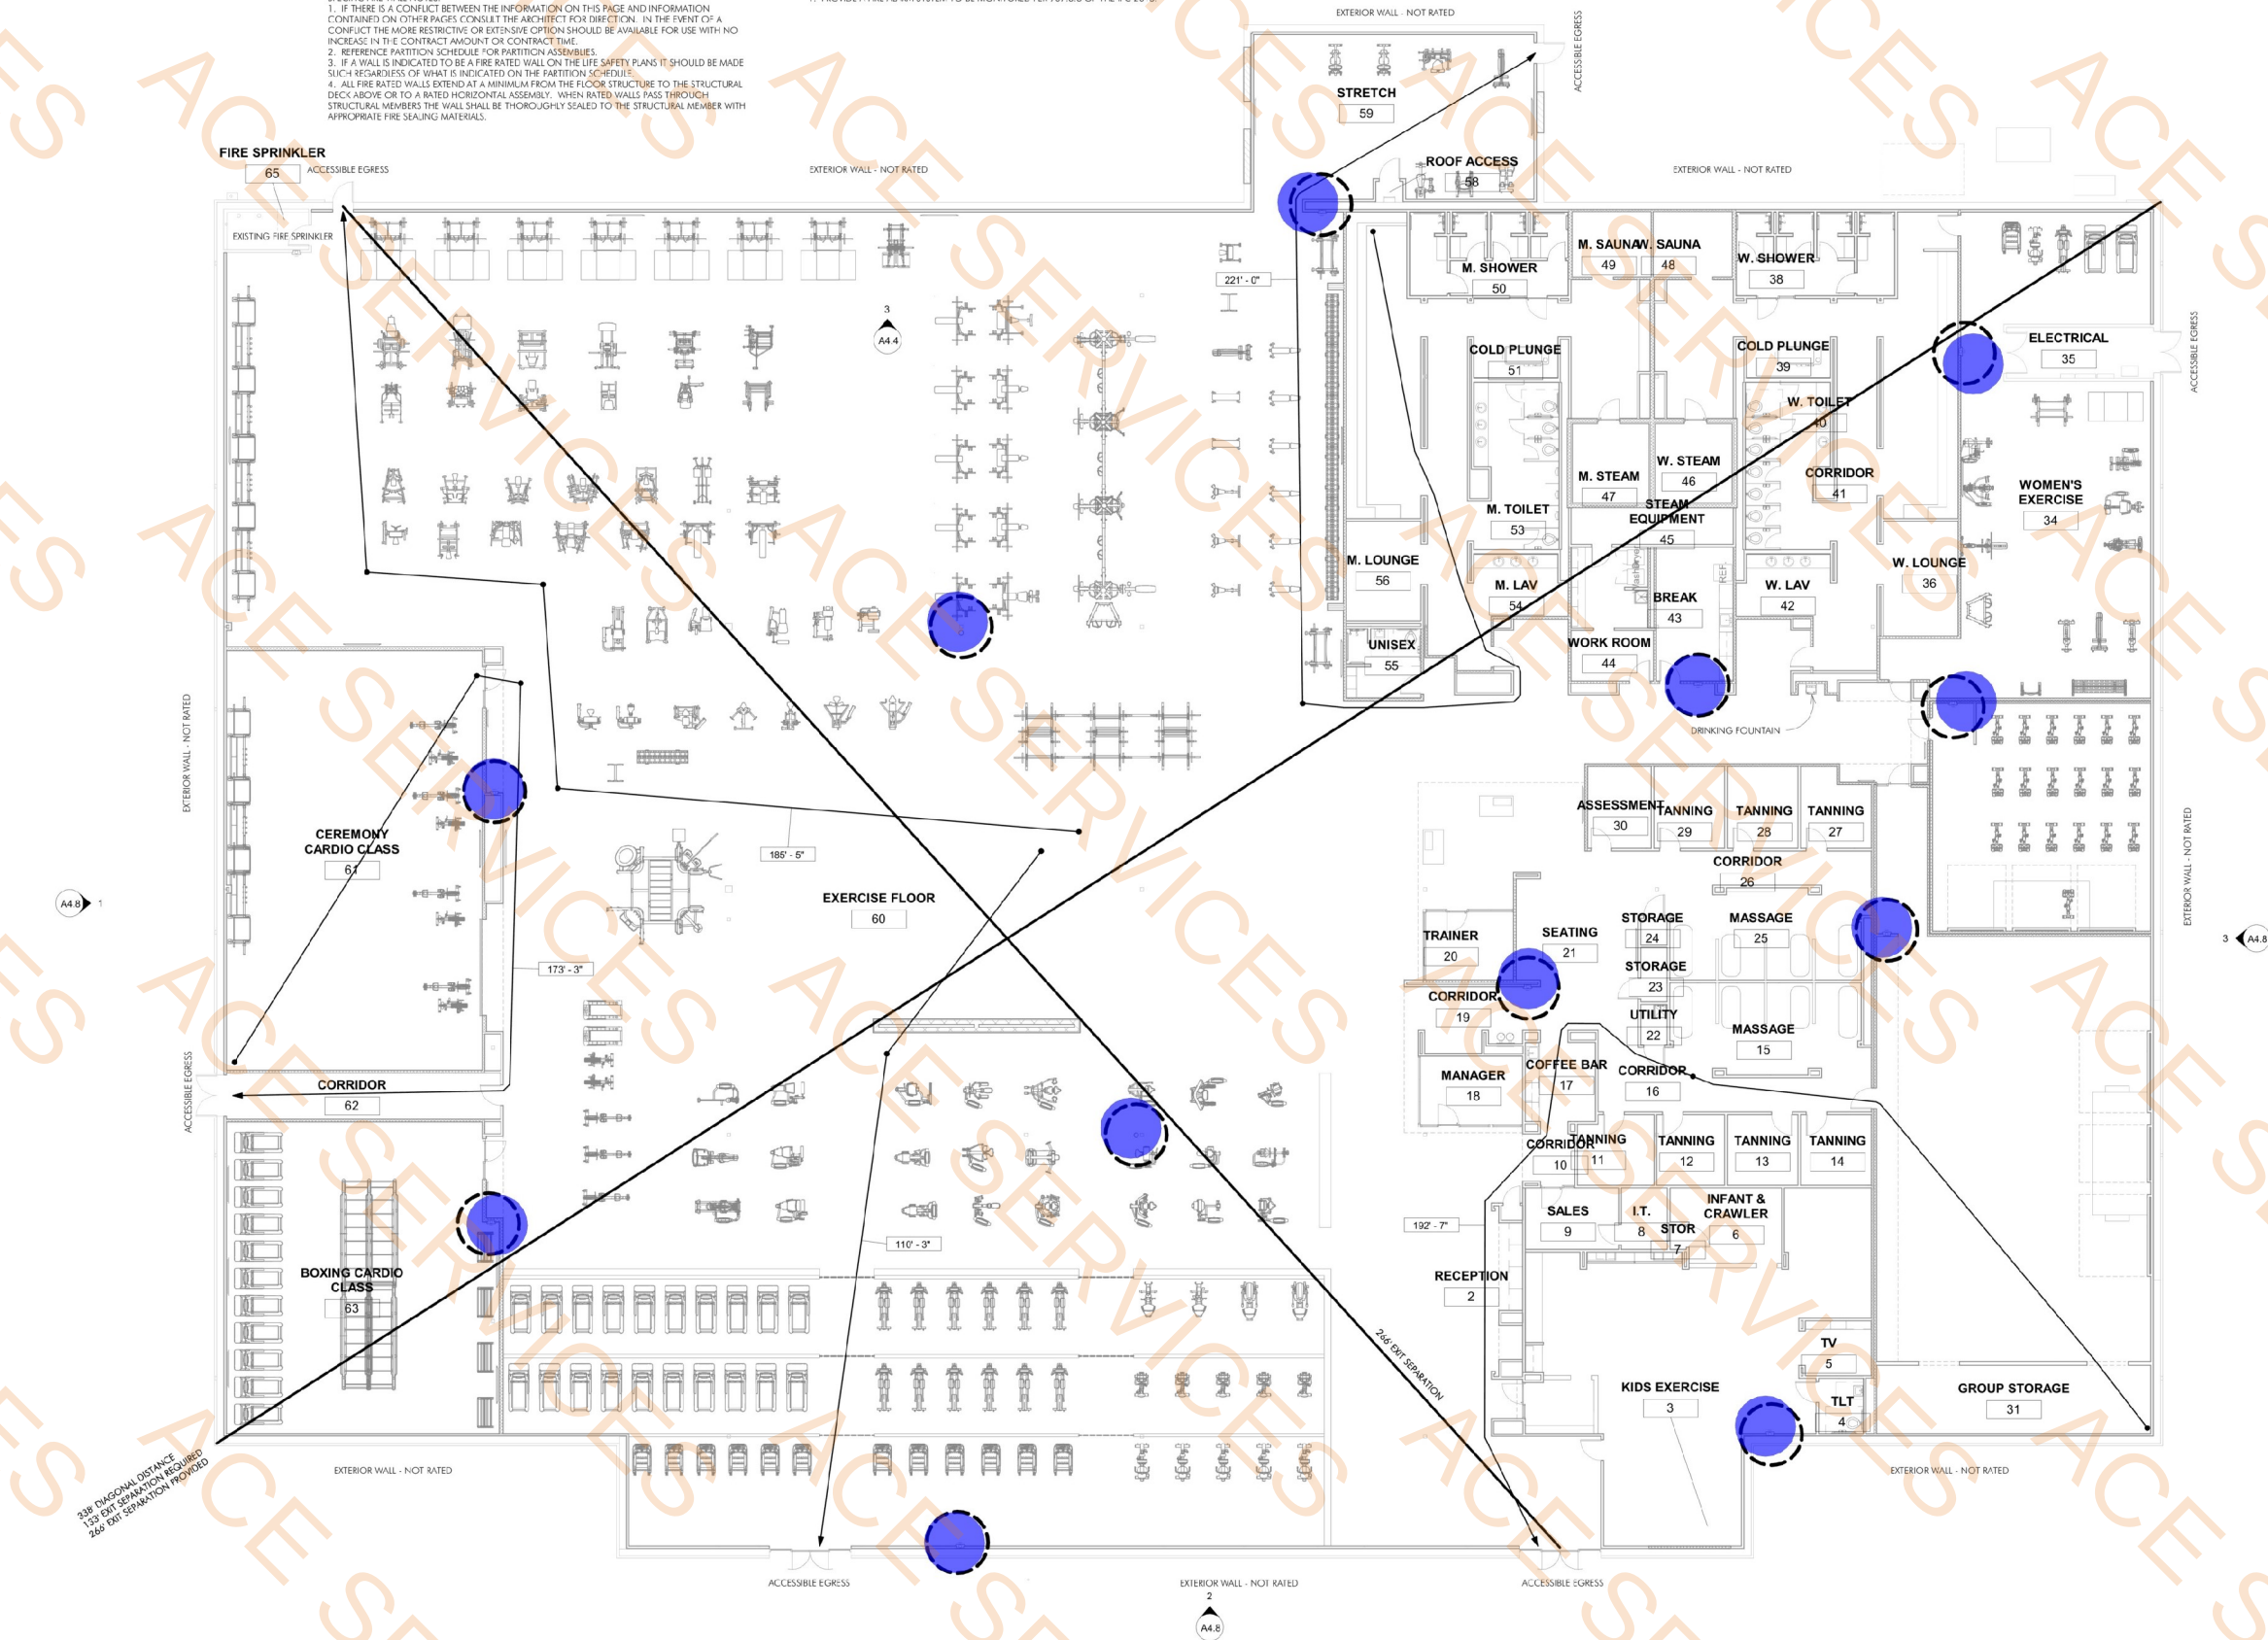

1 LIFE SAFETY PLAN
3/32" = 1'-0"

NOTE: THE CONTRACT DRAWINGS ARE NOT ORGANIZED SPECIFICALLY FOR ANY CRAFT, TRADE, DISCIPLINE, OR SUBCONTRACT. THEREFORE, ADDITIONAL RELATED INFORMATION MAY BE INCLUDED IN OTHER CONTRACT DRAWINGS AND SPECIFICATIONS EVEN THOUGH NOT SPECIFICALLY NOTED ON THIS DOCUMENT. IT IS THE RESPONSIBILITY OF EACH PARTY TO REFER TO THE COMPLETE SET OF CONTRACT DRAWINGS AND SPECIFICATIONS, AND NOT TO A PARTIAL OR INCOMPLETE SET OF DOCUMENTS.



Brent Barron Architect

P 6 0 1 7 5 0 1 7 8
114 WOODY HILLS DR. JACKSON, MS 39210

LIFE SAFETY PLAN
CLUB 4 FITNESS - EL PASO MONTWOOD
11705 MONTWOOD DR. EL PASO, TX 79936
20250321

FOR CONSTRUCTION
JUNE 05, 2025

A0.2



Brent Barron Architect


P 6 0 1 . 7 5 0 . 1 7 8
114 WOODY HILLS DR, JACKSON, MS 39210

FLOOR PLAN - EXISTING
CLUB 4 FITNESS - EL PASO MONTWOOD
11705 MONTWOOD DR, EL PASO, TX 79936
20250321

FOR CONSTRUCTION
JUNE 05, 2025

A1.1

- Col 12"x12" Wall HT 23'-6" PB(Paint) 2.0 EA
- Col 6"x6" WALL HT 23'-6" PB(Paint) 11.0 EA
- Col 6"x6" WALL HT 13'-6" PB(Paint) 2.0 EA
- Col 6"x6" WALL HT 12'-0" PB(Paint) 4.0 EA
- Col 6"x6" WALL HT 9' PB(Paint) 2.0 EA

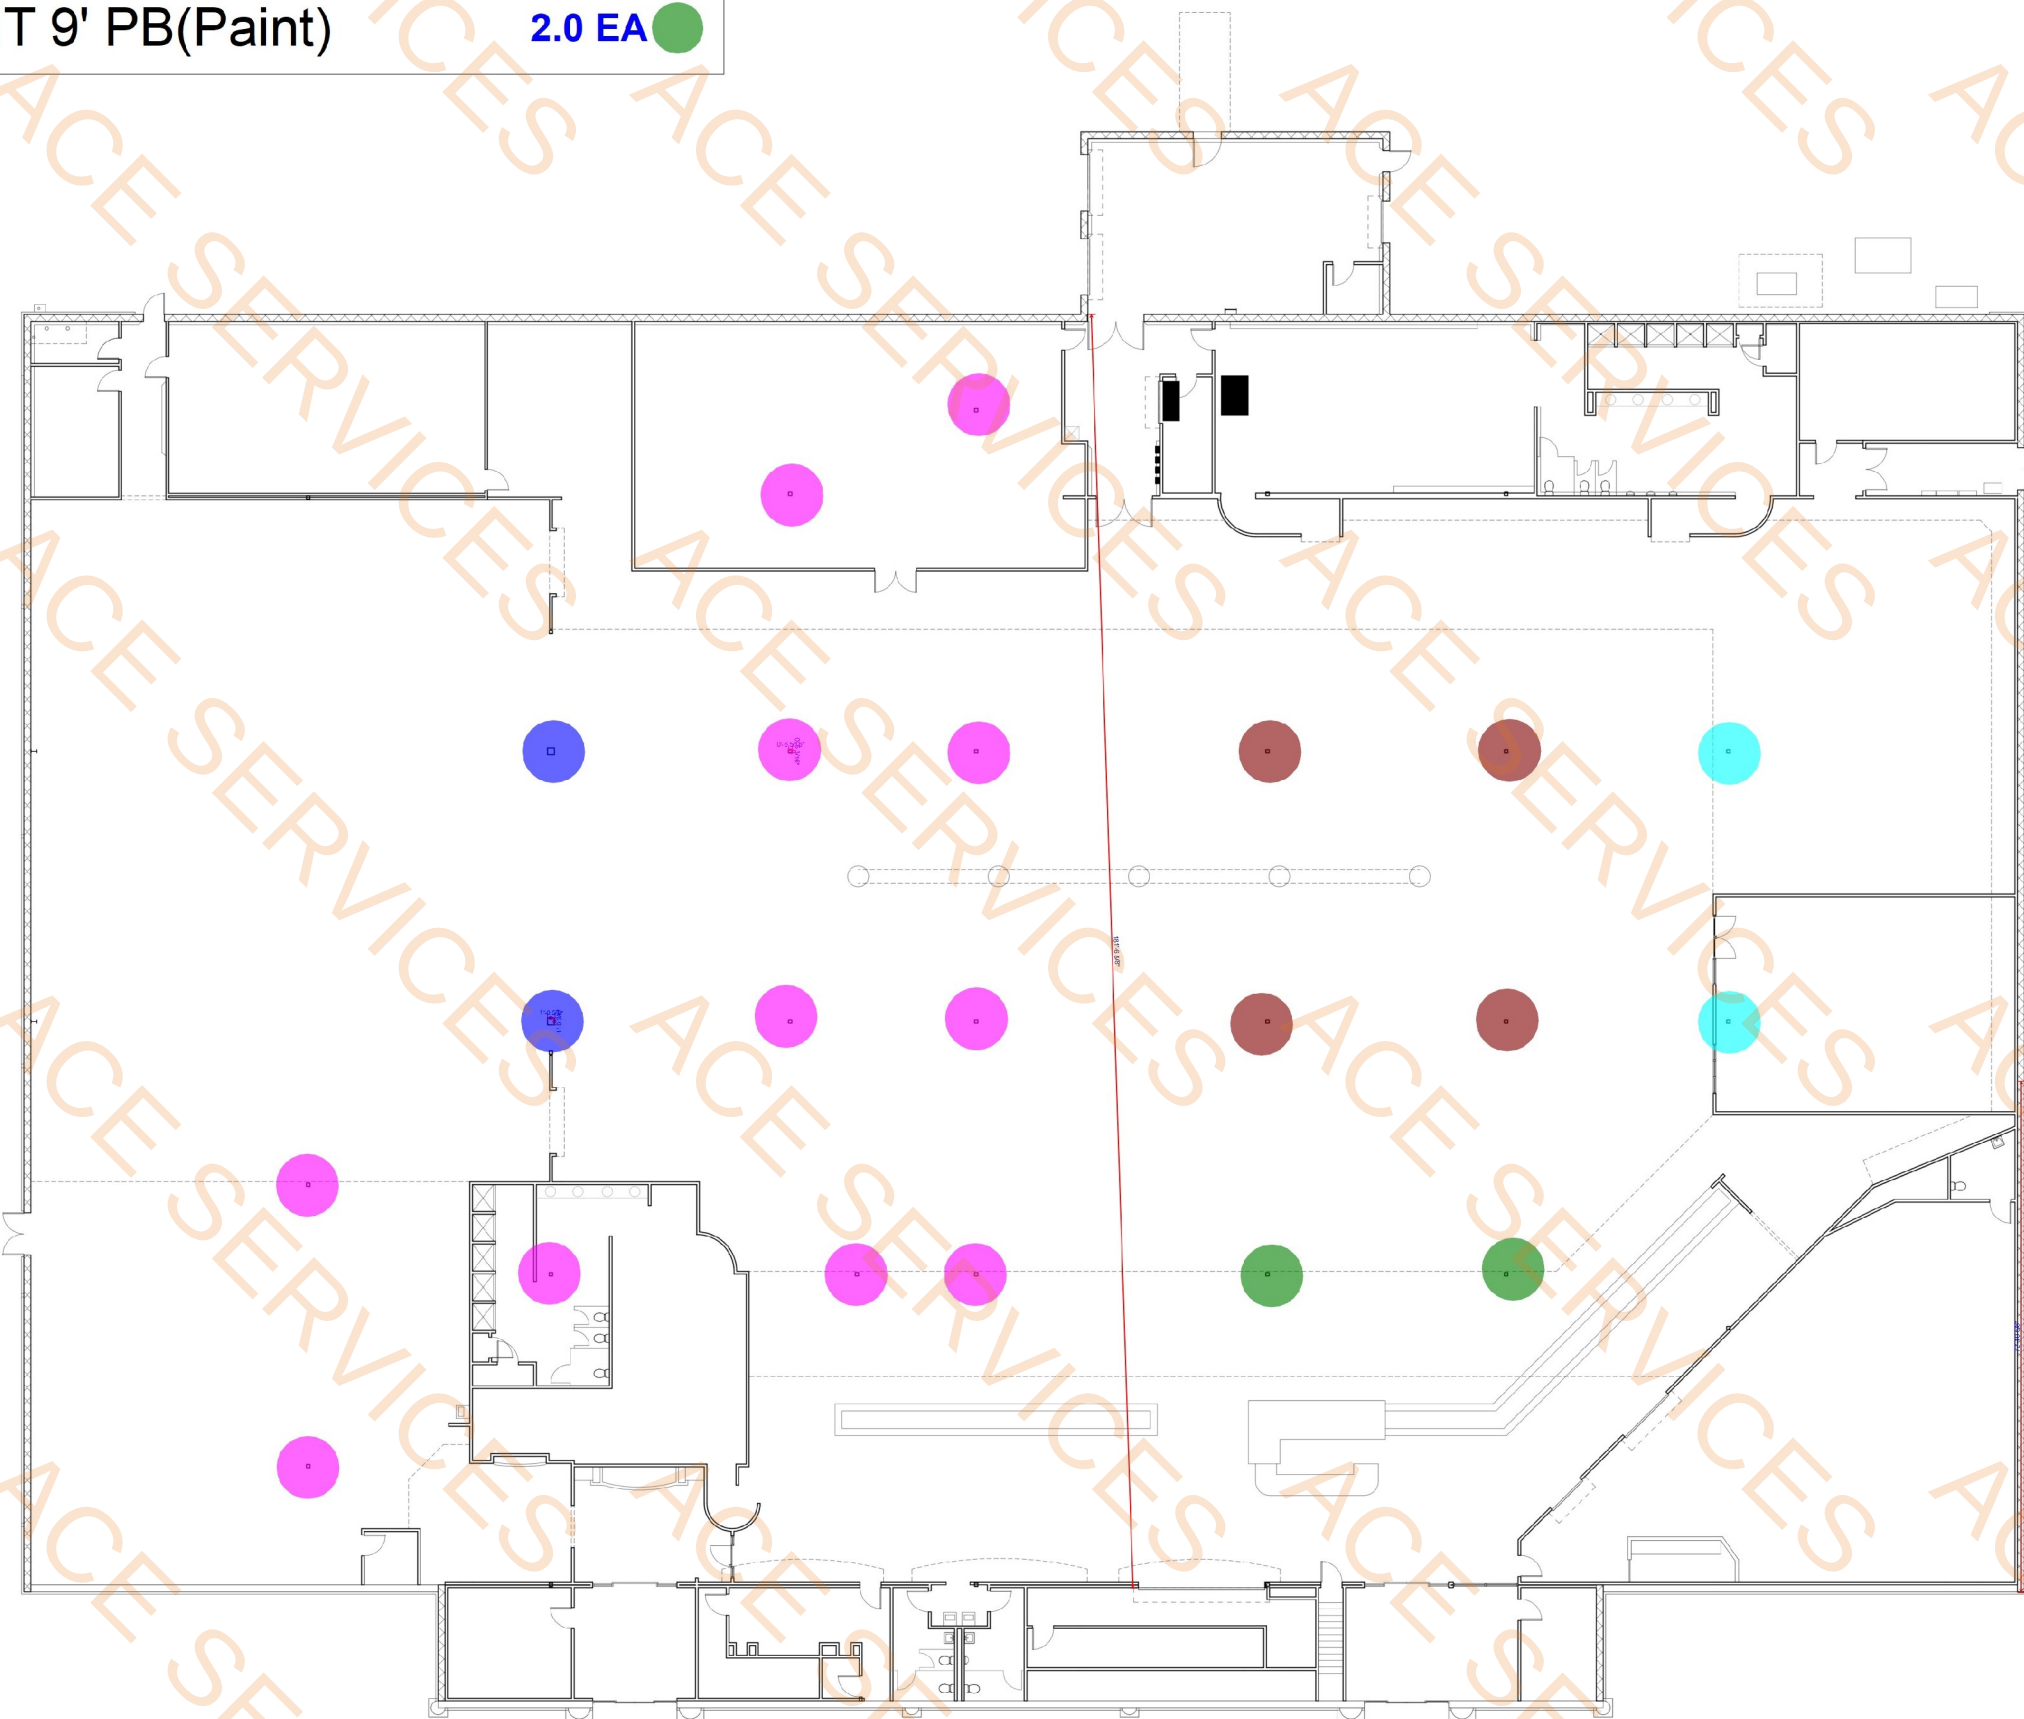


1 FLOOR PLAN - EXISTING
3/32" = 1'-0"

NOTE: THE CONTRACT DRAWINGS ARE NOT ORGANIZED SPECIFICALLY FOR ANY CRAFT, TRADE, DISCIPLINE, OR SUBCONTRACT. THEREFORE, ADDITIONAL RELATED INFORMATION MAY BE INCLUDED IN OTHER CONTRACT DRAWINGS AND SPECIFICATIONS EVEN THOUGH NOT SPECIFICALLY NOTED ON THIS DOCUMENT. IT IS THE RESPONSIBILITY OF EACH PARTY TO REFER TO THE COMPLETE SET OF CONTRACT DRAWINGS AND SPECIFICATIONS, AND NOT TO A PARTIAL OR INCOMPLETE SET OF DOCUMENTS.



NOTE: THE CONTRACT DRAWINGS ARE NOT ORGANIZED SPECIFICALLY FOR ANY CRAFT, TRADE, DISCIPLINE, OR SUBCONTRACT. THEREFORE, ADDITIONAL RELATED INFORMATION MAY BE INCLUDED IN OTHER CONTRACT DRAWINGS AND SPECIFICATIONS EVEN THOUGH NOT SPECIFICALLY NOTED ON THIS DOCUMENT. IT IS THE RESPONSIBILITY OF EACH PARTY TO REFER TO THE COMPLETE SET OF CONTRACT DRAWINGS AND SPECIFICATIONS, AND NOT TO A PARTIAL OR INCOMPLETE SET OF DOCUMENTS.

- | | | |
|--------------------------------|----------|--|
| 20' HT wall with PS (Paint) | 29.8 FT | |
| 22' Wall Ht PS (paint) | 238.8 FT | |
| 23'-8" Wall Ht with PS(Paint) | 78.1 FT | |
| 27'-4" wall HT with PS(Paint) | 97.9 FT | |
| 22' Wall HT CG(Trim Finishes) | 8.0 EA | |
| 9' Wall Ht with PS (Paint) | 13.1 FT | |

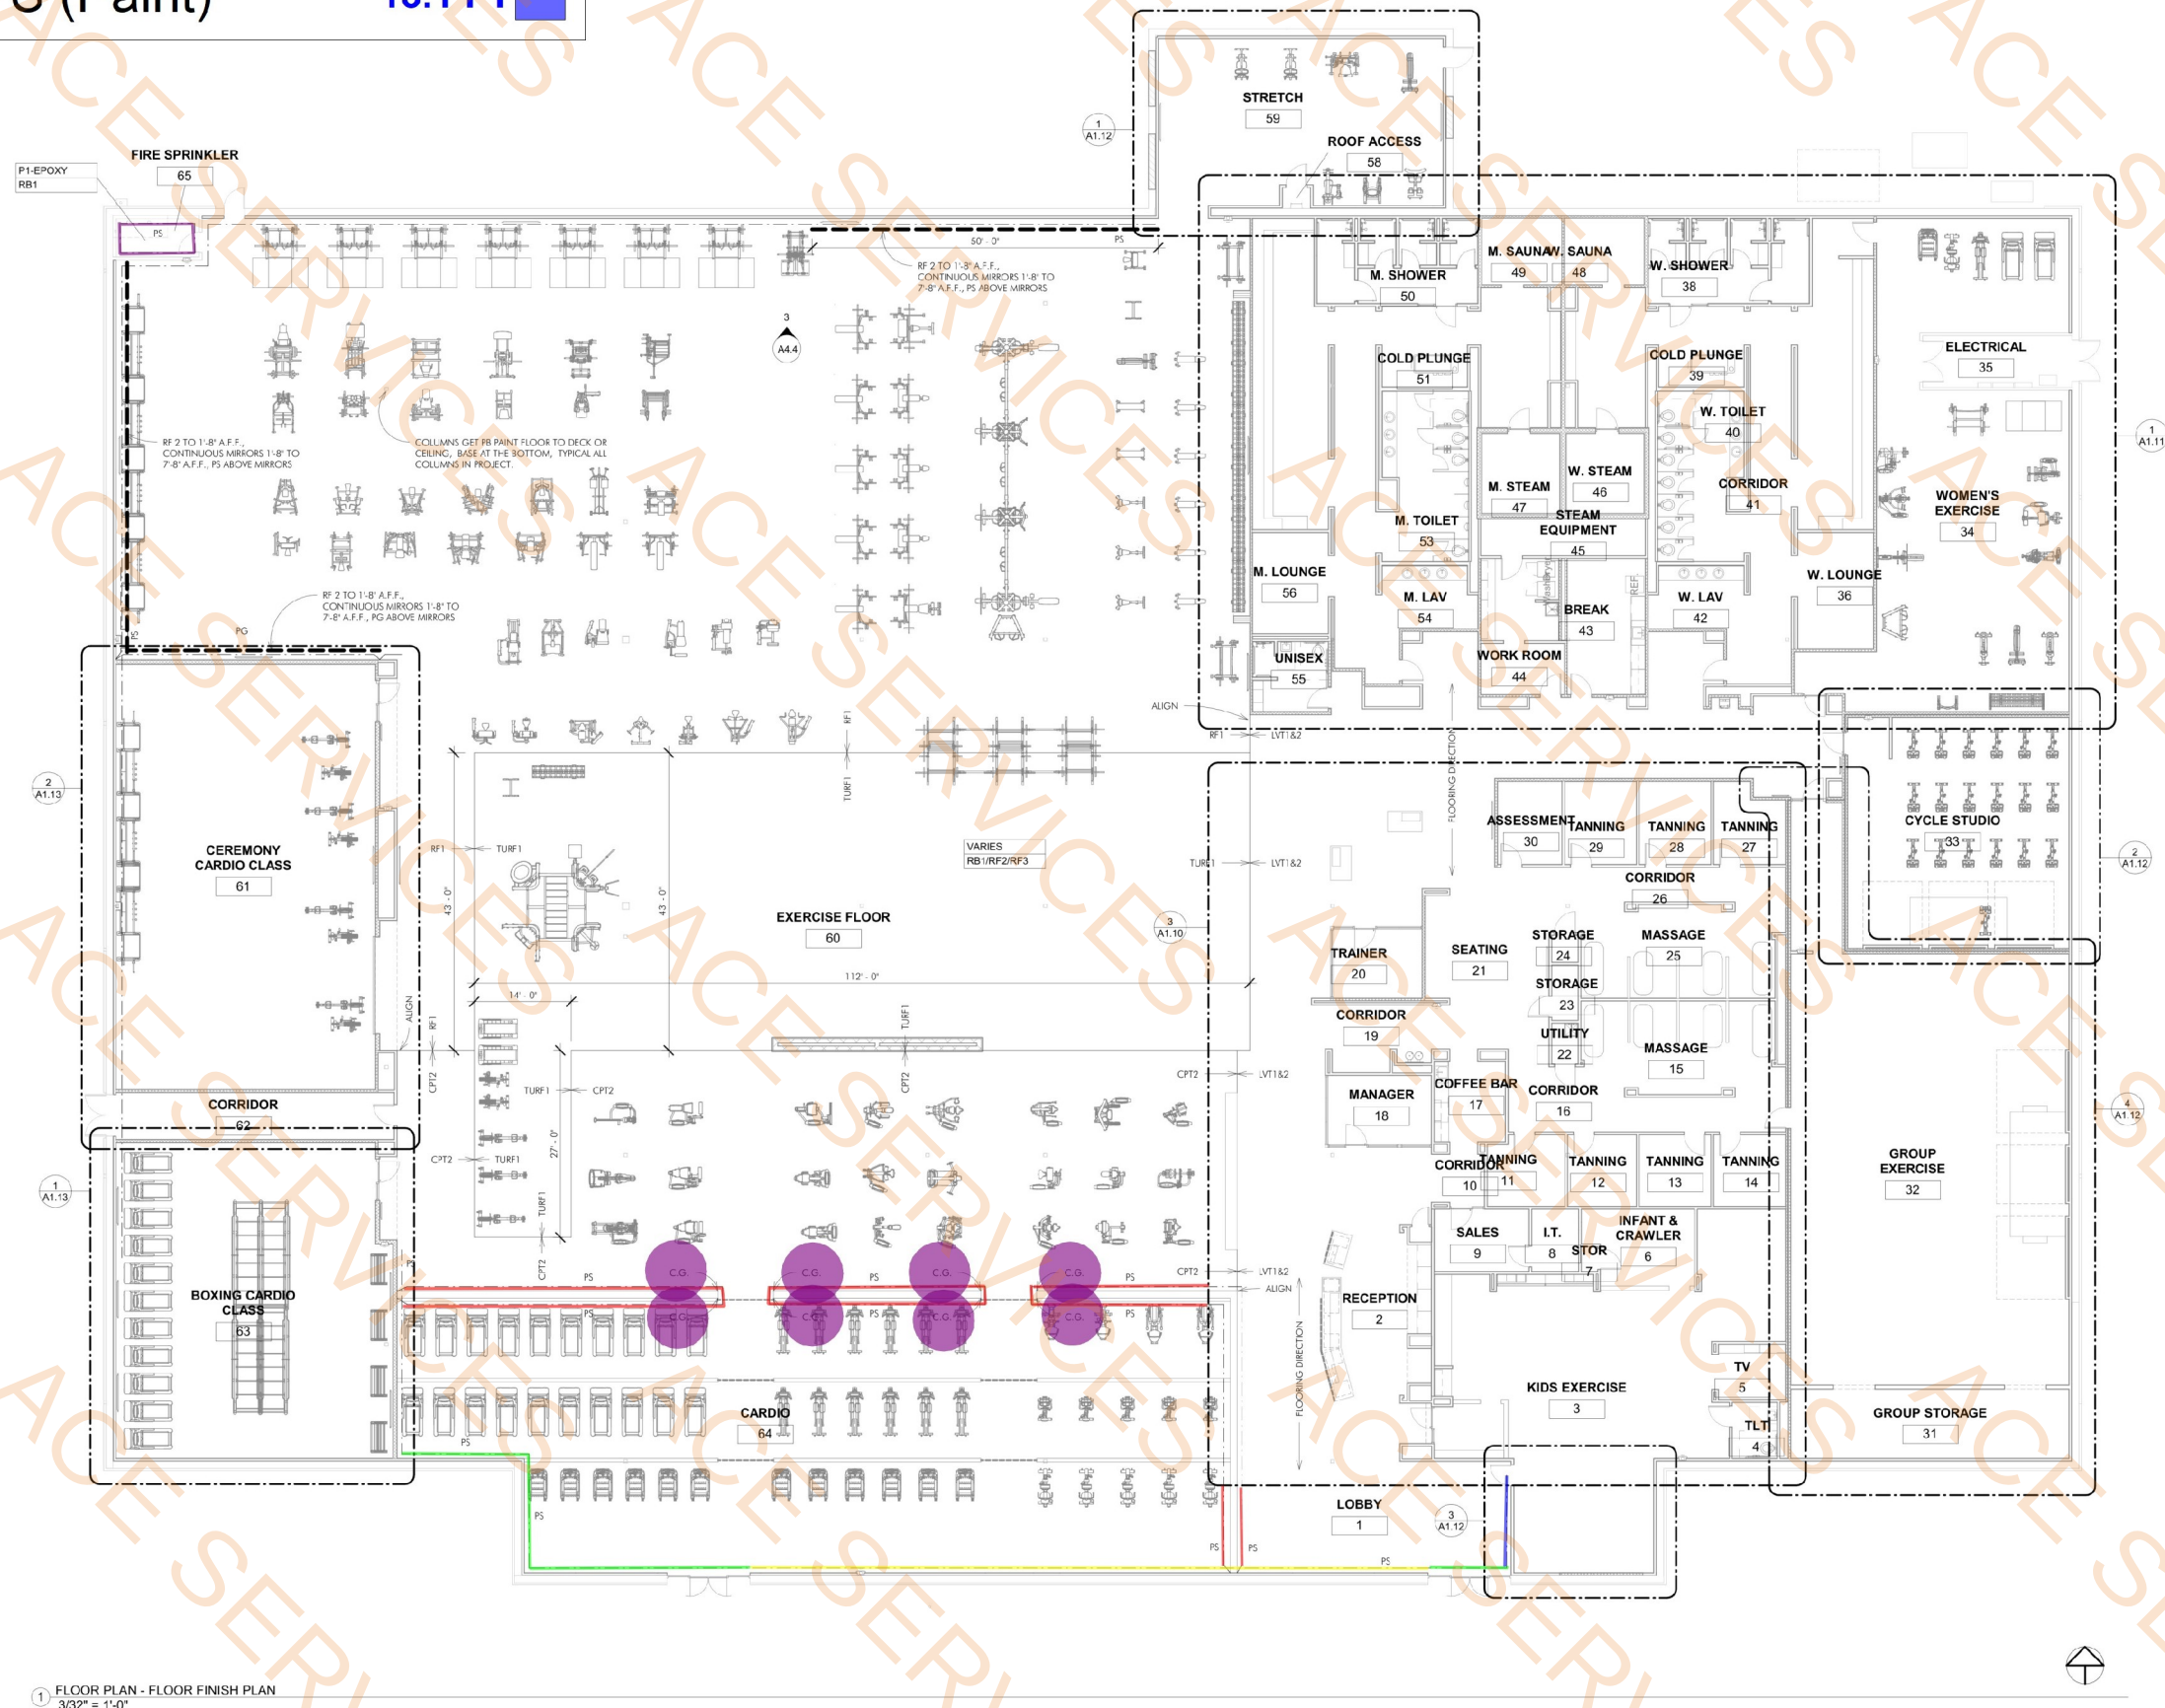

1 FLOOR PLAN - FLOOR FINISH PLAN
3/32" = 1'-0"

NOTE: THE CONTRACT DRAWINGS ARE NOT ORGANIZED SPECIFICALLY FOR ANY CRAFT, TRADE, DISCIPLINE, OR SUBCONTRACT. THEREFORE, ADDITIONAL RELATED INFORMATION MAY BE INCLUDED IN OTHER CONTRACT DRAWINGS AND SPECIFICATIONS EVEN THOUGH NOT SPECIFICALLY NOTED ON THIS DOCUMENT. IT IS THE RESPONSIBILITY OF EACH PARTY TO REFER TO THE COMPLETE SET OF CONTRACT DRAWINGS AND SPECIFICATIONS, AND NOT TO A PARTIAL OR INCOMPLETE SET OF DOCUMENTS.



Brent Barron Architect

P 6 0 1 . 7 5 0 . 1 7 7 8
114 WOODY HILLS DR. JACKSON, MS 39210

FINISH PLAN
CLUB 4 FITNESS - EL PASO MONTWOOD
11705 MONTWOOD DR. EL PASO, TX 79936
20250321

FOR CONSTRUCTION
JUNE 05, 2025

A1.9



WOODY HILLS DR, MADISON, MS 39110

11703 MOUNTWOOD DR, EL PASO, TX 77730


20250321 11:03 MONDAY

5

C



NOTE: THE CONTRACT DRAWINGS ARE NOT ORGANIZED SPECIFICALLY FOR ANY CRAFT, TRADE, DISCIPLINE, OR SUBCONTRACT. THEREFORE, ADDITIONAL RELATED INFORMATION MAY BE INCLUDED IN OTHER CONTRACT DRAWINGS AND SPECIFICATIONS EVEN THOUGH NOT SPECIFICALLY NOTED ON THIS DOCUMENT. IT IS THE RESPONSIBILITY OF EACH PARTY TO REFER TO THE COMPLETE SET OF CONTRACT DRAWINGS AND SPECIFICATIONS, AND NOT TO A PARTIAL OR INCOMPLETE SET OF DOCUMENTS.

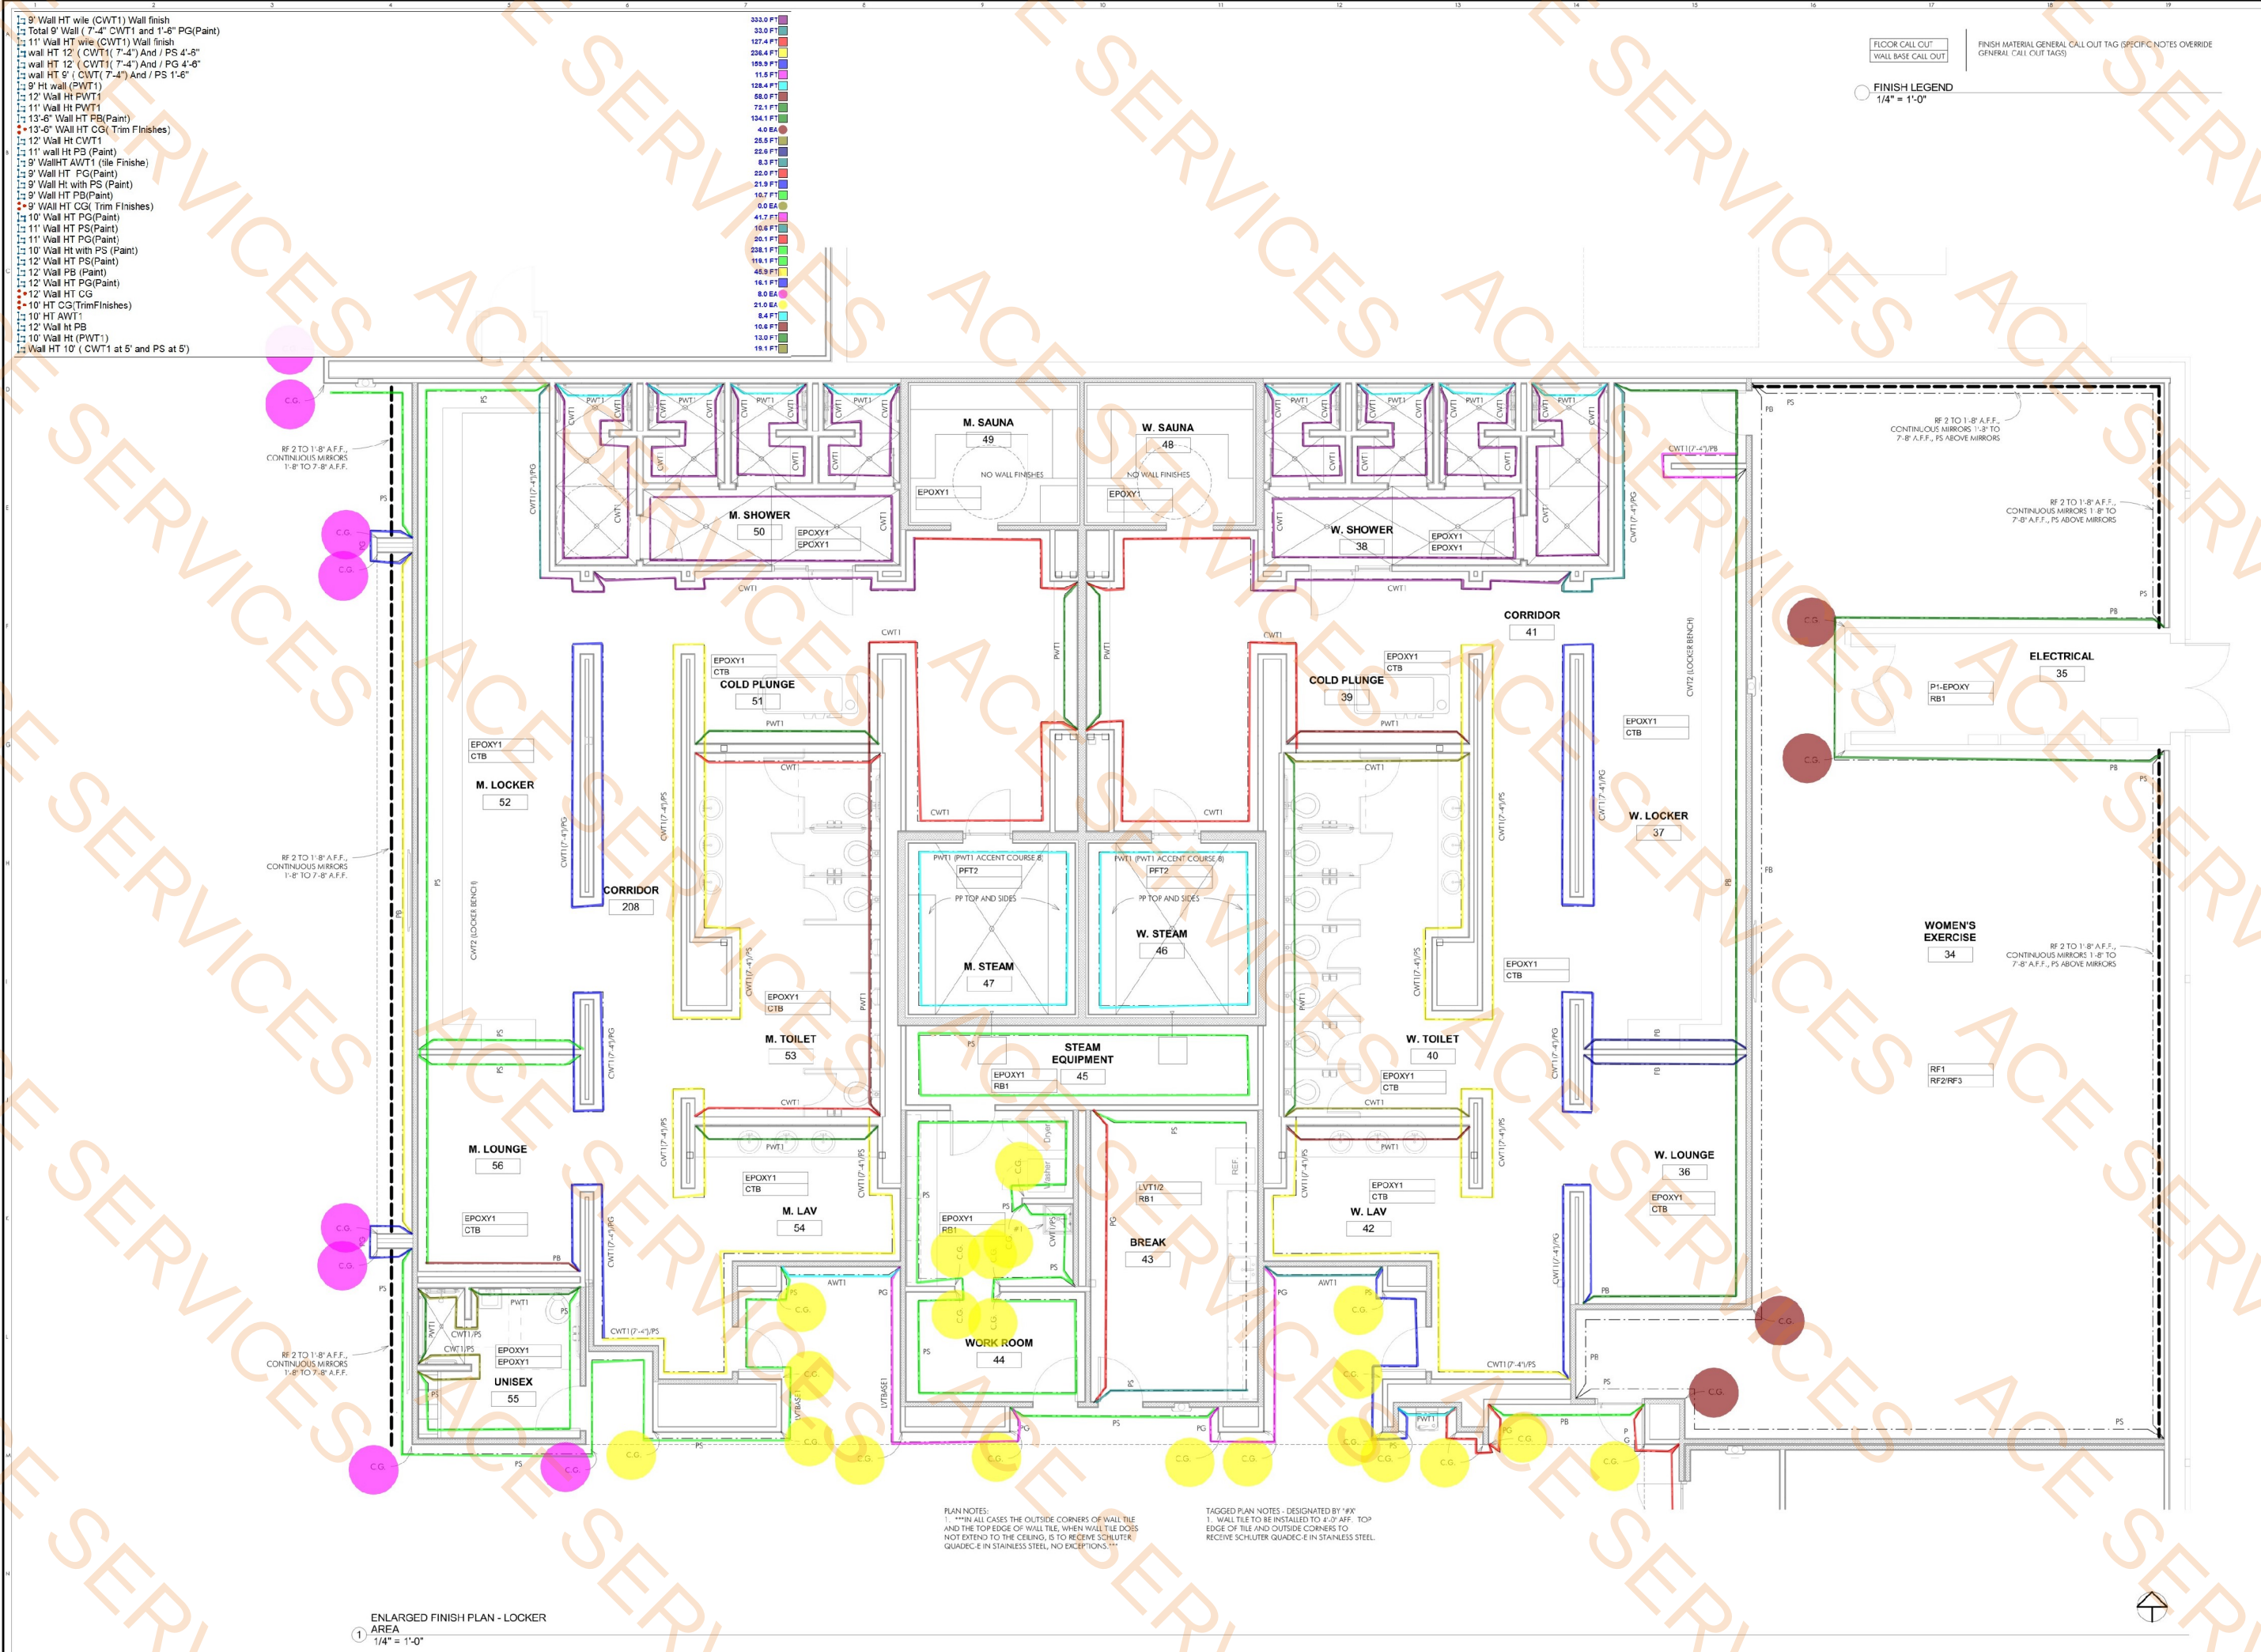



Brent Barron Architect

P 6 0 1 . 7 5 0 . 1 7 7 8

114 WOODY HILLS DR. JACKSON, MS 39210

ENLARGED FINISH PLANS
CLUB 4 FITNESS - EL PASO MONTWOOD

11705 MONTWOOD DR. EL PASO, TX 79936

20250321


FOR CONSTRUCTION
JUNE 05, 2025

A1.12


FLOOR CALL OUT
WALL BASE CALL OUT

FINISH LEGEND
1/4" = 1'-0"


FINISH MATERIAL GENERAL CALL OUT TAG (SPECIFIC NOTES OVERRIDE
GENERAL CALL OUT TAGS)

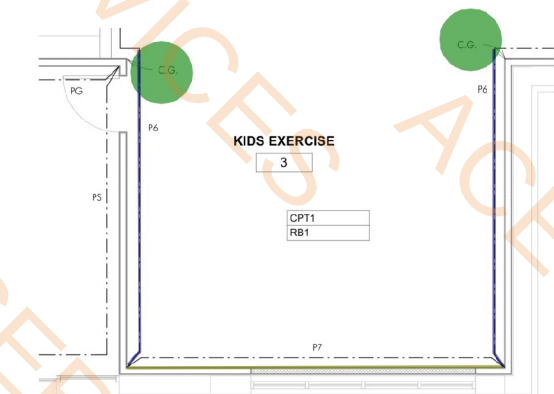

3 ENLARGED FINISH PLANS...
1/4" = 1'-0"

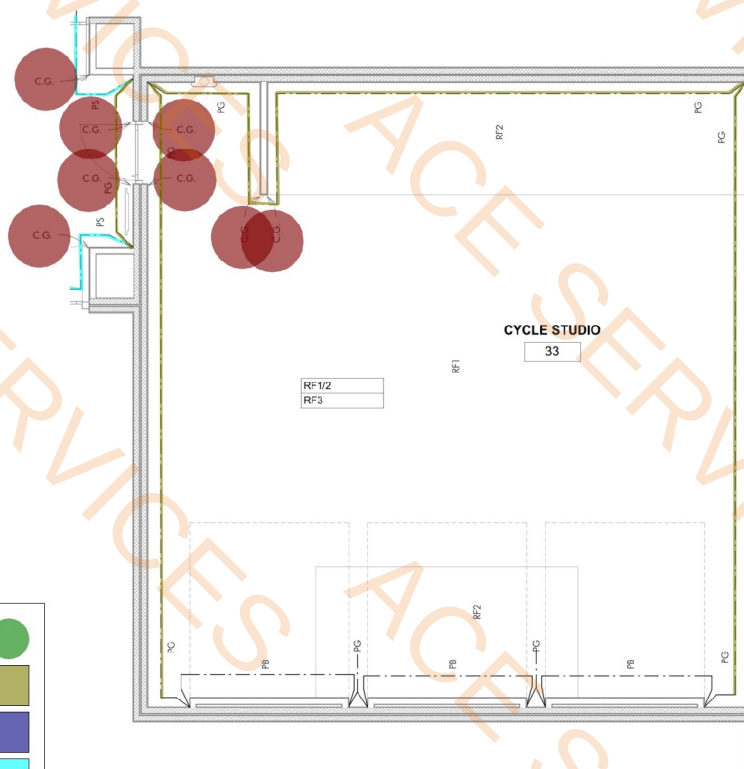


2 ENLARGED FINISH PLAN - CYCLE
STUDIO
1/4" = 1'-0"

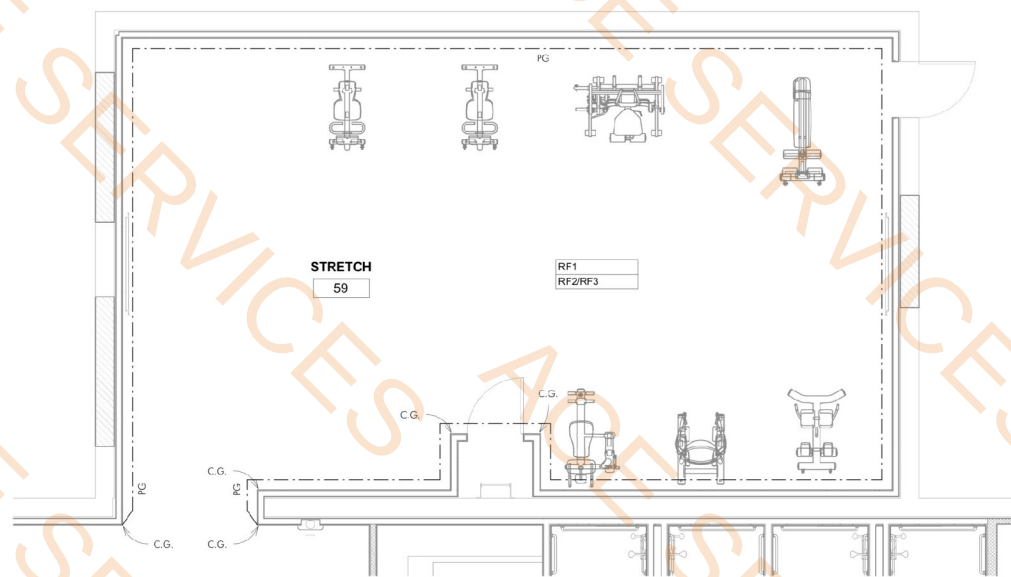

1 ENLARGED FINISH PLAN - STRETCH
1/4" = 1'-0"

23'-5" wall HT CG (Trim Finish)	2.0 EA
23'-5" Wall HT with P7(Paint)	20.2 FT
Wall HT 23'-5" P6(Paint)	34.2 FT
13'-6" Wall HT PS(Paint)	290.1 FT
13'-6" Wall HT CG(Trim Finish...)	14.0 EA
13'-6" Wall HT PB(Paint)	10.8 FT
13'-6" Wall HT PG(Paint)	132.1 FT

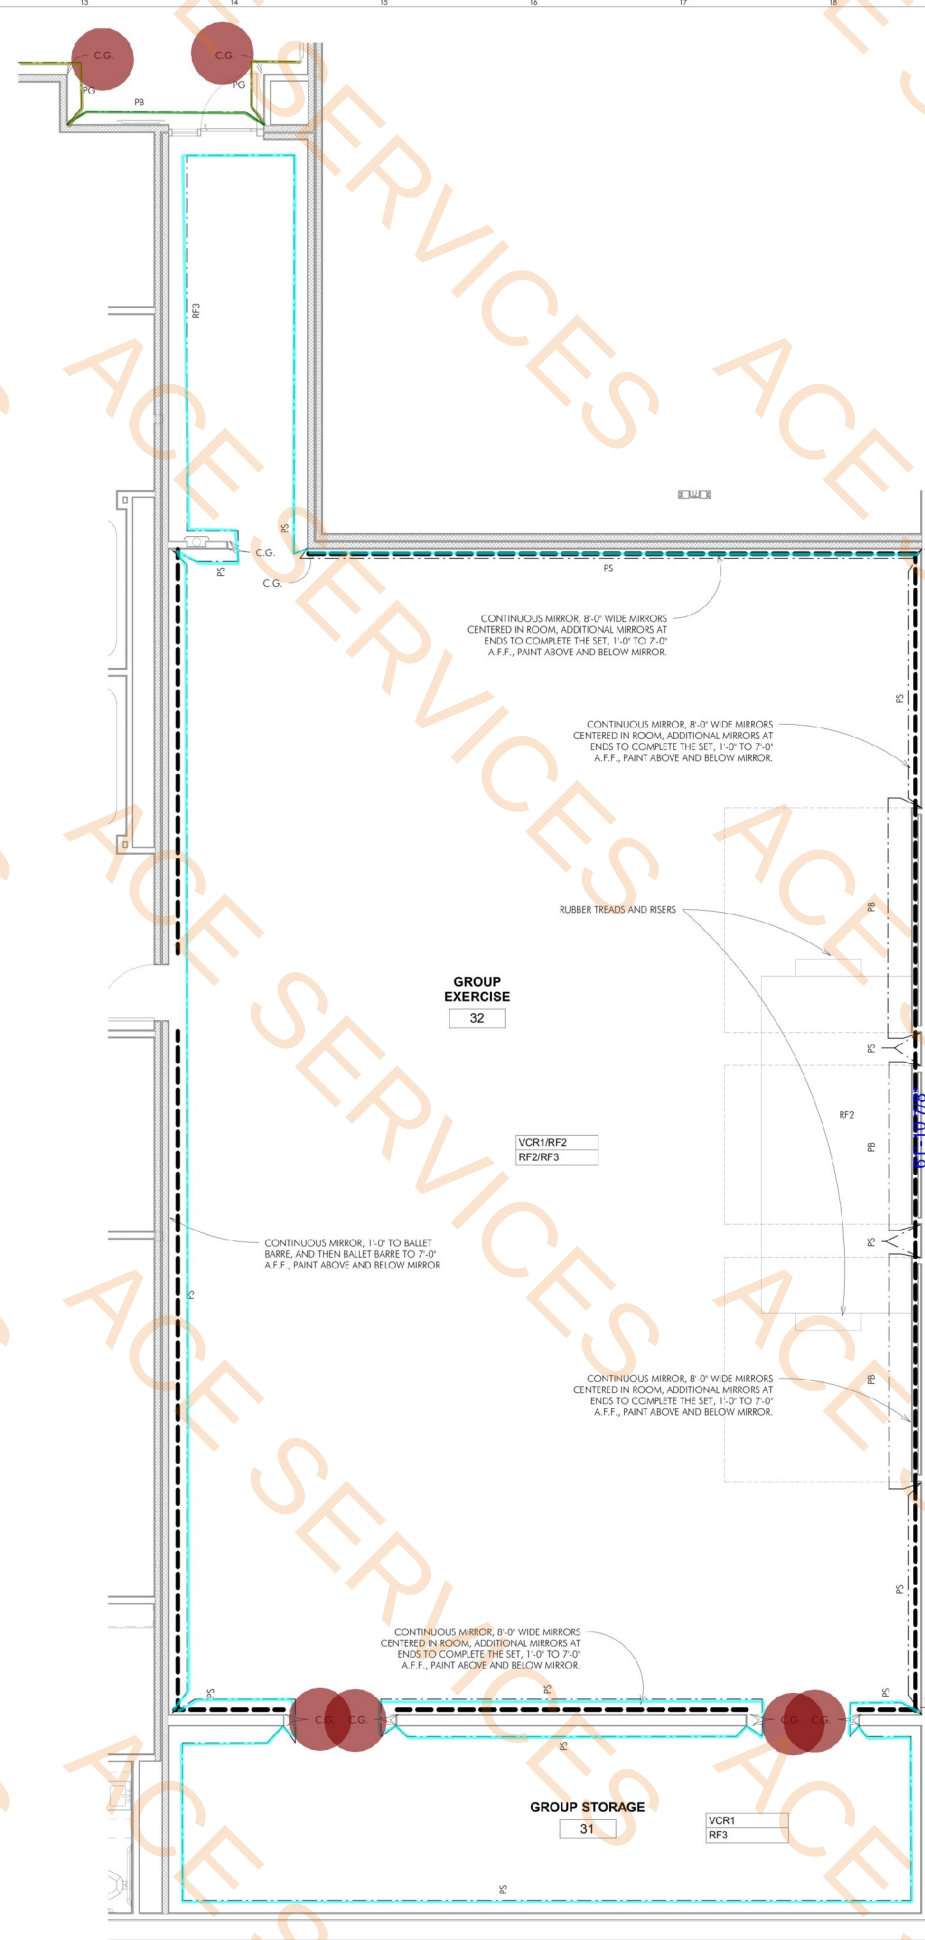

4 ENLARGED FINISH PLAN - GROUP
EXERCISE
1/4" = 1'-0"

NOTE: THE CONTRACT DRAWINGS ARE NOT ORGANIZED SPECIFICALLY FOR ANY CRAFT, TRADE, DISCIPLINE, OR SUBCONTRACT. THEREFORE, ADDITIONAL RELATED INFORMATION MAY BE INCLUDED IN OTHER CONTRACT DRAWINGS AND SPECIFICATIONS EVEN
ALTHOUGH NOT SPECIFICALLY NOTED ON THIS DOCUMENT. IT IS THE RESPONSIBILITY OF EACH PARTY TO REFER TO THE COMPLETE SET OF CONTRACT DRAWINGS AND SPECIFICATIONS, AND NOT TO A PARTIAL OR INCOMPLETE SET OF DOCUMENTS.

20'-9" Wall Ht with Paint (PS)
21' Wall Ht with CG (Trim Finish)

87.7 FT
6.0 EA

FLOOR CALL OUT
WALL BASE CALL OUT


FINISH MATERIAL GENERAL CALL OUT TAG (SPECIFIC NOTES OVERRIDE
GENERAL CALL OUT TAGS)

FINISH LEGEND
1/4" = 1'-0"




Brent Barron Architect

P 6 0 1 . 7 5 0 . 1 7 7 8
114 WOODY HILLS DR, JACKSON, MS 39210

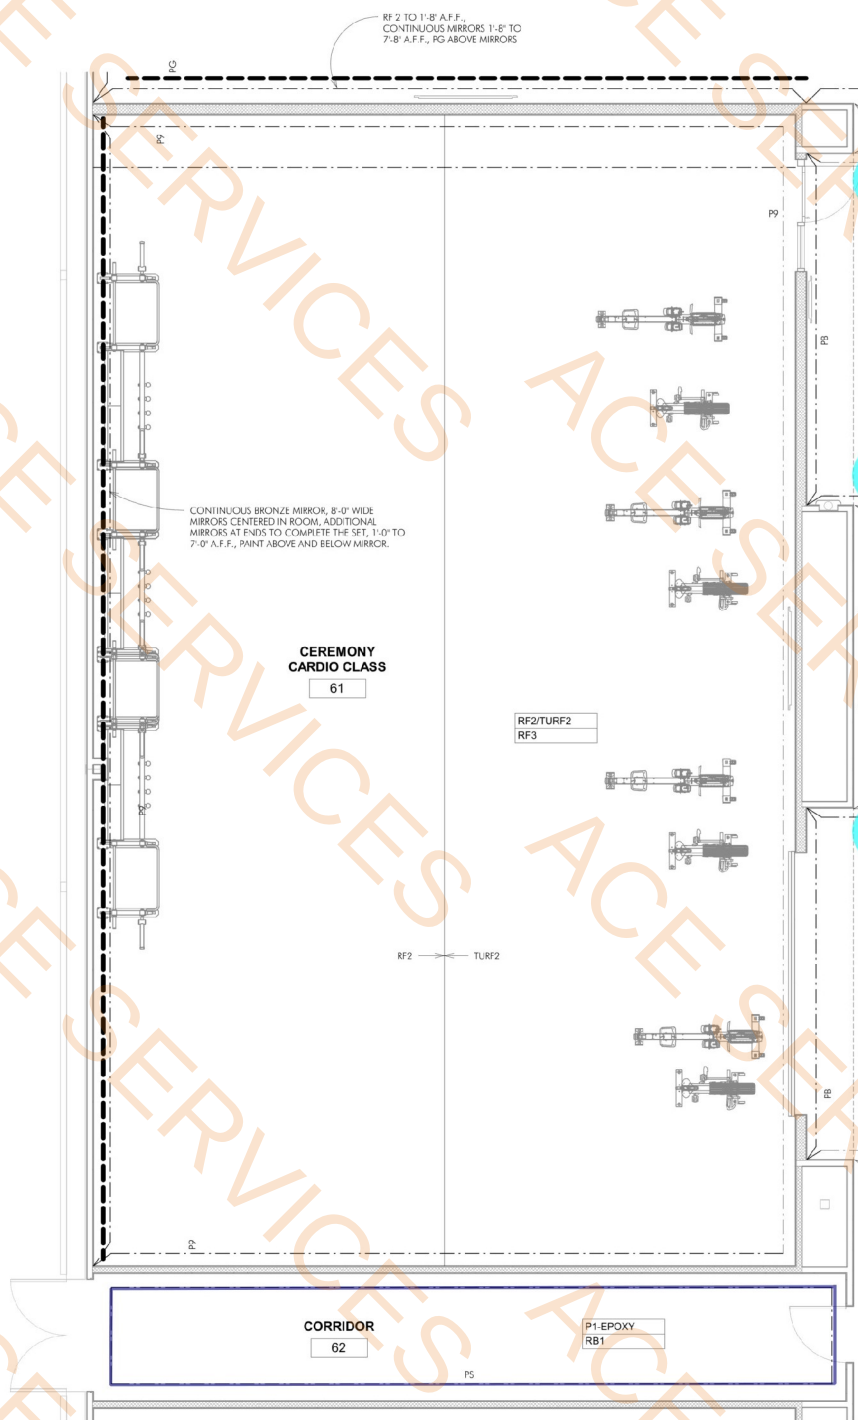

ENLARGED FINISH PLAN - CEREMONY
CARDIO
1/4" = 1'-0"

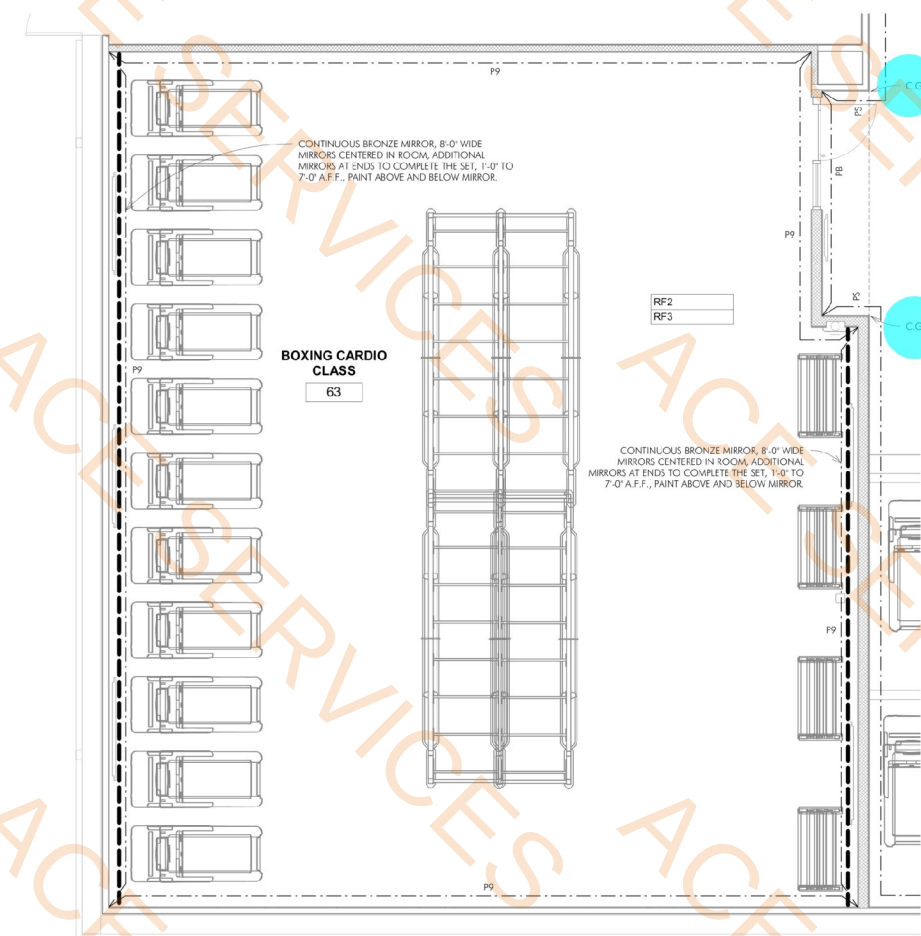

ENLARGED FINISH PLAN - BOXING
CARDIO
1/4" = 1'-0"

NOTE: THE CONTRACT DRAWINGS ARE NOT ORGANIZED SPECIFICALLY FOR ANY CRAFT, TRADE, DISCIPLINE, OR SUBCONTRACT. THEREFORE, ADDITIONAL RELATED INFORMATION MAY BE INCLUDED IN OTHER CONTRACT DRAWINGS AND SPECIFICATIONS EVEN THOUGH NOT SPECIFICALLY NOTED ON THIS DOCUMENT. IT IS THE RESPONSIBILITY OF EACH PARTY TO REFER TO THE COMPLETE SET OF CONTRACT DRAWINGS AND SPECIFICATIONS, AND NOT TO A PARTIAL OR INCOMPLETE SET OF DOCUMENTS.

ENLARGED FINISH PLANS

CLUB 4 FITNESS - EL PASO MONTWOOD

11705 MONTWOOD DR, EL PASO, TX 79936

20250321

FOR CONSTRUCTION
JUNE 05, 2025

A1.13



Brent Barron Architect

P 6 0 1 . 7 5 0 . 1 7 8


11705 MONTWOOD DR, EL PASO, TX 79936

INTERIOR ELEVATIONS
CLUB 4 FITNESS - EL PASO MONTWOOD

20250321

FOR CONSTRUCTION
JUNE 05, 2025

A4.1

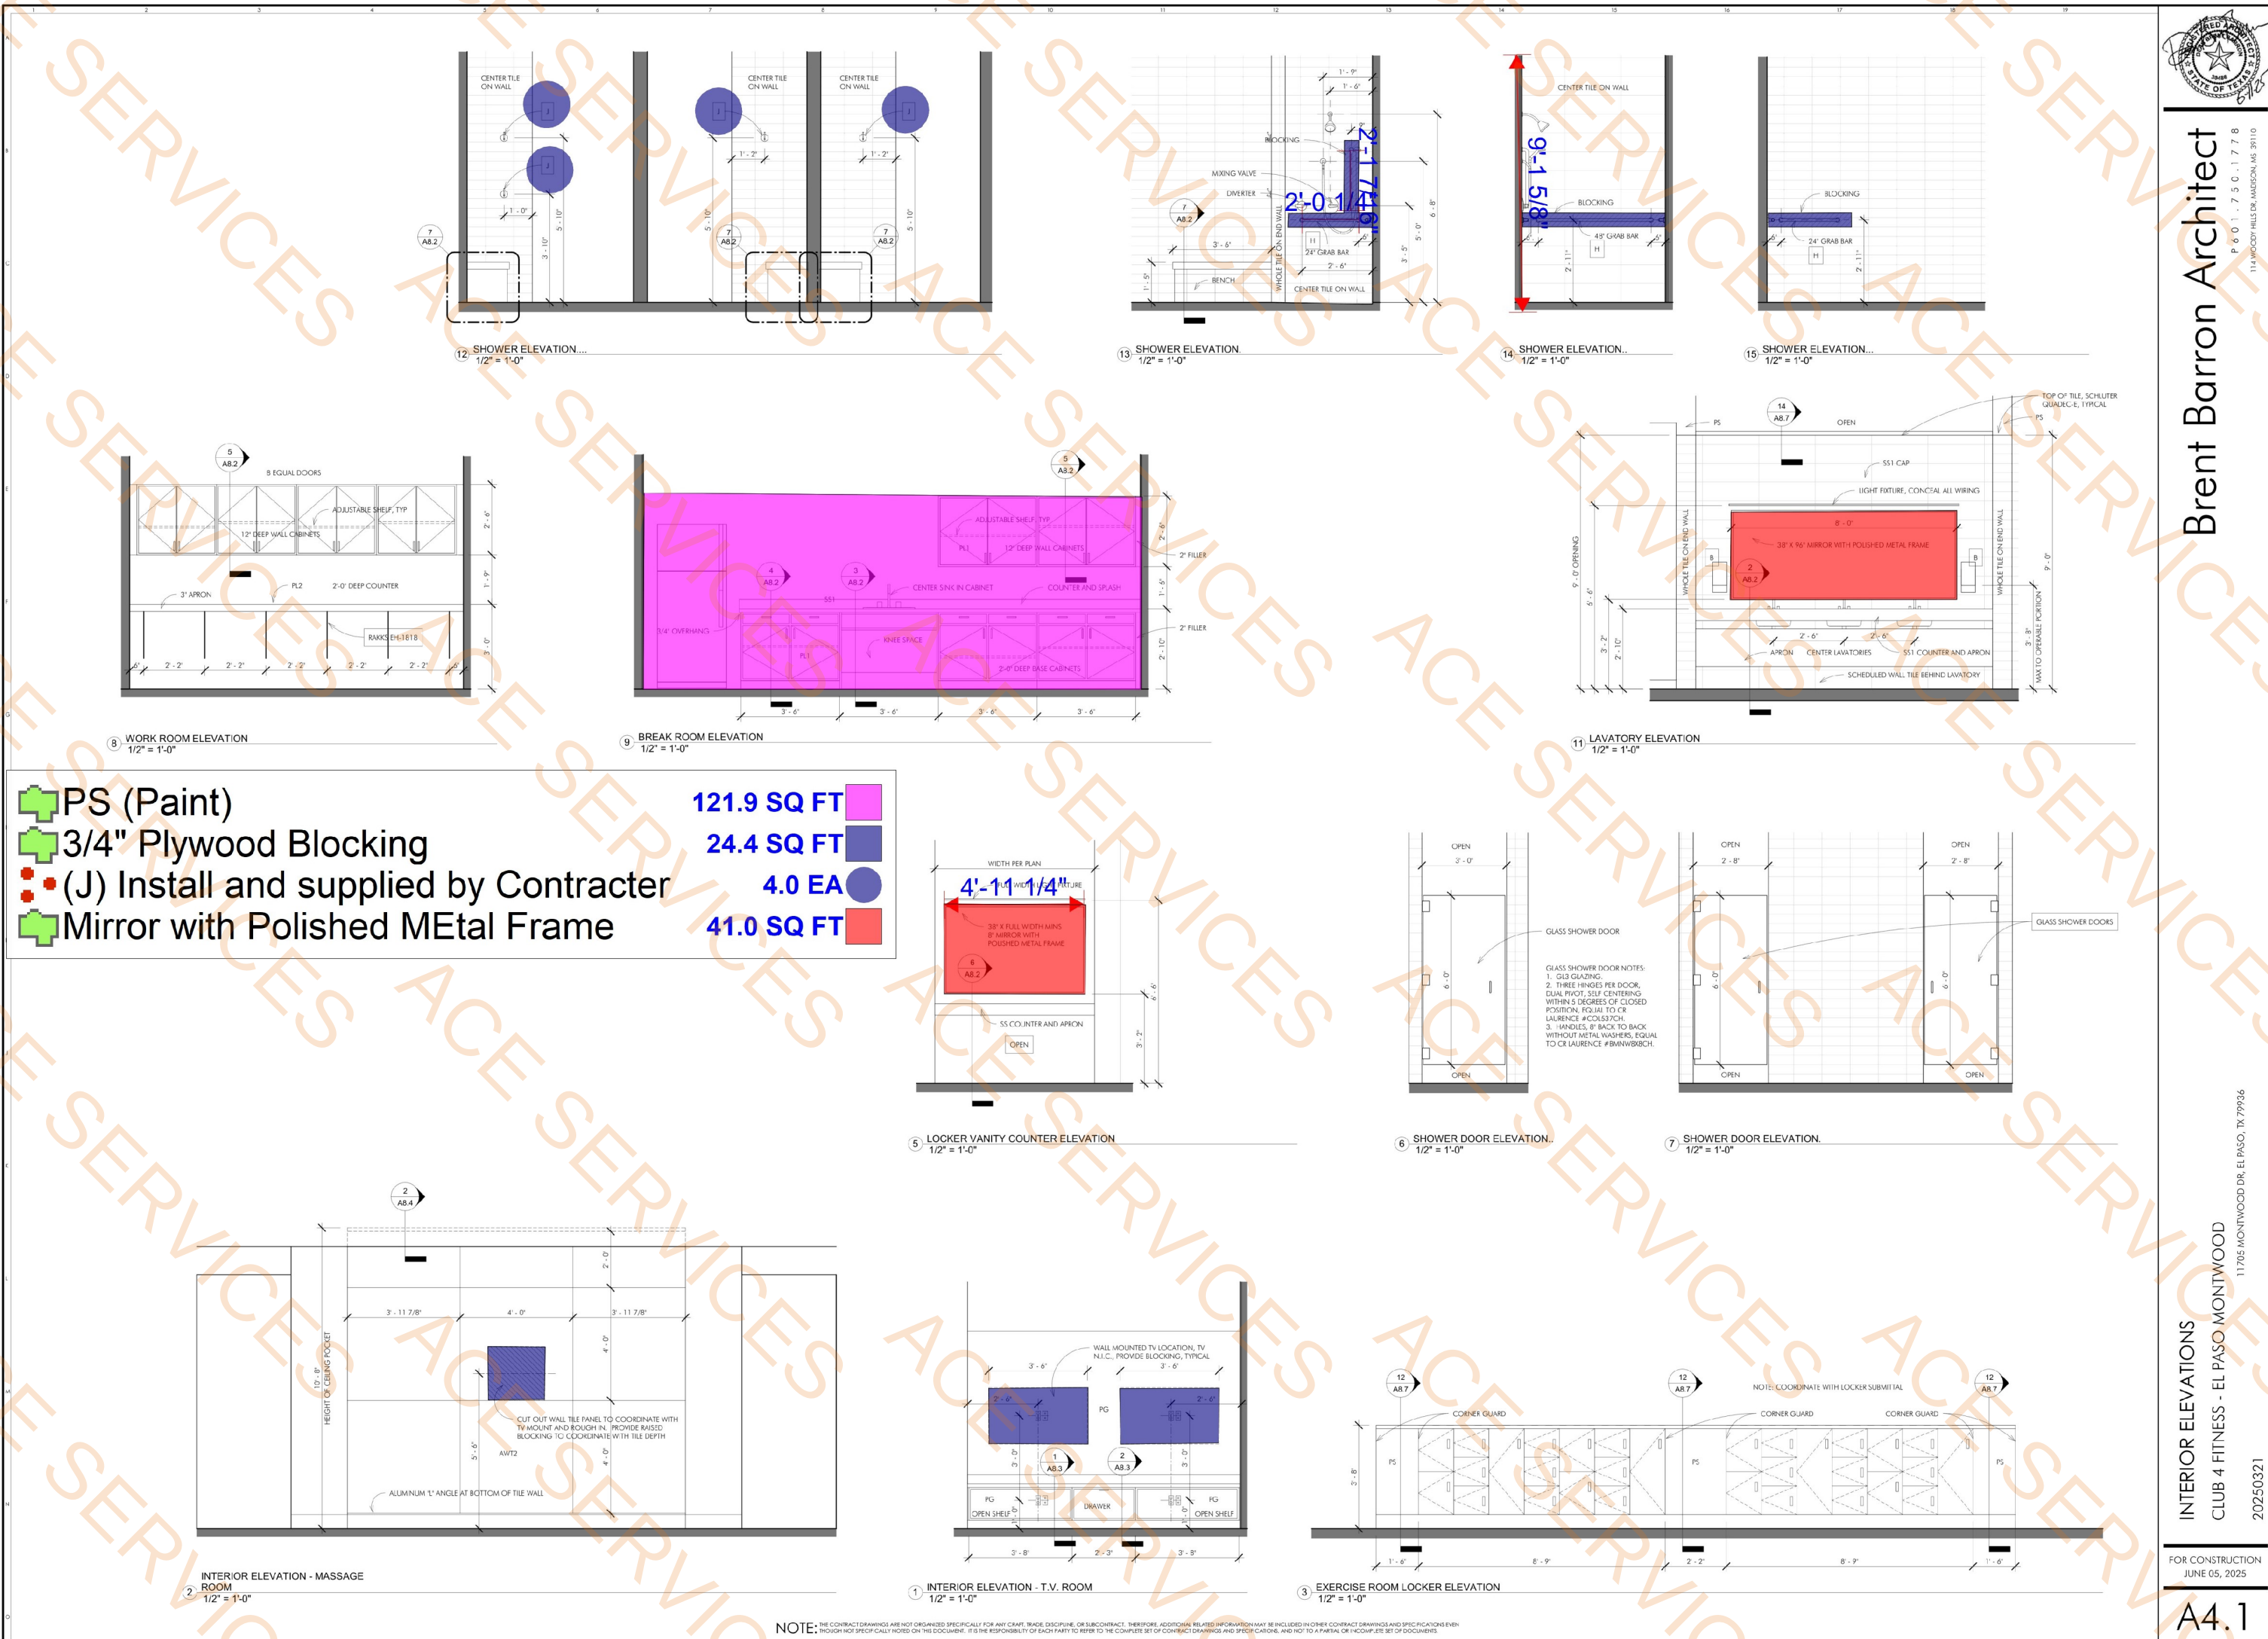




20250321


FOR CONSTRUCTION
JUNE 05, 2025

NOTE: THE CONTRACT DRAWINGS ARE NOT ORGANIZED SPECIFICALLY FOR ANY CRAFT, TRADE, DISCIPLINE, OR SUBCONTRACT. THEREFORE, ADDITIONAL RELATED INFORMATION MAY BE INCLUDED IN OTHER CONTRACT DRAWINGS AND SPECIFICATIONS EVEN THOUGH NOT SPECIFICALLY NOTED ON THIS DOCUMENT. IT IS THE RESPONSIBILITY OF EACH PARTY TO REFER TO THE COMPLETE SET OF CONTRACT DRAWINGS AND SPECIFICATIONS, AND NOT TO A PARTIAL OR INCOMPLETE SET OF DOCUMENTS.


	P5 (PAINT	580.0 SQ FT
	PS (Paint)	1182.6 SQ FT
	PB(Painting)	896.5 SQ FT
	PG (Paint)	530.0 SQ FT
	3/4" Plywood Blo...	122.7 SQ FT

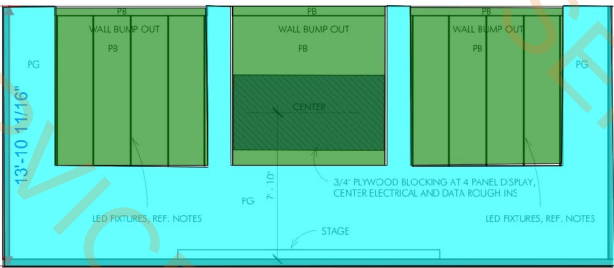


2 INTERIOR ELEVATION - CYCLE STUDIO
1/4" = 1'-0"

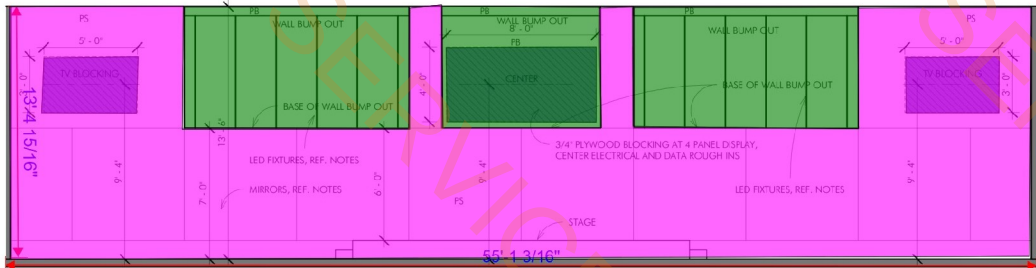


4 INTERIOR ELEVATION - GROUP
EXERCISE
1/4" = 1'-0"

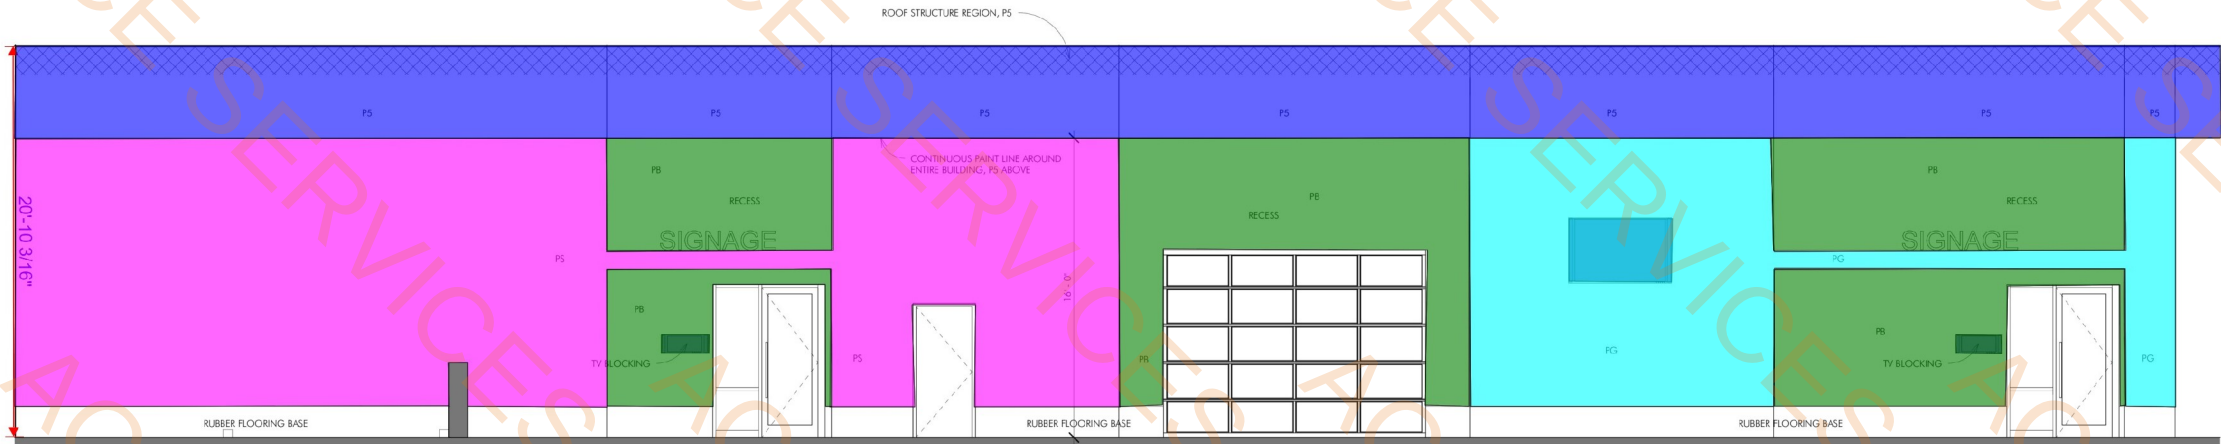


1 INTERIOR ELEVATION - EXERCISE
FLOOR.....
1/4" = 1'-0"

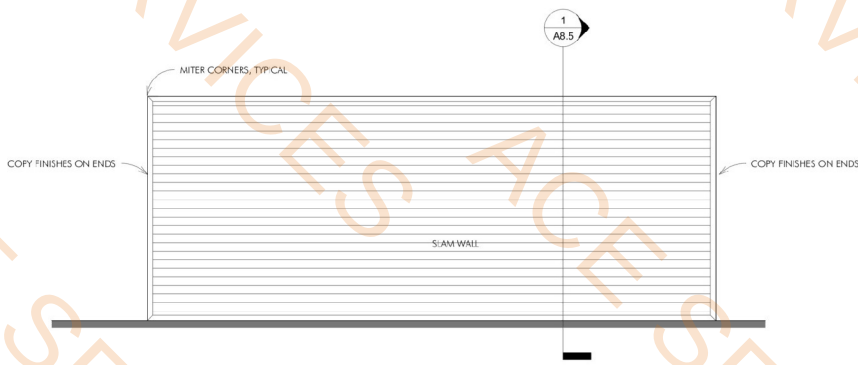


5 INTERIOR ELEVATION - SLAM WALL..
1/4" = 1'-0"

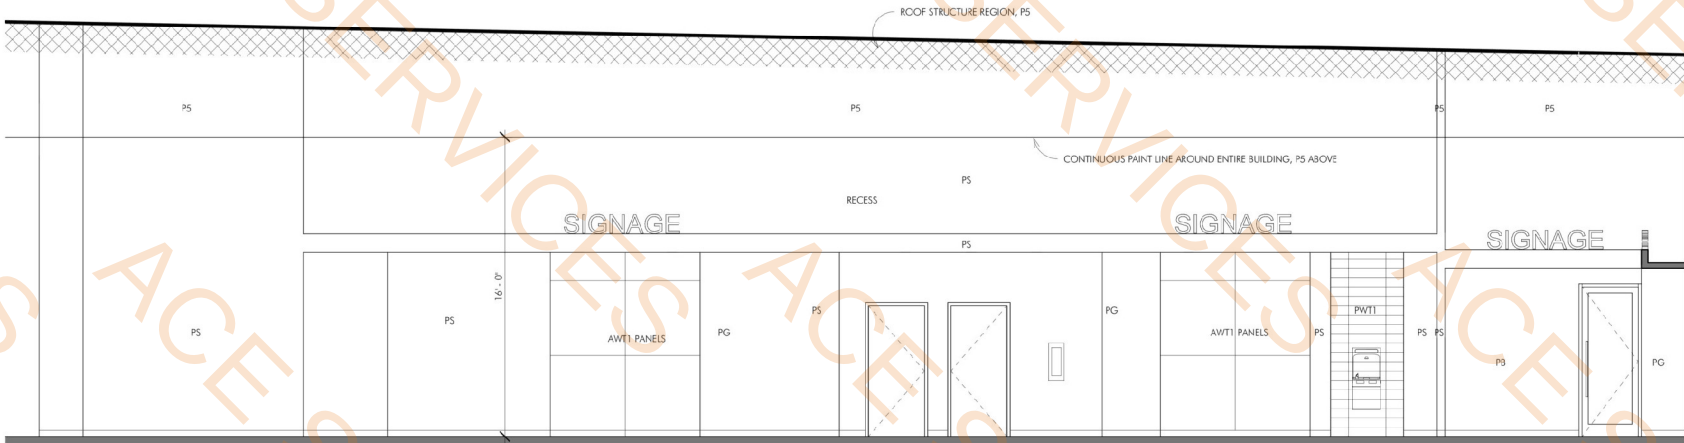


3 INTERIOR ELEVATION - EXERCISE
FLOOR.....
1/4" = 1'-0"

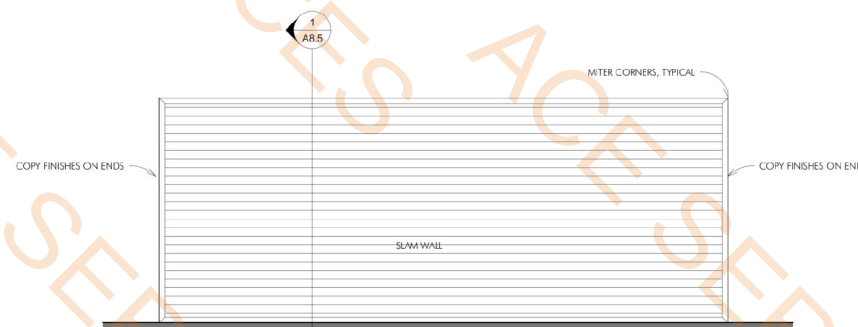

7 INTERIOR ELEVATION - SLAM WALL..
1/4" = 1'-0"

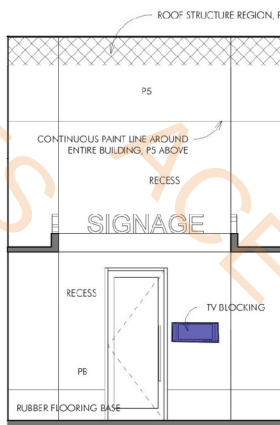

8 INTERIOR ELEVATION - EXERCISE
FLOOR.....
1/4" = 1'-0"

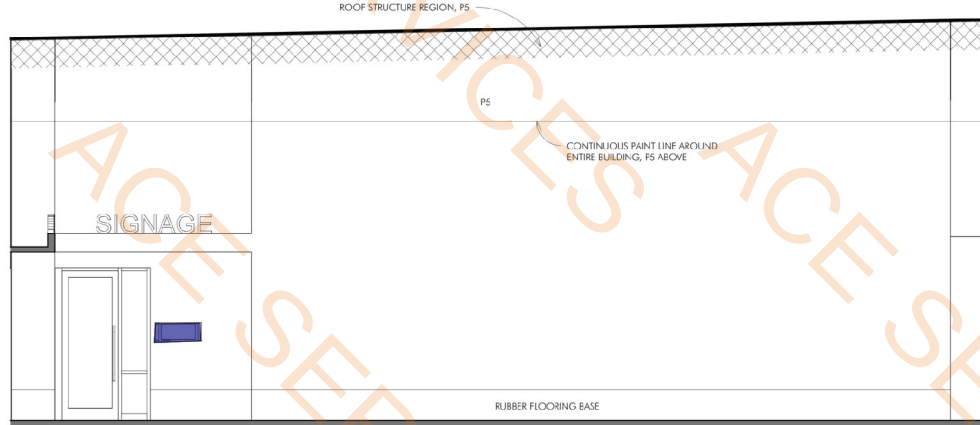

6 INTERIOR ELEVATION - EXERCISE
FLOOR.....
1/4" = 1'-0"

NOTE: THE CONTRACT DRAWINGS ARE NOT ORGANIZED SPECIFICALLY FOR ANY ART, TRADE, DISCIPLINE, OR SUBCONTRACTOR. THEREFORE, ADDITIONAL RELATED INFORMATION MAY BE INCLUDED IN OTHER CONTRACT DRAWINGS AND SPECIFICATIONS EVEN THOUGH NOT SPECIFICALLY NOTED ON THIS DOCUMENT. IT IS THE RESPONSIBILITY OF EACH PARTY TO REFER TO THE COMPLETE SET OF CONTRACT DRAWINGS AND SPECIFICATIONS, AND NOT TO A PARTIAL OR INCOMPLETE SET OF DOCUMENTS.



Brent Barron Architect

P 6 0 1 . 7 5 0 . 1 7 8
114 WOODY HILLS DR, JACKSON, MS 39210

INTERIOR ELEVATIONS
CLUB 4 FITNESS - EL PASO MONTWOOD
11705 MONTWOOD DR, EL PASO, TX 79936
20250321

FOR CONSTRUCTION
JUNE 05, 2025

A4.3




11705 MONTWOOD DR, EL PASO, TX 77730

INTERIOR ELEVATIONS
CLUB 4 FITNESS - EL PASO MONTWOOD


FOR CONSTRUCTION
JUNE 05, 2025

A4.4

	P5 (PAINT	386.4 SQ FT	
	PS (Paint)	705.0 SQ FT	
	PG (Paint)	83.5 SQ FT	
	PB(Painting)	18.3 SQ FT	
	P4(Paint)	8.2 SQ FT	
	3/4" Plywood Blocking	9.6 SQ FT	
	AWT1 (Wall Finishes)	37.9 SQ FT	
	SPS Wall Panel	25.3 SQ FT	

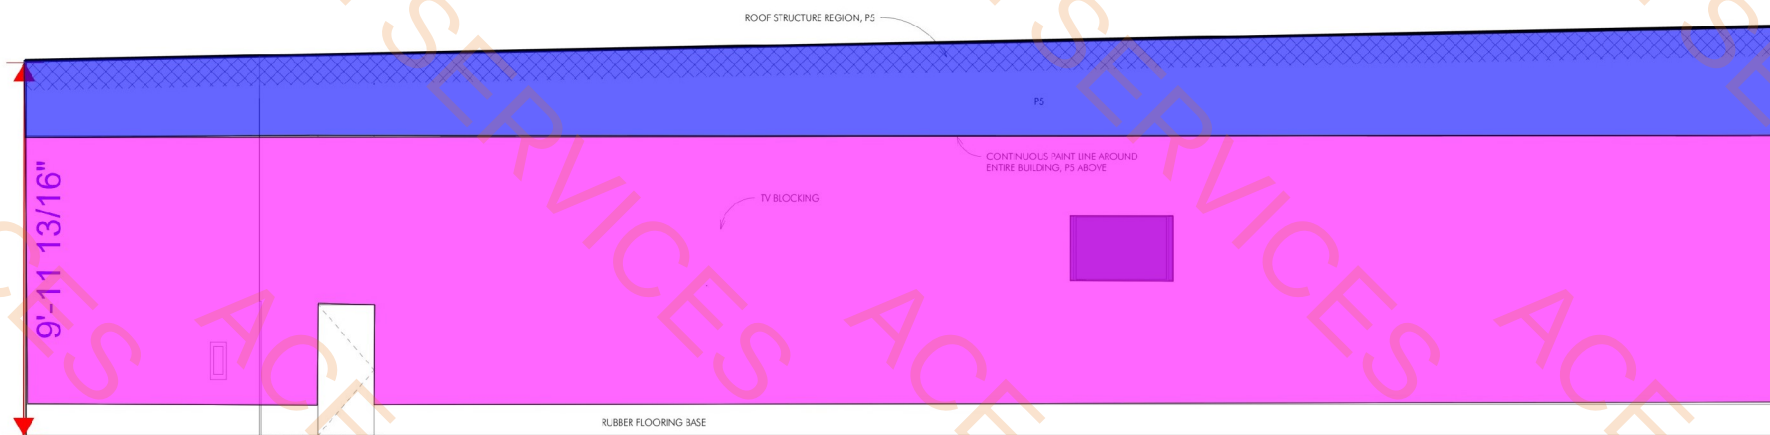

1 INTERIOR ELEVATION - EXERCISE FLOOR.
1/4" = 1'-0"

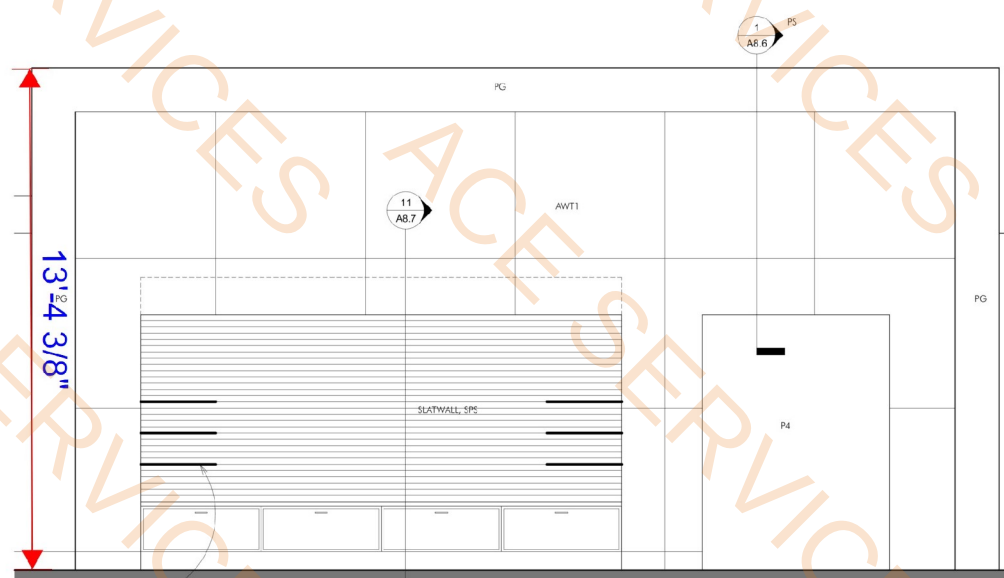


BLACK PLASTIC LAMINATE SHELVES, 24" X 12" X 1-1/2".
PROVIDE (8) 12" BLACK SHELF BRACKETS AND (4) 16" & 18" BLACK BRACKETS COMPATIBLE WITH SUPPLIED FLAT WALL.

NOTE: ANY JOINTS IN THE SLAT WALL SHOULD BE STAGGERED


② INTERIOR ELEVATION - RECEPTION
1/2" = 1'-0"



INTERIOR ELEVATION - EXERCISE
FLOOR. .
③ $1/4" = 1'-0"$

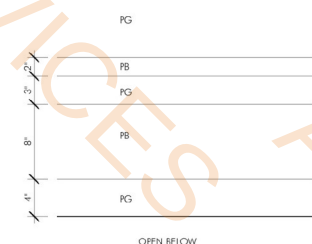


④ PAINT LINE DETAIL
1 1/2" = 1'-0"

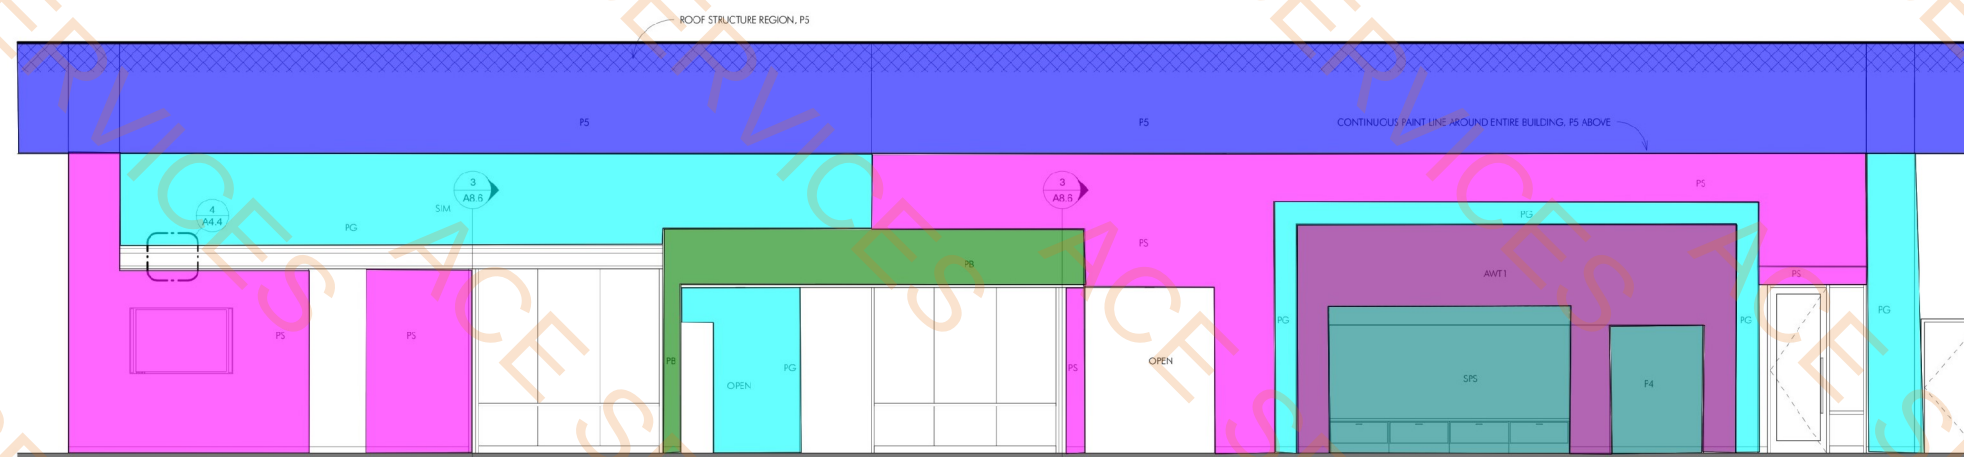


5 INTERIOR ELEVATION - OFFICES
1/4" = 1'-0"

NOTE: THE CONTRACT DRAWINGS ARE NOT ORGANIZED SPECIFICALLY FOR ANY CRAFT, TRADE, DISCIPLINE, OR SUBCONTRACT, THEREFORE, ADDITIONAL RELATED INFORMATION MAY BE INCLUDED IN OTHER CONTRACT DRAWINGS AND SPECIFICATIONS EVEN THOUGH NOT SPECIFICALLY NOTED ON THIS DOCUMENT. IT IS THE RESPONSIBILITY OF EACH PARTY TO REFER TO THE COMPLETE SET OF CONTRACT DRAWINGS AND SPECIFICATIONS, AND NOT TO A PARTIAL OR INCOMPLETE SET OF DOCUMENTS.


- P5 (PAINT) 1698.3 SQ FT
- PS (Paint) 2934.9 SQ FT
- PG (Paint) 710.0 SQ FT
- PB(Painting) 613.0 SQ FT
- 3/4" Plywood Blocking 76.7 SQ FT

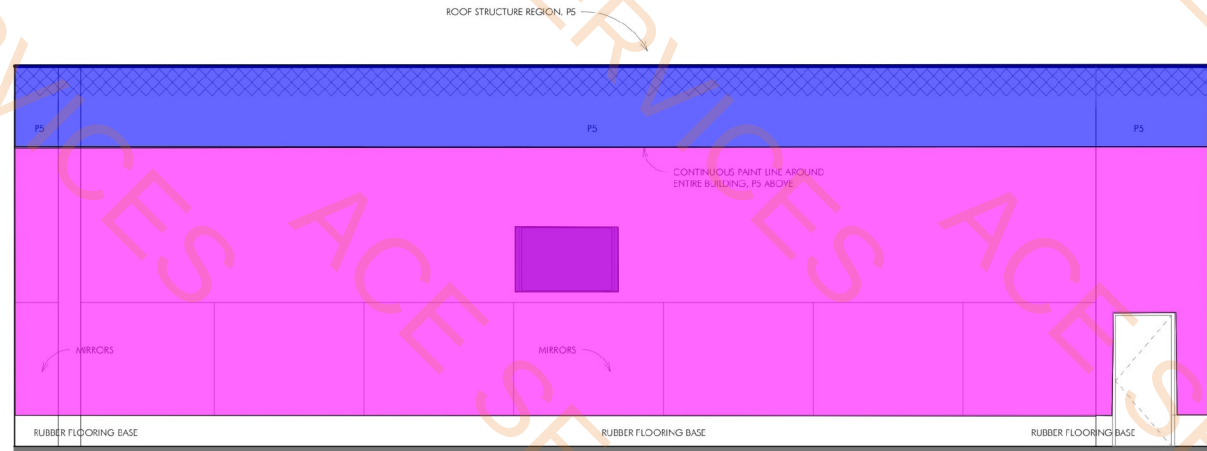


INTERIOR ELEVATION - EXERCISE FLOOR
1/4" = 1'-0"

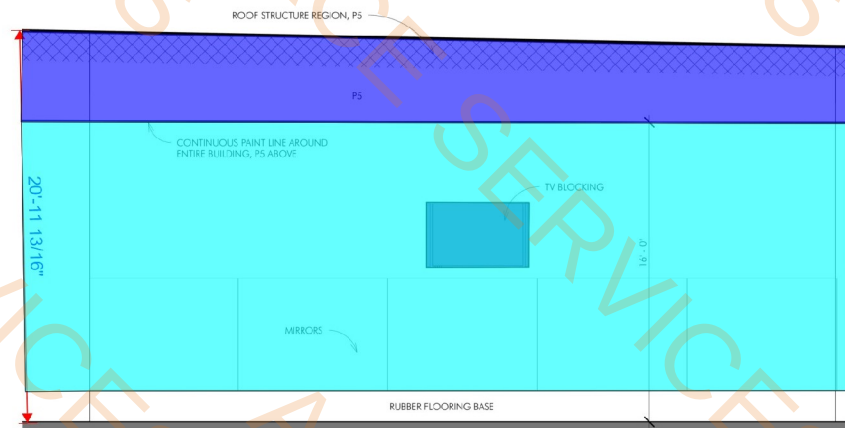

INTERIOR ELEVATION - EXERCISE FLOOR
1/4" = 1'-0"

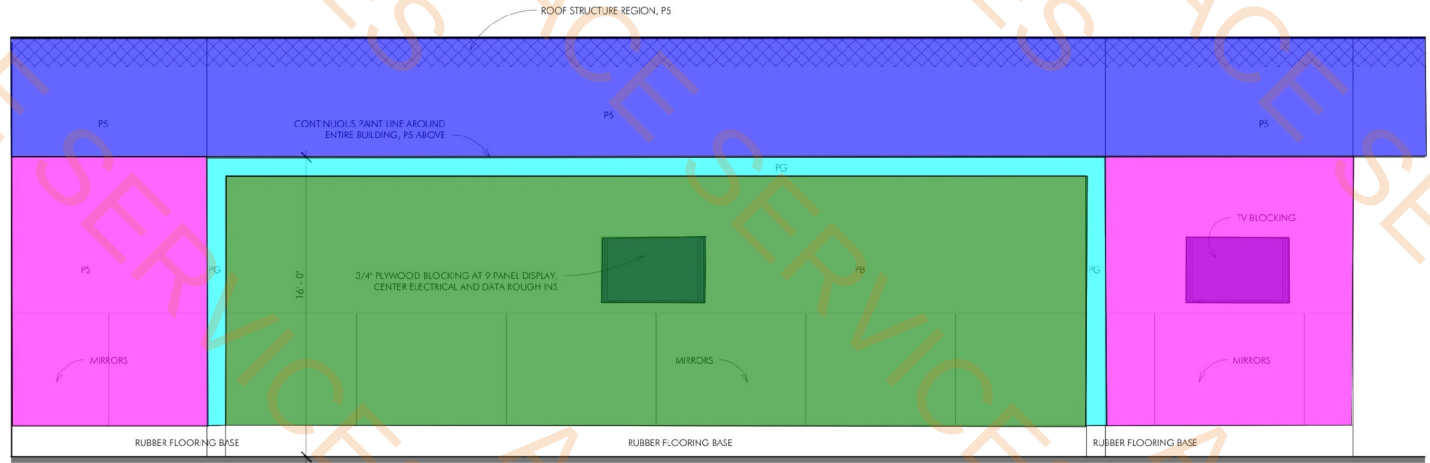

INTERIOR ELEVATION - EXERCISE FLOOR
1/4" = 1'-0"

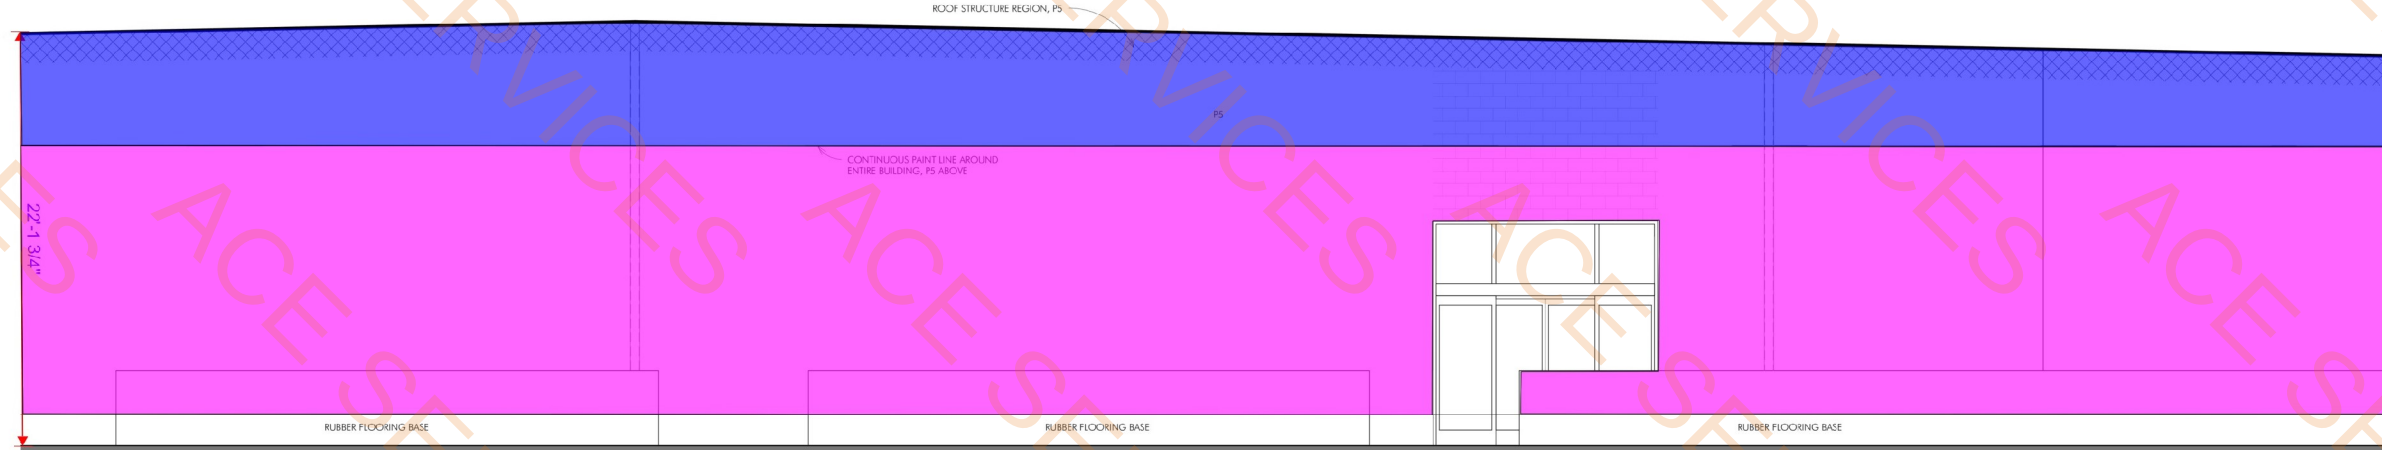

INTERIOR ELEVATION - CARDIO
1/4" = 1'-0"

NOTE: THE CONTRACT DRAWINGS ARE NOT ORGANIZED SPECIFICALLY FOR ANY CRAFT, TRADE, DISCIPLINE, OR SUBCONTRACT. THEREFORE, ADDITIONAL RELATED INFORMATION MAY BE INCLUDED IN OTHER CONTRACT DRAWINGS AND SPECIFICATIONS EVEN IF NOT SPECIFICALLY NOTED ON THIS DOCUMENT. IT IS THE RESPONSIBILITY OF EACH PARTY TO REFER TO THE COMPLETE SET OF CONTRACT DRAWINGS AND SPECIFICATIONS, AND NOT TO A PARTIAL OR INCOMPLETE SET OF DOCUMENTS.



Brent Barron Architect

P 6 0 1 . 7 5 0 . 1 7 7 8
114 WOODY HILLS DR. JACKSON, MS 39210

INTERIOR ELEVATION
CLUB 4 FITNESS - EL PASO MONTWOOD
11705 MONTWOOD DR. EL PASO, TX 79936

20250321

FOR CONSTRUCTION
JUNE 05, 2025

A4.5



Brent Barron Architect

P 6 0 1 - 7 5 0 - 1 7 8

114 WOODY HILLS DR. JACKSON, MS 39210


11705 MONTWOOD DR. EL PASO, TX 79936

INTERIOR ELEVATION
CLUB 4 FITNESS - EL PASO MONTWOOD


20250321

FOR CONSTRUCTION
JUNE 05, 2025


A4.6

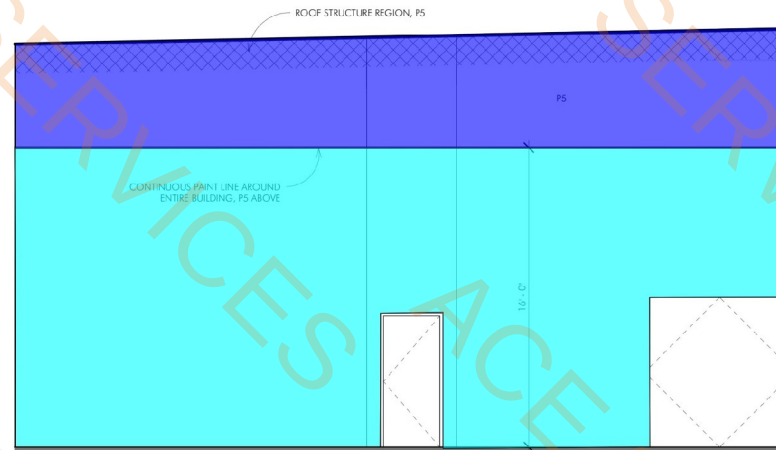


1 INTERIOR ELEVATION - STRETCH AND RECOVERY...
1/4" = 1'-0"

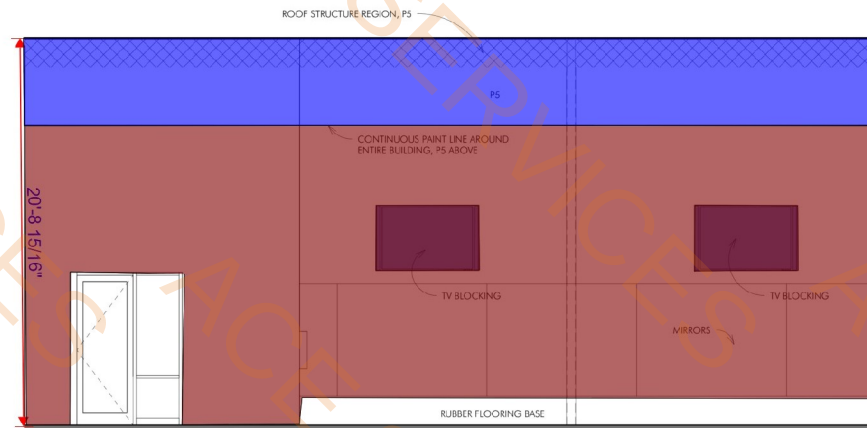


2 INTERIOR ELEVATION - BOXING...
1/4" = 1'-0"

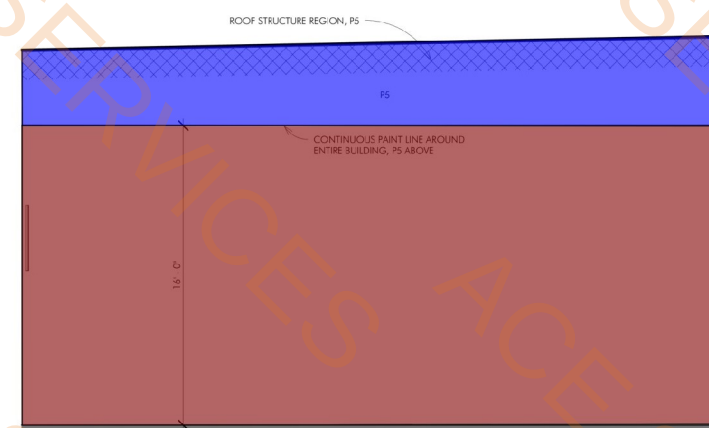


3 INTERIOR ELEVATION - BOXING...
1/4" = 1'-0"

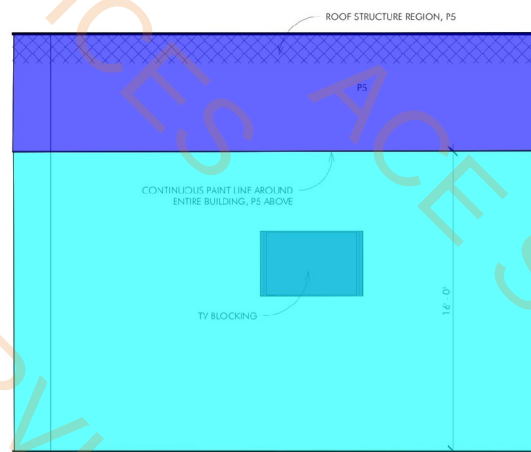

4 INTERIOR ELEVATION - STRETCH AND RECOVERY...
1/4" = 1'-0"

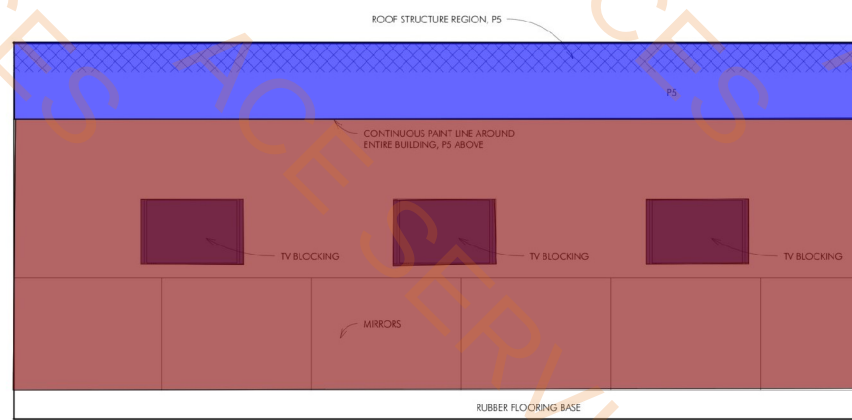


5 INTERIOR ELEVATION - BOXING...
1/4" = 1'-0"

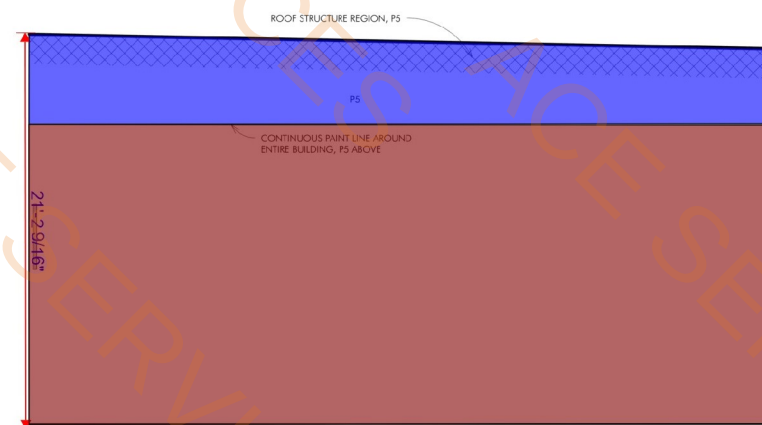


6 INTERIOR ELEVATION - BOXING...
1/4" = 1'-0"

- P9 (Paint)
- P5 (PAINT
- PG (Paint)
- 3/4" Plywood Blocking

2534.8 SQ FT
1546.4 SQ FT
2046.3 SQ FT
132.6 SQ FT

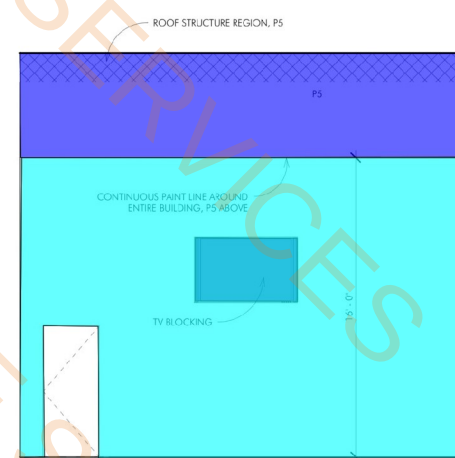


7 INTERIOR ELEVATION - STRETCH AND RECOVERY...
1/4" = 1'-0"

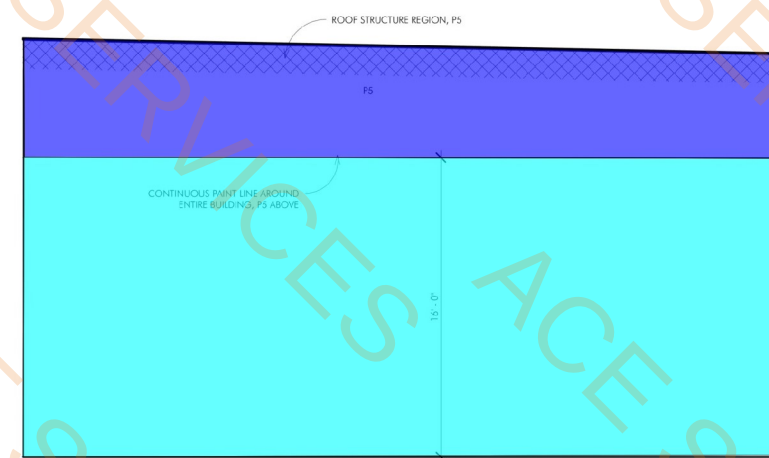


8 INTERIOR ELEVATION - STRETCH AND RECOVERY...
1/4" = 1'-0"

NOTE: THE CONTRACT DRAWINGS ARE NOT ORGANIZED SPECIFICALLY FOR ANY CRAFT, TRADE, DISCIPLINE, OR SUBCONTRACT. THEREFORE, ADDITIONAL RELATED INFORMATION MAY BE INCLUDED IN OTHER CONTRACT DRAWINGS AND SPECIFICATIONS EVEN THOUGH NOT SPECIFICALLY NOTED ON THIS DOCUMENT. IT IS THE RESPONSIBILITY OF EACH PARTY TO REFER TO THE COMPLETE SET OF CONTRACT DRAWINGS AND SPECIFICATIONS, AND NOT TO A PARTIAL OR INCOMPLETE SET OF DOCUMENTS.

- P5 (PAINT) 819.7 SQ FT
- P9 (Paint) 2821.9 SQ FT
- PS (Paint) 1641.4 SQ FT
- 3/4" Plywood Blocking 37.9 SQ FT
- PB (Painting) 959.4 SQ FT

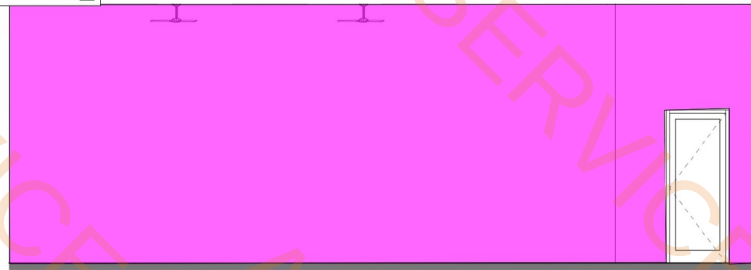


INTERIOR ELEVATION - WOMAN'S EXERCISE...
1/4" = 1'-0"

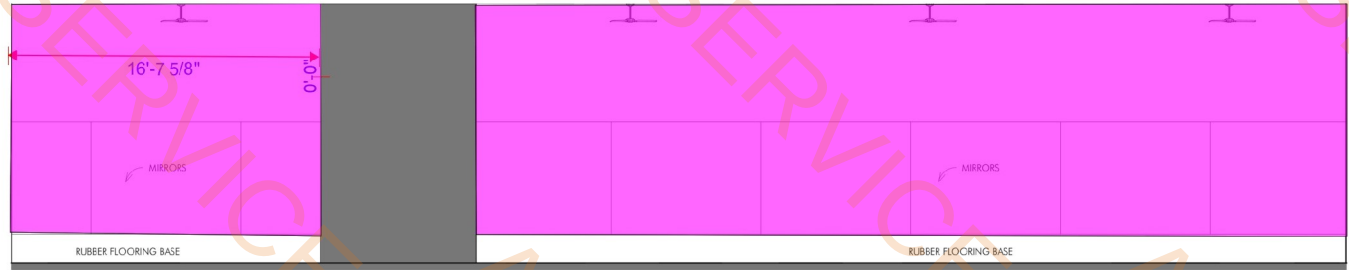


INTERIOR ELEVATION - WOMAN'S EXERCISE...
1/4" = 1'-0"




INTERIOR ELEVATION - WOMAN'S EXERCISE...
1/4" = 1'-0"

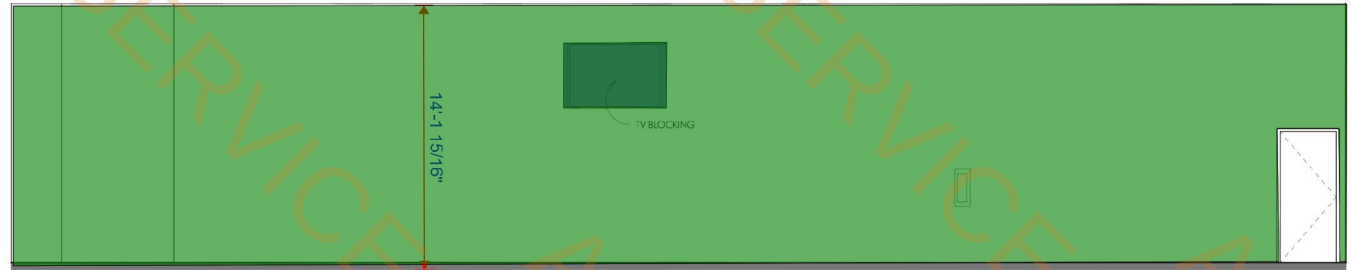


INTERIOR ELEVATION - WOMAN'S EXERCISE...
1/4" = 1'-0"

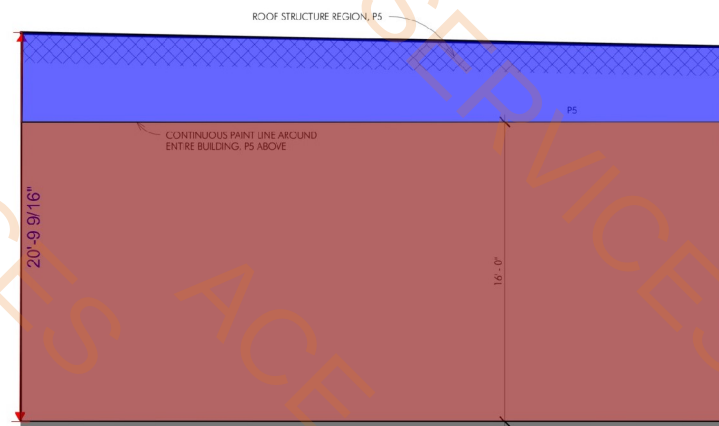


INTERIOR ELEVATION - CEREMONY...
1/4" = 1'-0"

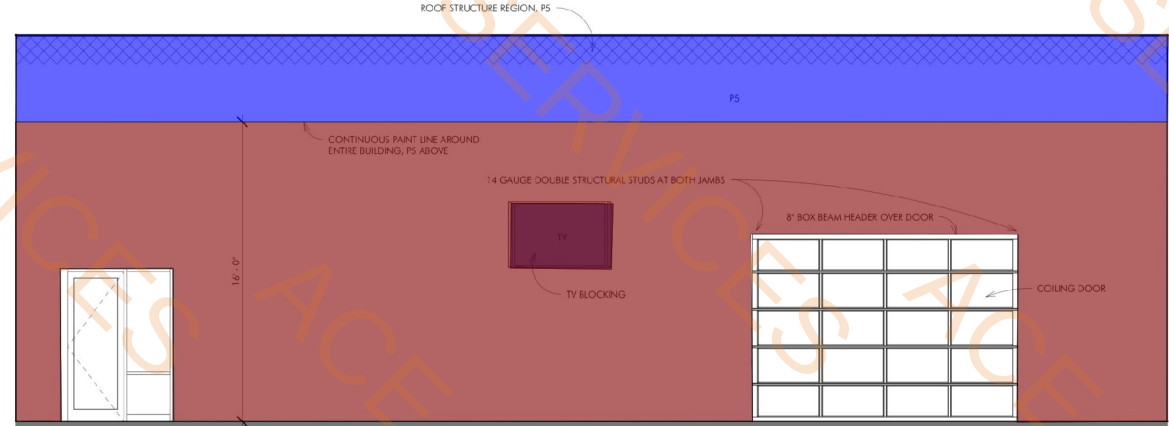

INTERIOR ELEVATION - CEREMONY...
1/4" = 1'-0"

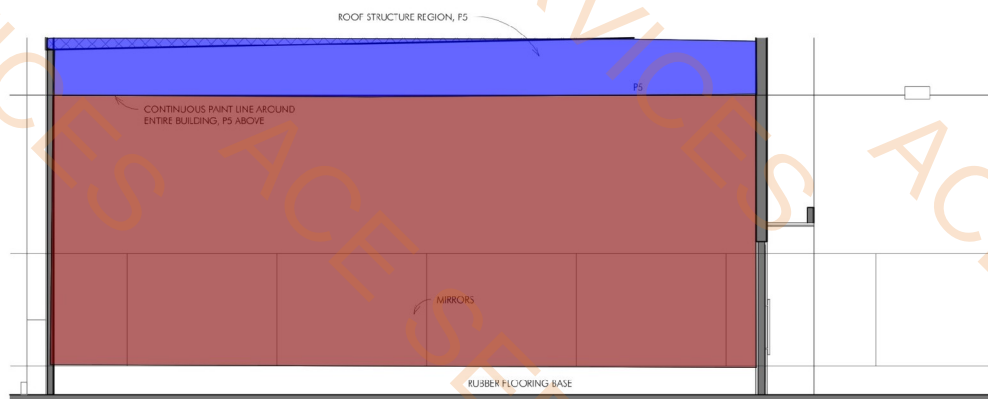


INTERIOR ELEVATION - CEREMONY...
1/4" = 1'-0"

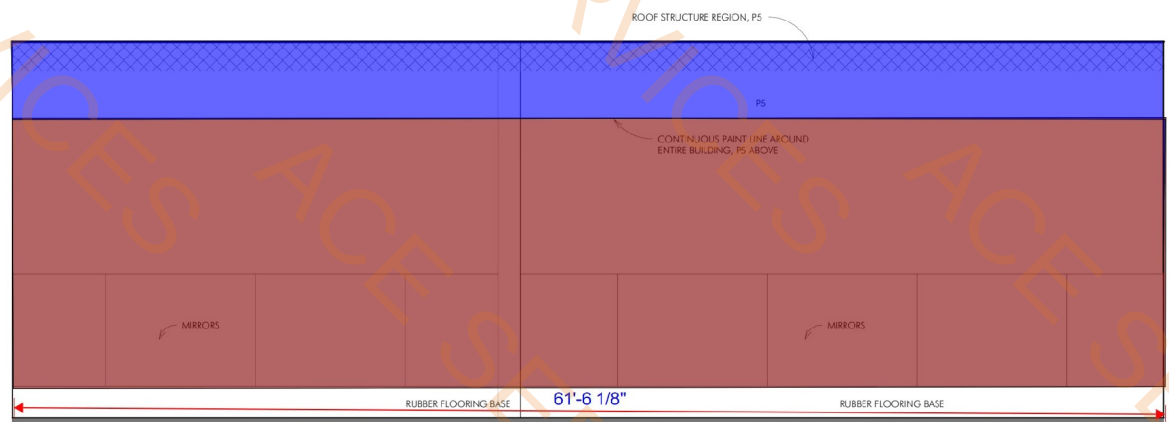

INTERIOR ELEVATION - CEREMONY...
1/4" = 1'-0"

NOTE: THE CONTRACT DRAWINGS ARE NOT ORGANIZED SPECIFICALLY FOR ANY CRAFT, TRADE, DISCIPLINE, OR SUBCONTRACT. THEREFORE, ADDITIONAL RELATED INFORMATION MAY BE INCLUDED IN OTHER CONTRACT DRAWINGS AND SPECIFICATIONS EVEN THOUGH NOT SPECIFICALLY NOTED ON THIS DOCUMENT. IT IS THE RESPONSIBILITY OF EACH PARTY TO REFER TO THE COMPLETE SET OF CONTRACT DRAWINGS AND SPECIFICATIONS, AND NOT TO A PARTIAL OR INCOMPLETE SET OF DOCUMENTS.

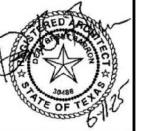

Brent Barron Architect

P 6 0 1 . 7 5 0 . 1 7 7 8
114 WOODY HILLS DR, JACKSON, MS 39210

11705 MONTWOOD DR, EL PASO, TX 79936

INTERIOR ELEVATION
CLUB 4 FITNESS - EL PASO MONTWOOD

20250321

FOR CONSTRUCTION
JUNE 05, 2025

A4.7



Brent Barron Architect

P 6 0 1 - 7 5 0 - 1 7 7 8



11705 MONTWOOD DR. EL PASO, TX 79936

EXTERIOR ELEVATIONS
CLUB 4 FITNESS - EL PASO MONTWOOD

20250321

FOR CONSTRUCTION
JUNE 05, 2025

A4.8

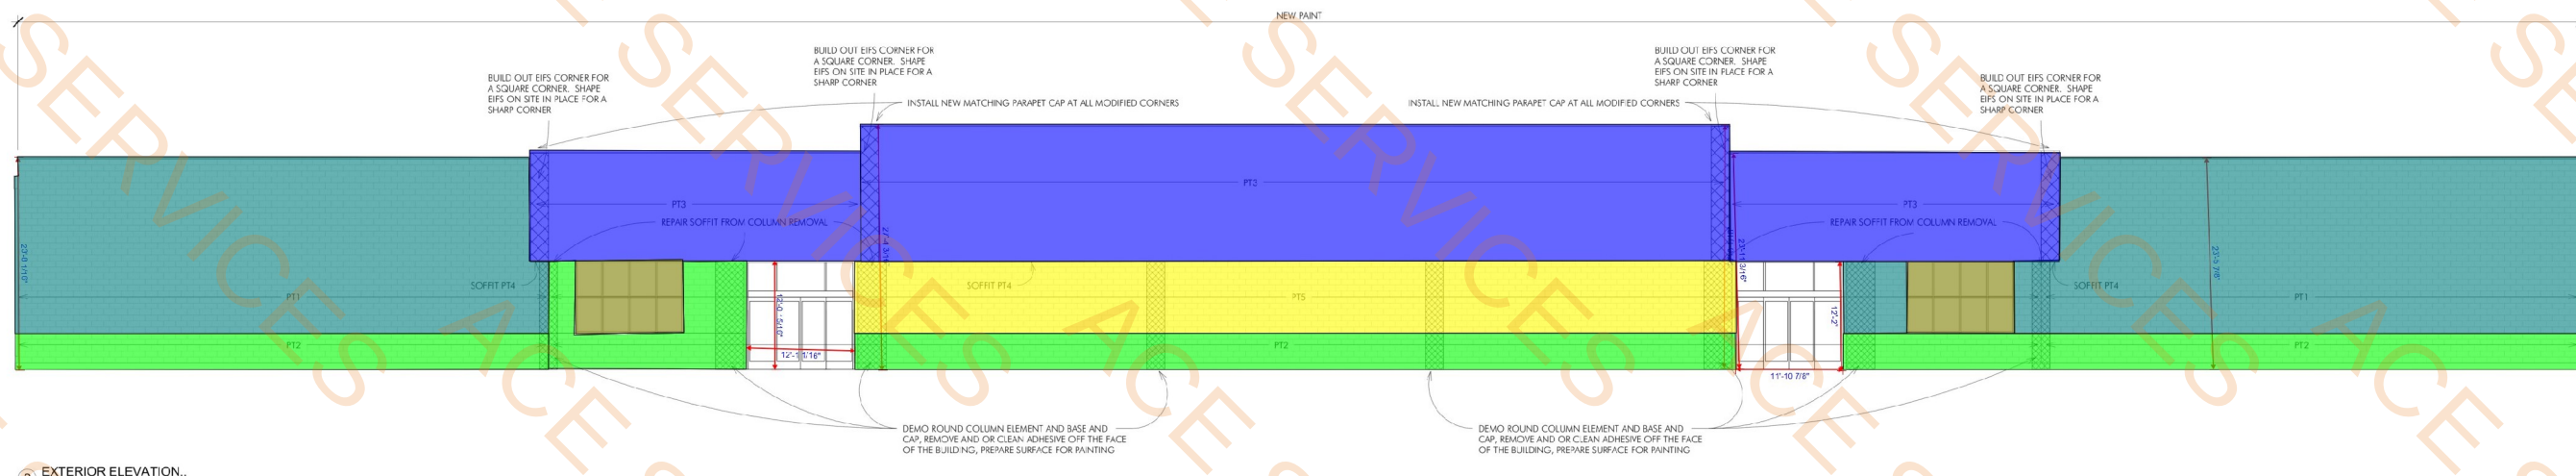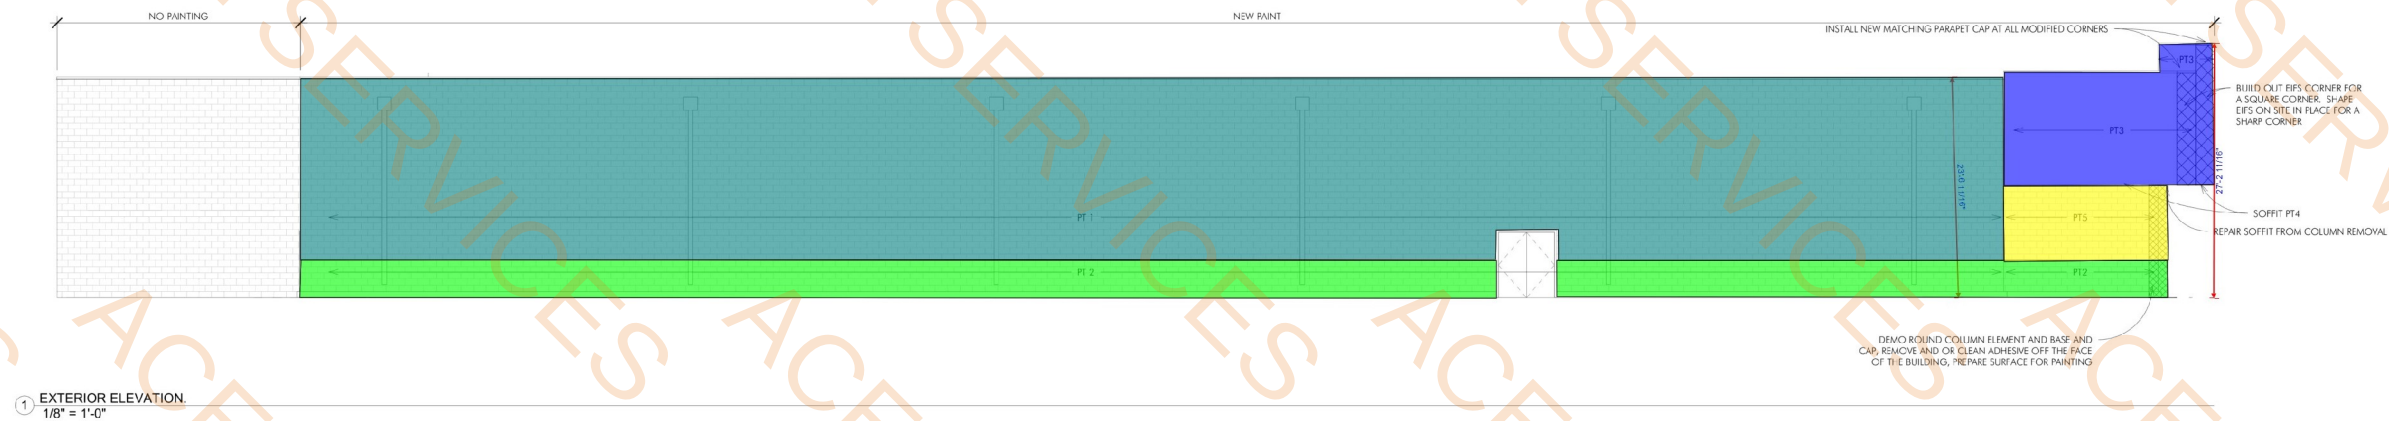

PAINT, STAINS, AND COATINGS:

PT1 - PAINT
MANUFACTURER: SHERWIN WILLIAMS
COLOR: SW 7653 SILVERPONT, LOW LUSTER
TYPE: FORMULATED FOR MASONRY
COATINGS: PRIME AND TWO COATS

PT2 - PAINT
MANUFACTURER: SHERWIN WILLIAMS
COLOR: SW 7065 GREZZLE GRAY, SEMI GLOSS
TYPE: FORMULATED FOR MASONRY
COATINGS: PRIME AND TWO COATS

PT3 - PAINT
MANUFACTURER: SHERWIN WILLIAMS
COLOR: SW 7653 SILVERPONT, LOW LUSTER
TYPE: FORMULATED FOR MASONRY
COATINGS: PRIME AND TWO COATS

PT4 - PAINT
MANUFACTURER: SHERWIN WILLIAMS
COLOR: SW 7008 EXTRA WHITE, LOW LUSTER
TYPE: FORMULATED FOR MASONRY
COATINGS: PRIME AND TWO COATS

PT5 - PAINT
MANUFACTURER: SHERWIN WILLIAMS
COLOR: CUSTOM COLOR / CLUB 4 BLUE
FORMULA: SEE CUSTOM COLORANT LEGEND
TYPE: FORMULATED FOR MASONRY
COATINGS: PRIME AND TWO COATS

Exterior PT1 (Paint)	6824.4 SQ FT
Exterior PT2(Paint)	2112.2 SQ FT
Exterior PT5(Paint)	1063.1 SQ FT
Exterior PT3(Paint)	2944.4 SQ FT
Decorative film	190.9 SQ FT

NOTE: THE CONTRACT DRAWINGS ARE NOT ORGANIZED SPECIFICALLY FOR ANY CRAFT, TRADE, DISCIPLINE, OR SUBCONTRACT. THEREFORE, ADDITIONAL RELATED INFORMATION MAY BE INCLUDED IN OTHER CONTRACT DRAWINGS AND SPECIFICATIONS EVEN THOUGH NOT SPECIFICALLY NOTED ON THIS DOCUMENT. IT IS THE RESPONSIBILITY OF EACH PARTY TO REFER TO THE COMPLETE SET OF CONTRACT DRAWINGS AND SPECIFICATIONS, AND NOT TO A PARTIAL OR INCOMPLETE SET OF DOCUMENTS.

■ Demo Hvac Unit 8.0 EA

ENGINEERING ANALYSIS REQUIREMENT: REFERENCE NOTES ON SHEET A0.1
DEMO ALL EXISTING HVAC UNITS, REFERENCE M SHEETS FOR NEW UNIT LOCATIONS
NOTE: OBTAIN A PRICE FOR THE ROOFING WORK FROM THE LANDLORD'S ROOFING CONTRACTOR. OBTAIN ADDITIONAL ROOFING WORK PRICES FROM OTHER ROOFING CONTRACTORS. SUBMIT PRICES FOR TENANT TO REVIEW.



Brent Barron Architect
P 601.750.1778
114 WOODY HILLS DR. JACKSON, MS 39210



1 ROOF PLAN
3/32" = 1'-0"

NOTE: THE CONTRACT DRAWINGS ARE NOT ORIGINATED SPECIFICALLY FOR ANY CRAFT, TRADE, DISCIPLINE, OR SUBCONTRACT. THEREFORE, ADDITIONAL RELATED INFORMATION MAY BE INCLUDED IN OTHER CONTRACT DRAWINGS AND SPECIFICATIONS EVEN THOUGH NOT SPECIFICALLY NOTED ON THIS DOCUMENT. IT IS THE RESPONSIBILITY OF EACH PARTY TO REFER TO THE COMPLETE SET OF CONTRACT DRAWINGS AND SPECIFICATIONS, AND NOT TO A PARTIAL OR INCOMPLETE SET OF DOCUMENTS.

ROOF PLAN
CLUB 4 FITNESS - EL PASO MONTWOOD
11705 MONTWOOD DR. EL PASO, TX 79936
20250321

FOR CONSTRUCTION
JUNE 05, 2025



14 WOODY HILLS DR, MADISON, MS 39110

20250321

A1.2

- 1. REMOVE STUD WALL
- 2. REMOVE SINGLE LEAF DOORS WITH FRAMES
- 3. REMOVE ROLLING DOOR
- 4. REMOVE GENERATOR AND ENCLOSURE
- 5. REMOVE COLUMN, BASE AND CAP
- 6. REMOVE SLIDER DOORS ONLY
- 7. REMOVE METAL PACKAGE HANDLER
- 8. REMOVE FLOORING, CEILING, HVAC, ELEC, MECH
- 9. REMOVE MILLWORK
- 10. REMOVE 6"X6" COLUMN COVERING
- 11. REMOVE ALL CONSTRUCTIONS AND EQUIPMENTS
- 12. REMOVE RESTROOM FIXTURES
- 13. REMOVE DOUBLE LEAF DOORS WITH FRAME

1. DEMO ALL EXISTING ELECTRICAL WIRING, INCLUDING ALL ELECTRICAL BOXES, CONDUIT, AND ALL OTHER ELECTRICAL COMPONENTS, TO BE REINSTALLED BY CONTRACTOR	2540.7 FT
2. DEMO ALL EXISTING PARTITION WALLS, DO NOT DEMO EXTERIOR WALLS	34.0 EA
3. DEMO ALL EXISTING PARTITION WALLS, DO NOT DEMO EXTERIOR WALLS	7.0 EA
4. DEMO ALL EXISTING THERMOSTATS, DIMMER, AND LIGHT FIXTURES	1.0 EA
5. DEMO ALL EXISTING WALLS, WATER	1.0 EA
6. DEMO ALL EXISTING CEILING, INCLUDING ALL CEILING, ALUMINUM, AND ALL OTHER MATERIALS, TO BE REINSTALLED BY CONTRACTOR	13.0 EA
7. DEMO ALL EXISTING FLOOR, INCLUDING ALL FLOOR, AND ALL OTHER MATERIALS, TO BE REINSTALLED BY CONTRACTOR	2.0 EA
8. DEMO ALL EXISTING FLOOR, INCLUDING ALL FLOOR, AND ALL OTHER MATERIALS, TO BE REINSTALLED BY CONTRACTOR	1.0 EA
9. DEMO ALL EXISTING FLOOR, INCLUDING ALL FLOOR, AND ALL OTHER MATERIALS, TO BE REINSTALLED BY CONTRACTOR	
10. DEMO ALL EXISTING FLOOR, INCLUDING ALL FLOOR, AND ALL OTHER MATERIALS, TO BE REINSTALLED BY CONTRACTOR	
11. DEMO ALL EXISTING FLOOR, INCLUDING ALL FLOOR, AND ALL OTHER MATERIALS, TO BE REINSTALLED BY CONTRACTOR	
12. DEMO ALL EXISTING FLOOR, INCLUDING ALL FLOOR, AND ALL OTHER MATERIALS, TO BE REINSTALLED BY CONTRACTOR	

2540.7 FT	
34.0 EA	
7.0 EA	
1.0 EA	
13.0 EA	
2.0 EA	
1.0 EA	
15460.2 SQ FT	
137.6 SQ FT	
21.0 EA	
37731.5 SQ FT	
8.0 EA	
4.0 EA	

EMERGENCY LIGHTING, ETC. 2. DEMO ALL HVAC
EXISTING HVAC SYSTEMS EXCLUDING CURBS AND DUCT
WORK.

5. BOXES, AND ACCESSORIES. DO NOT LEAVE ANY
PLUMBING BELOW GRADE, COVER CAP WITH MIN.
1" DTH SLAB TRANSITION.

SECTION:

[illegible]

NOTE: THE CONTRACT DRAWINGS ARE NOT ORGANIZED SPECIFICALLY FOR ANY CRAFT, TRADE, DISCIPLINE, OR SUBCONTRACT. THEREFORE, ADDITIONAL RELATED INFORMATION MAY BE INCLUDED IN OTHER CONTRACT DRAWINGS AND SPECIFICATIONS EVEN THOUGH NOT SPECIFICALLY NOTED ON THIS DOCUMENT. IT IS THE RESPONSIBILITY OF EACH PARTY TO REFER TO THE COMPLETE SET OF CONTRACT DRAWINGS AND SPECIFICATIONS, AND NOT TO A PARTIAL, OR INCOMPLETE SET OF DOCUMENTS.



GENERAL NOTES:

1. IF A PIECE OF STRUCTURE PROTRUDES FROM A WALL AND INTERRUPTS THE PLANE OF THE GYPSUM OR OTHER FINISH INSTALL THE SMALLEST STUDS POSSIBLE TIGHTLY TO THE STRUCTURE AND FURROUND IT. THIS HOLDS TRUE WHETHER IT IS GRAPHICALLY INDICATED THIS WAY OR NOT.
2. WHEN SHAFT WALLS AND OTHER FIRE RATED PARTITIONS ARE INTERRUPTED BY STRUCTURE RUNNING PARALLEL TO THE PARTITION THE STRUCTURE SHALL BE PROTECTED BY AN ENCLOSURE OF THE SAME RATING AS THE PARTITION.
3. PENETRATIONS IN FIRE RATED PARTITIONS AND FLOORS/HORIZONTAL ASSEMBLIES SHOULD BE CONSTRUCTED WITH A RATED FLAME COLLAR OR EQUIVALENT RATED DEVICE OR ASSEMBLY.
4. TO THE MAXIMUM EXTENT POSSIBLE, FLOOR CLEAN-OUTS ARE TO BE LOCATED IN INCONSPICUOUS LOCATIONS. ALL FLOOR CLEAN-OUTS LOCATED IN CARPETED AREAS ARE TO BE FITTED WITH CARPET INSERTS. ALL CLEAN-OUTS ARE TO BE FLUSH TO FLOORS/WALLS.
5. IF THERE IS A CONFLICT BETWEEN THE INFORMATION ON THIS PAGE AND INFORMATION CONTAINED ON OTHER PAGES CONSULT THE ARCHITECT FOR CLARIFICATION. IN THE EVENT OF A CONFLICT THE MORE RESTRICTIVE OR EXTENSIVE OPTION SHOULD BE AVAILABLE FOR USE WITH NO INCREASE IN THE CONTRACT AMOUNT OR CONTRACT TIME.
6. REFERENCE PARTITION SCHEDULE FOR PARTITION ASSEMBLIES AND DIVISIONS.
7. ALL FIRE RATED WALLS EXTEND AT A MINIMUM FROM THE FLOOR STRUCTURE TO THE CEILING STRUCTURE THROUGHOUT THE ENTIRE WALL ASSEMBLY REGARDLESS OF INDICATIONS IN THE SCHEDULE OR THROUGH STRUCTURAL MEMBERS THE WALL SHALL BE THOROUGHLY SEALED WITH SEALING MATERIALS.
8. ALL EXTERIOR WALLS INCLUDING BEAMS AND STRUCTURE ANYWHERE WITHIN THE PLANE OF THE WALL SHALL BE FULLY INSULATED AND FULLY SHEATHED TO THE STRUCTURAL DECK REGARDLESS OF INDICATIONS IN THE SCHEDULE OR THROUGH STRUCTURAL MEMBERS THE WALL SHALL BE THOROUGHLY SEALED WITH SEALING MATERIALS.
9. INSTALL MISCELLANEOUS INSULATION IN EXTERIOR WALL CAVITIES IN OR OUT OF THE PLANE OF THE WALL AS SHOWN OR AS NOTED.
10. ALL BEAMS AND OTHER STRUCTURE INTERRUPTING WALLS SHALL BE CO-LOCATED TO THE AREA OBSTRUCTED.
11. THE TYPE OF ALL UNFACED WALLS SHALL BE VERIFIED BY THE ARCHITECT.
12. ALL RATED WALLS SHALL BE FIRE CAULKED AT THE DECK AND FLOOR JUNCTIONS.
13. PENETRATIONS IN FIRE RATED PARTITIONS AND FLOORS/HORIZONTAL ASSEMBLIES SHOULD BE CONSTRUCTED WITH A RATED FLAME COLLAR, DEVICE, OR ASSEMBLY.
14. THE TERM GYPSUM WALL BOARD IS USED AS A GENERIC TERM. SPECIFICATIONS FOR THE SPECIFIC MATERIAL REQUIRED FOR THE SPECIFIC APPLICATION SHALL BE PROVIDED BY THE ARCHITECT.

15. WHERE TILE OR OTHER HARD SURFACE IS SCHEDULED/INDICATED IN THE PARTITION SCHEDULE, PARTITION DETAILS, ETC., THE OUTER LAYER OF GYPSUM OF THE ASSEMBLY SHOULD BE REPLACED WITH APPROPRIATE BACKER MATERIAL AS INDICATED IN THE SPECIFICATIONS. FIRE RATING OF THE ASSEMBLY AND ITS INDIVIDUAL COMPONENTS SHOULD BE MAINTAINED.
16. PROVIDE BLOCKING IN WALLS FOR ALL CASEWORK, FIXTURES, GRAB BARS, TVS, AND ACCESSORIES. COORDINATE LOCATION WITH MANUFACTURER'S INSTALLATION REQUIREMENTS.
17. REFERENCE SHEET A6.1 FOR TYPICAL TOILET ELEVATIONS AND ACCESSORY MOUNTING HEIGHTS.
18. PROVIDE AIR GYPSUM WINDOW SILL RETURNS AT ALL SIDES OF ALL WINDOWS AND ON WET WALLS DESCRIBED UNDER OTHER WALL NOTES SHEET A6.1.
19. WHEN DOOR PLACEMENTS ARE NOT DIMENSIONED POSITION DOOR SO THAT THE OUTSIDE FACE OF THE HINGE JAMB IS 4" FROM THE FINISHED FACE OF THE NEAREST WALL.
20. CORRECT FLOOR BEAMS FOR GRADE BEAMS AS NECESSARY.
21. ***AT ALL WET AREAS SET STUDS IN 2" CONTINUOUS BEADS OF SEALANT. HOLD MOISTURE RESISTANT GYPSUM 3/8" FROM THE EXTERIOR FACE OF THE HINGE.

22. DIMENSIONS MARKED "CLEAR" OR "CLR" ARE MEASURED FROM FINISHED SURFACE TO FINISHED SURFACE. ACCURATELY MAINTAIN CLEAR DIMENSIONS AT ALL TIMES. CLEAR DIMENSIONS SHALL NOT VARY MORE THAN +/- 1/8" WITHOUT WRITTEN INSTRUCTION FROM ARCHITECT. CLEAR DIMENSIONS OVERRIDE ALL OTHER DIMENSIONS. IF A CONFLICT OCCURS, CONSULT THE ARCHITECT.
23. DIMENSIONS MARKED "T" MEAN A TOLERANCE NOT GREATER NOR SMALLER THAN 2" INCHES FROM INDICATED DIMENSIONS, U.N.O. VERIFY FIELD DIMENSIONS EXCEEDING TOLERANCE WITH THE ARCHITECT. SECURE ARCHITECT'S APPROVAL.
24. NOTIFY ARCHITECT IN WRITING OF ANY DISCREPANCIES OR CONFLICTS IN THE LOCATION OF NEW CONSTRUCTION.
25. REFER TO REFLECTED CEILING PLANS FOR SOFFIT, CEILING HEIGHTS AND PLUMBING BARRIER LOCATIONS.
26. DIMENSIONS LOCATING DOORS ARE TO THE INSIDE EDGE OF JAMB, U.N.O.
27. "AUGH" MEANS TO ACCURATELY LOCATE FINISHED FACES IN THE SAME PLANE.
28. ALL DOORS SHALL HAVE 1-4" CLR ON STRIKE/SILL SIDE OF DOOR. VERIFY AND ADVISE ARCHITECT OF EXCEPTIONS PRIOR TO CLOSING OUT PARTITIONS.

TAGGED PLAN NOTES - DESIGNATED BY "W":

1. ELECTRICAL RACEWAYS, CONTRACTOR SUPPLIED, ORG. CABLELINE RACEWAY SYSTEM.
 2. PROVIDE FLOORING AS NECESSARY FOR ELECTRICAL AND DATA CONDUITS.
 3. PERMANENTLY LOCK DOOR.
 4. PROVIDE KNOX BOX SURFACE MOUNTED ON EXTERIOR WALL.
 5. ASK CONTRACTOR STAFF AND STAFF: REFERENCE STAIR, STAIR, GUARD, AND HANDRAIL NOTES ON A7.1 FOR DETAILS.
 6. EXISTING FIRE SPRINKLER TEST VALVE BOX, DO NOT DISTURB.
 7. REPAIR EXISTING ROOF LADDER AND ACCESS HATCH.
 8. WHERE DIVIDED DOOR OPENING INSTALL 3-5/8" 18 GAUGE METAL STUDS, 1/2" GYP SHEATHING ON EXTERIOR, FLOOR APPLIED AIR BARRIER COMPATIBLE WITH MASONRY SYSTEM. CONCRETE MASONRY TO MATCH EXISTING. PAINT MASONRY TO MATCH. THE INTERIOR SHOULD BE FINISHED EVEN WITH ADJACENT FINISHES.
 9. PROVIDE WHITE PRESSED FLOOR ON INSIDE FACE OF GAZING. INSTALL 5/8" GYP ON BACKSIDE OF STUDS, WHITE FACE OF GYP FACING OUT, PRIME WHITE FACE. THIS TAKES PLANNING BUT DOABLE.
 10. INSTALL BACKOUT FILM ON INSIDE FACE OF DRIVE THROUGH WINDOW.
 11. INSTALL NEW CONCRETE FLOOR IN LEBER HOUSE. THE EXISTING SLAB WITH #4 @ 24" O.C.
- NOTE: THE EXISTING EXTERIOR WALLS HAVE GYPSUM ALREADY APPLIED TO THE INTERIOR FACE. IT IS THE INTENTION TO REUSE THE EXISTING EXTERIOR WALL GYPSUM FOR THE NEW BUILD OUT. PER THE PARTITION SCHEDULE NOTES THE EXISTING GYPSUM SHALL BE REPAIRED AND BROUGHT BACK TO A LEVEL 4 FINISH. NEW GYPSUM SHOULD BE INSTALLED IN AREAS THAT CAN NOT BE REUSED AND OR ARE DAMAGED DURING OR AS A RESULT OF DEMOLITION. CONTRACTOR SHALL OBSERVE THE CONDITION OF THE EXISTING WALL GYPSUM AND INCLUDE MATERIAL AND LABOR NECESSARY FOR THE DESCRIBED WORK. THIS APPLIES TO ANY EXISTING INTERIOR WALLS THAT ARE TO REMAIN AS PART OF THE CONSTRUCTION.

SLAM WALL @12'H

DEMOLED DOOR Wall @8'H

61.9 FT
15.6 FT

WALL AS BASE. PROVIDE 3/4" PLASTER

ALL EXTERIOR
IN VIEW FROM

NOTE: G.C. IS TO PROVIDE A LIFT FOR THE HVAC TEST AND BALANCE SERVICE PROVIDERS USE DURING ANY AND ALL TEST AND BALANCE INSPECTIONS. LIFT SHOULD BE CAPABLE OF PROVIDING ACCESS TO HIGHEST SUPPLY AND RETURN REGISTERS.



Brent Barron Architect

P 6 0 1 - 7 5 0 - 1 7 7 8
114 WOODY HILLS DR. WASSON, MO 63110

ENLARGED FLOOR PLANS
CLUB 4 FITNESS - EL PASO MONTWOOD
11705 MONTWOOD DR. EL PASO, TX 79936

20250321


FOR CONSTRUCTION
JUNE 05, 2025

A1.5

SS-2 COUNTERTOP 2'-9"DX2'-10'H BASE CABINETS

- 5. 3 POSITION PORTFOLIO HOLDER, MOUNT AT 6'-0"
- 6. ROUTE DRYER VENT UP THROUGH WALL, REF. MECHANICAL SHEETS FOR CONTINUATION.
- 7. NOT USED
- 8. NOT USED
- 9. NOT USED
- 10. NOT USED
- 11. NOT USED
- 12. NOT USED
- 13. 4-1/2" BRK METAL CORNER COLUMN COVER, 125" ALUMINUM, FINISH TO MATCH STOREFRONT, SINGLE PIECE FULL HEIGHT
- 14. JETAL STUD BOX COLUMN, 14 GAUGE, TWO STUDS AND TWO TRACKS, FASTEN AT 12" O.C.
- 15. NOT USED

24.6 SQ FT
22.6 FT

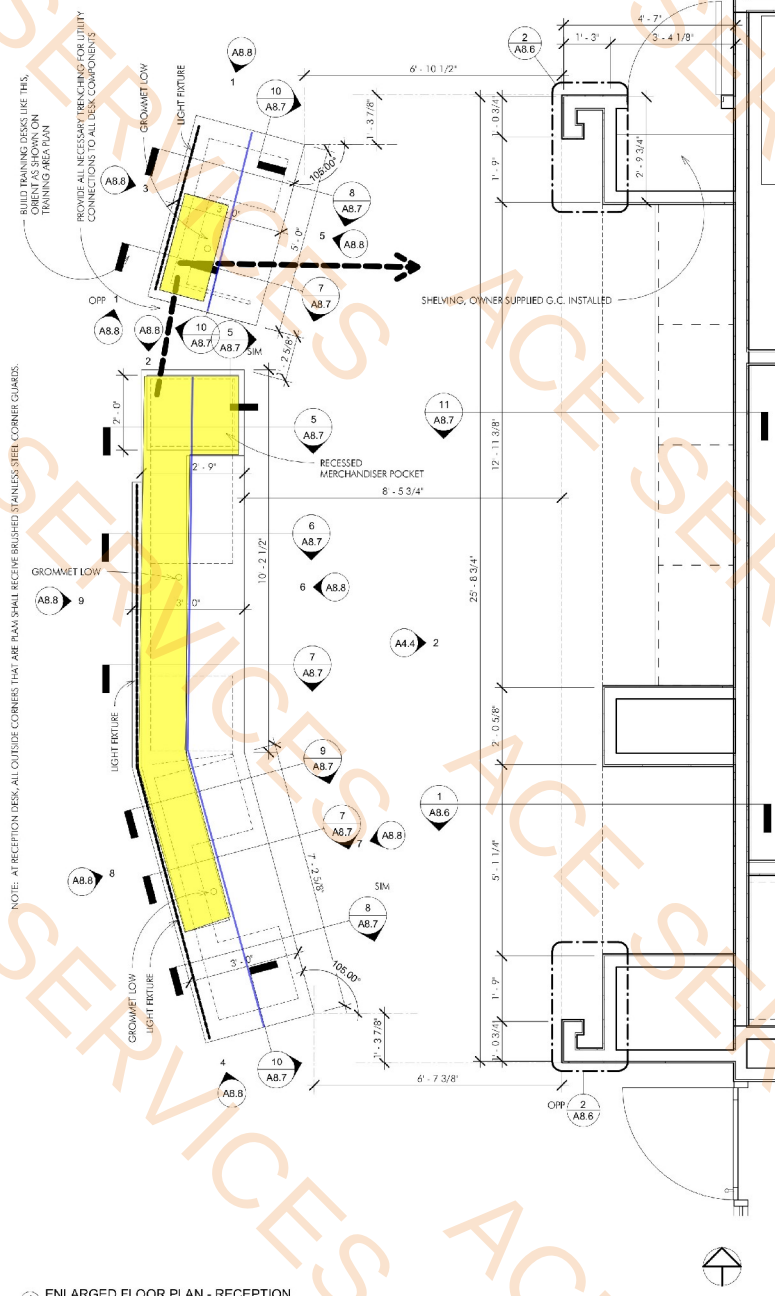

1 ENLARGED FLOOR PLAN - RECEPTION
1/2" = 1'-0"

2 ENLARGED FLOOR PLAN - FRONT OF
HOUSE
1/4" = 1'-0"

NOTE: THE CONTRACT DRAWINGS ARE NOT ORIGINATED SPECIFICALLY FOR ANY GRANT, TRACT, DISCIPLINE, OR SUBCONTRACT. THEREFORE, ADDITIONAL RELATED INFORMATION MAY BE INCLUDED IN OTHER CONTRACT DRAWINGS AND SPECIFICATIONS EVEN THOUGH NOT SPECIFICALLY NOTED ON THE DOCUMENT. IT IS THE RESPONSIBILITY OF EACH PARTY TO REFER TO THE COMPLETE SET OF CONTRACT DRAWINGS AND SPECIFICATIONS AND NOT TO A PARTIAL OR INCOMPLETE SET OF DOCUMENTS.



Brent Barron Architect

P 6 0 1 - 7 5 0 - 1 7 7 8
114 WOODY HILLS DR. WASSON, MO 63010

ENLARGED FLOOR PLANS
CLUB 4 FITNESS - EL PASO MONTWOOD
11705 MONTWOOD DR. EL PASO, TX 79936

20250321

FOR CONSTRUCTION
JUNE 05, 2025

A1.5

- WALL TAG 39@UPTO DECK H
WALL TAG 46@UPTO DECK H
WALL TAG 41@UPTO DECK H
WALL TAG 58@UPTO DECK H
WALL TAG 54@UPTO DECK H
WALL TAG 46@11'-10"C.H
WALL TAG 41@9'-10"C.H ONE SIDE WATER RESISTANT
WALL TAG 41@8'-10"C.H
WALL TAG 67@9'-10"C.H ONE SIDE MOISTURE RESISTANT
WALL TAG 41@9'-10"C.H
WALL TAG50@9'-10"C.H
WALL TAG 46@8'-10"C.H
WALL TAG51@9'-10"C.H
WALL TAG 58@9'-10" C.H
WALL TAG 46@10'-00"C.H
WALL TAG 45@12'-6"C.H
WALL TAG 48@12'-6"C.H
WALL TAG 43@12'-6"C.H
SS1 COUNTERTOP
2'-1DX2'-10H BOTTOM CABINETS PL-1 FINISH
1'-2 3/4"DX3'H BASE CABINETS
1'-2"DX2'-4"H UPPER CABINETS PL-1 FINISH
1'-8"HX1'-2"D CABINETS
3'-6"HX1'-2"D CABINETS
WALL TAG 45@10'-0"C.H
WALL TAG40@9'-10"C.H
METAL STUD BOX COLUMN
4-1/2 BREAK METAL COLUMN

- 37.5 FT
9.3 FT
14.1 FT
51.8 FT
5.4 FT
48.5 FT
29.0 FT
96.0 FT
8.5 FT
332.2 FT
29.1 FT
70.2 FT
13.4 FT
15.0 FT
45.5 FT
22.2 FT
20.1 FT
5.1 FT
104.0 SQ FT
11.6 FT
10.1 FT
8.6 FT
17.0 FT
4.0 FT
6.8 FT
3.2 FT
3.0 EA
2.0 EA

- PLAN NOTES:
1. ALL GYPSUM IN LOCKER ROOMS, RESTROOMS, AND OTHER WET/MOIST AREAS SHALL BE MOISTURE RESISTANT TYPE.
TAGGED PLAN NOTES - DESIGNATED BY "X"
1. NOT USED
2. NOT USED
3. NOT USED
4. MOP SINK, PROVIDE 2 STAINLESS STEEL SPLASH GUARDS.
5. 3 POSITION MOP HOLDER, MOUNT AT 6'-0"
6. ROUTE DRYER WENT UP THROUGH WALL, REF. MECHANICAL SHEETS FOR CONTINUATION.
7. NOT USED
8. NOT USED
9. NOT USED
10. NOT USED
11. NOT USED
12. NOT USED
13. 4-1/2" BREAK METAL CORNER COLUMN COVER, 125' ALUMINUM, FINISH TO MATCH STOREFRONT, SINGLE PIECE FULL HEIGHT
14. METAL STUD BOX COLUMN, 14 GAUGE, TWO STUDS AND TWO TRACKS, FASTEN AT 12" O.C.
15. NOT USED

PROVIDE ALL NECESSARY TRENCHING FOR UTILITY CONNECTIONS TO ALL DESK COMPONENTS

ENLARGED FLOOR PLAN - FRONT OF
HOUSE
1/4" = 1'-0"

NOTE: THE CONTRACT DRAWINGS ARE NOT ORIGINATED SPECIFICALLY FOR ANY GRANT, TRACT, DISCIPLINE, OR SUBCONTRACT. THEREFORE, ADDITIONAL RELATED INFORMATION MAY BE INCLUDED IN OTHER CONTRACT DRAWINGS AND SPECIFICATIONS EVEN THOUGH NOT SPECIFICALLY NOTED ON THE DOCUMENT. IT IS THE RESPONSIBILITY OF EACH PARTY TO REFER TO THE COMPLETE SET OF CONTRACT DRAWINGS AND SPECIFICATIONS AND NOTED IN A PARTIAL OR INCOMPLETE SET OF DOCUMENTS.



20250321

ENLARGED FLOOR PLANS

A1.6



NOTE: THE CONTRACT DRAWINGS ARE NOT ORGANIZED SPECIFICALLY FOR ANY CRAFT, TRADE, DISCIPLINE, OR SUBCONTRACT. THEREFORE, ADDITIONAL RELATED INFORMATION MAY BE INCLUDED IN OTHER CONTRACT DRAWINGS AND SPECIFICATIONS EVEN THOUGH NOT SPECIFICALLY NOTED ON THIS DOCUMENT. IT IS THE RESPONSIBILITY OF EACH PARTY TO REFER TO THE COMPLETE SET OF CONTRACT DRAWINGS AND SPECIFICATIONS, AND NOT TO A PARTIAL OR INCOMPLETE SET OF DOCUMENTS.

A1.6



Brent Barron Architect

P 6 0 1 - 7 5 0 - 1 7 7 8

114 WOODY HILLS DR. WASSON, MO 63010


ENLARGED FLOOR PLANS
CLUB 4 FITNESS - EL PASO MONTWOOD

11705 MONTWOOD DR. EL PASO, TX 79936


20250321

FOR CONSTRUCTION
JUNE 05, 2025

A1.7

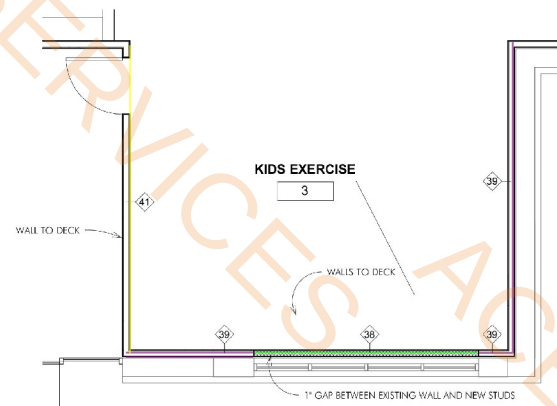


3 ENLARGED FLOOR PLANS
1/4" = 1'-0"

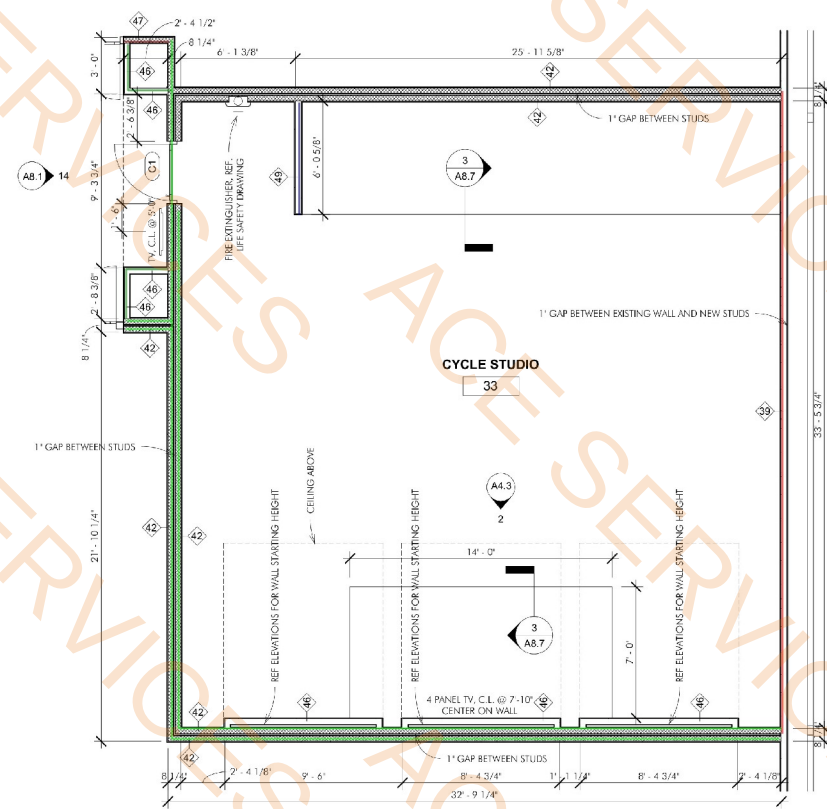


33 ENLARGED FLOOR PLANS - CYCLE
1/4" = 1'-0"

- WALL TAG 39@UPTO DECK H
- WALL TAG 42@UPTO DECK H
- WALL TAG 46@UPTO DECK H
- WALL TAG 49@11'-10"C.H
- WALL TAG 39@13'-6" C. H
- WALL TAG 47@UPTO DECK H
- WALL TAG 69 13'-6"C.H
- WALL TAG 41@UPTO DECK
- WALL TAG38@UPTO DECK

- 279.3 FT
- 316.4 FT
- 44.9 FT
- 6.0 FT
- 34.3 FT
- 2.5 FT
- 28.4 FT
- 16.4 FT
- 11.9 FT

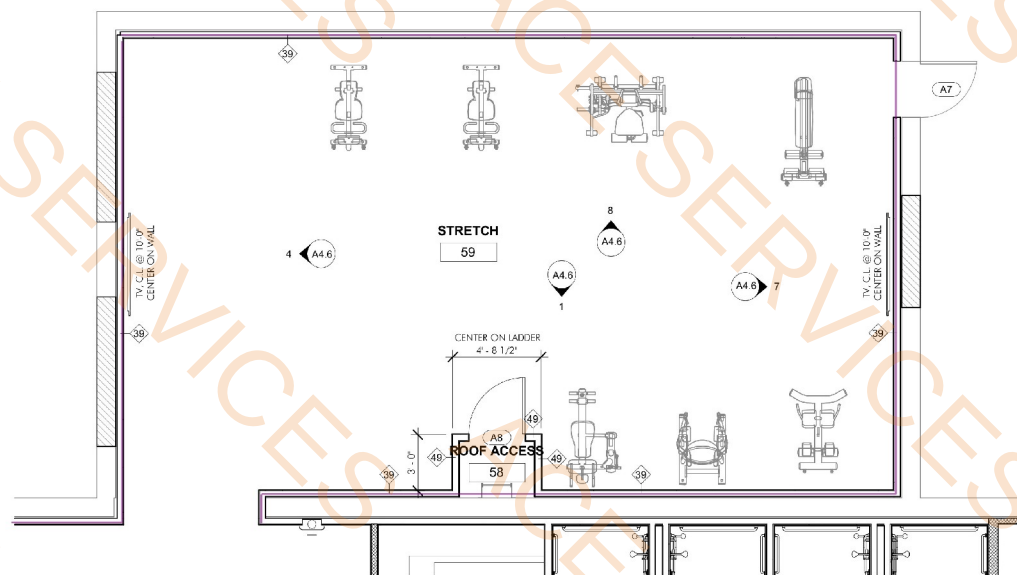

2 ENLARGED FLOOR PLANS - STRETCH
1/4" = 1'-0"

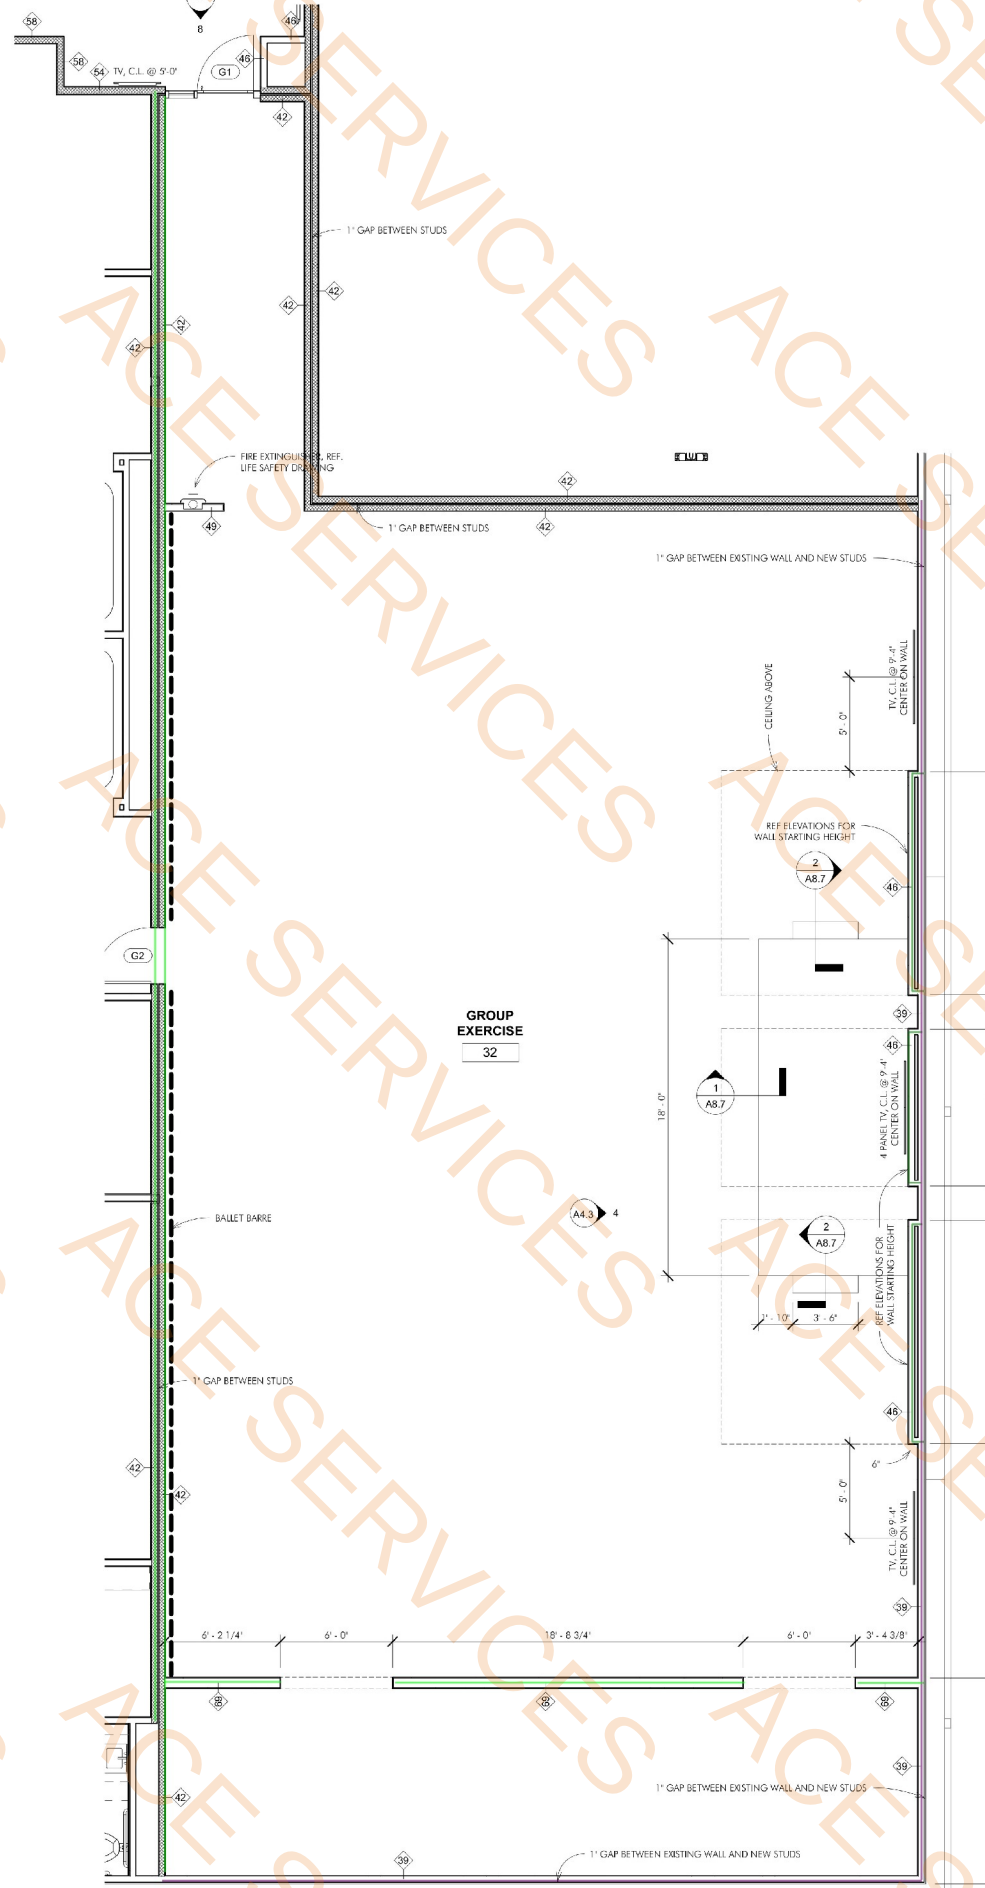

4 ENLARGED FLOOR PLAN - GROUP
EXERCISE
1/4" = 1'-0"

NOTE: THE CONTRACT DRAWINGS ARE NOT ORGANIZED SPECIFICALLY FOR ANY GRANT, TRACT, DISCIPLINE, OR SUBCONTRACT. THEREFORE, ADDITIONAL RELATED INFORMATION MAY BE INCLUDED IN OTHER CONTRACT DRAWINGS AND SPECIFICATIONS EVEN IF NOT SPECIFICALLY NOTED ON THIS DOCUMENT. IT IS THE RESPONSIBILITY OF EACH PARTY TO REFER TO THE COMPLETE SET OF CONTRACT DRAWINGS AND SPECIFICATIONS AND NOTED IN PARTIAL OR INCOMPLETE SET OF DOCUMENTS.



Brent Barron Architect

P 6 0 1 - 7 5 0 - 1 7 7 8
114 WOODY HILLS DR. WADSWORTH, TX 75090


ENLARGED FLOOR PLANS
CLUB 4 FITNESS - EL PASO MONTWOOD
11705 MONTWOOD DR. EL PASO, TX 79936
20250321

FOR CONSTRUCTION
JUNE 05, 2025


A1.8

- WALL TAG 60@UPTO DECK H
- WALL TAG 47@UPTO DECK H
- WALL TAG 46@UPTO DECK H
- WALL TAG 49@UPTO DECK H
- WALL TAG 54@UPTO DECK H
- WALL TAG 39@UPTO DECK H

- 99.0 FT
- 35.3 FT
- 66.6 FT
- 8.8 FT
- 113.5 FT
- 162.2 FT

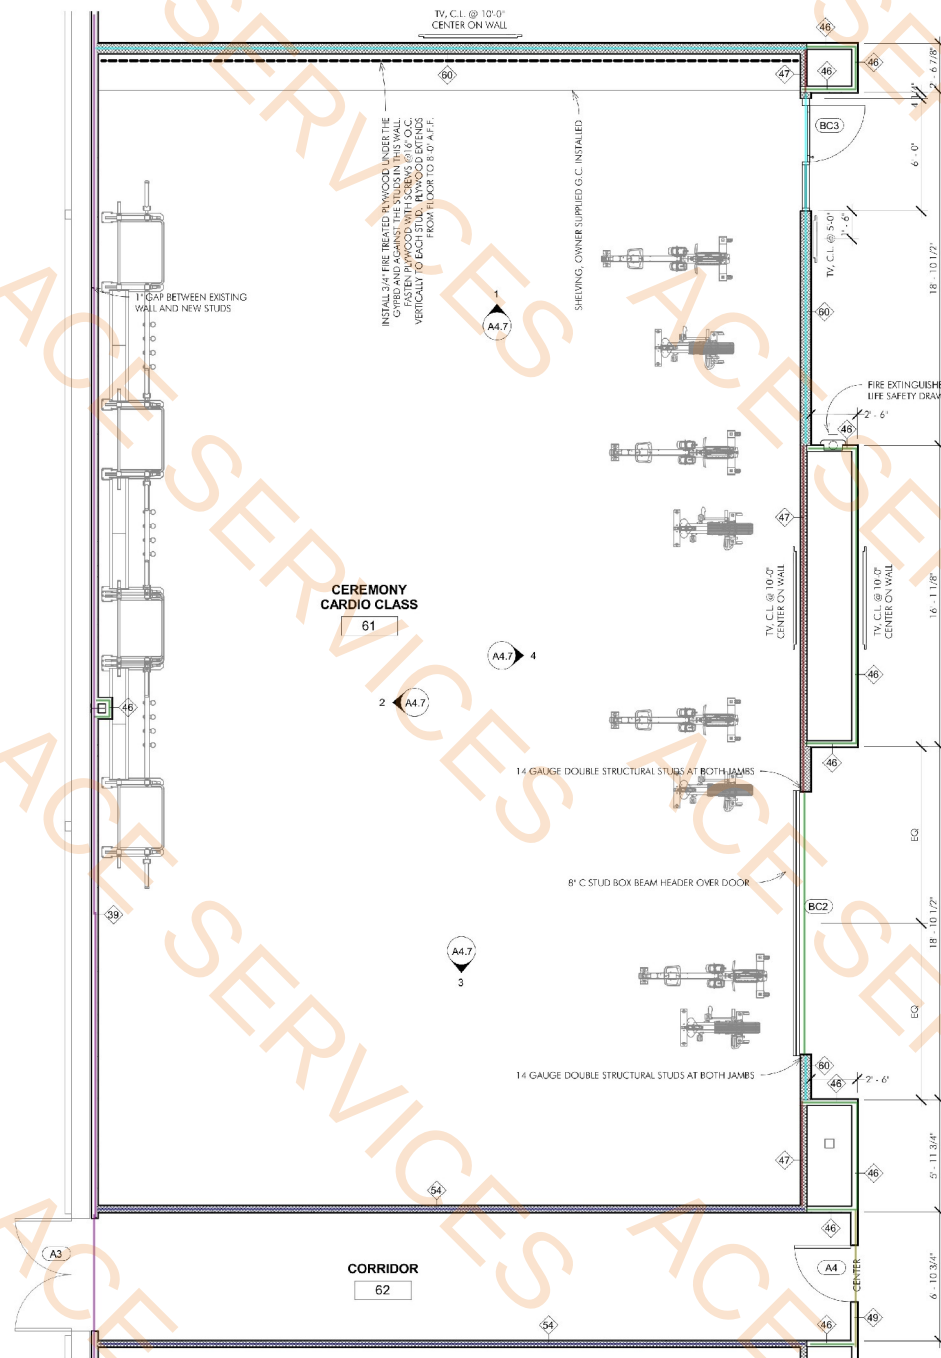

ENLARGED FLOOR PLAN - CEREMONY
CARDIO
1/4\"/>

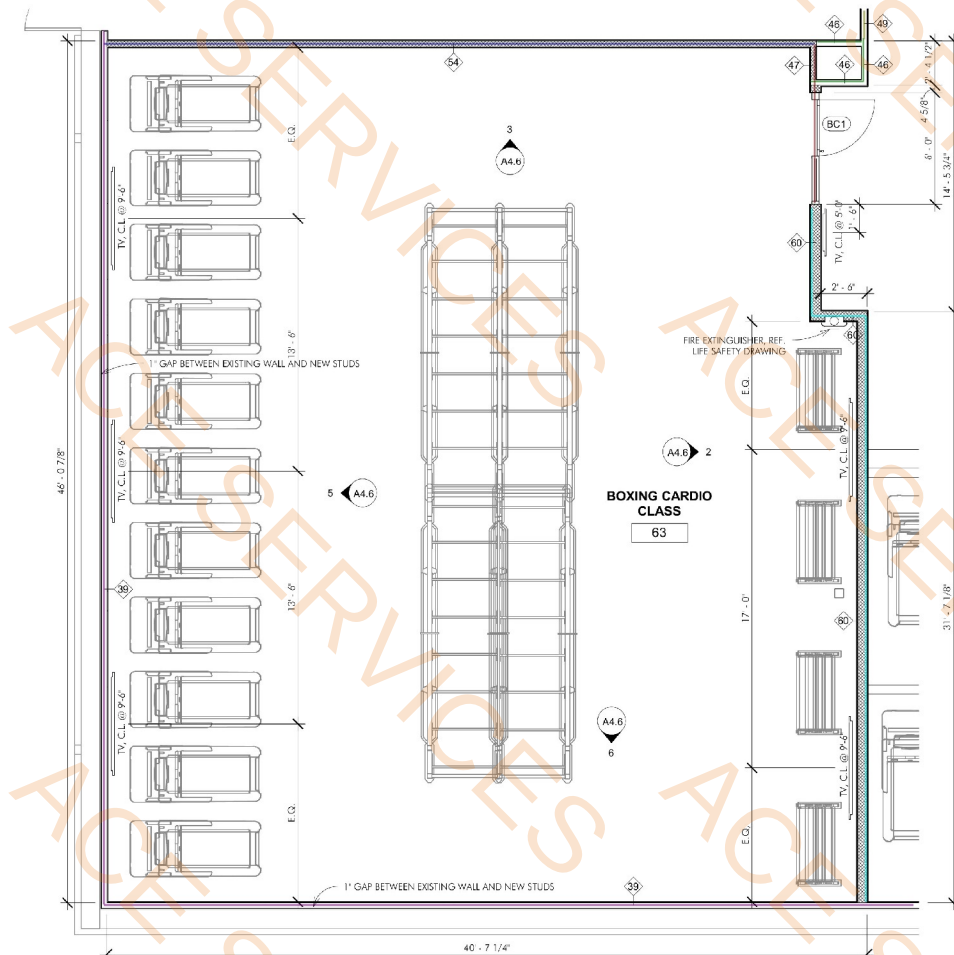

ENLARGED FLOOR PLAN - BOXING
CARDIO
1/4\"/>

NOTE: THE CONTRACT DRAWINGS ARE NOT ORIGINATED SPECIFICALLY FOR ANY GRANT, TRACT, DISTRICT, OR SUBCONTRACT. THEREFORE, ADDITIONAL RELATED INFORMATION MAY BE INCLUDED IN OTHER CONTRACT DRAWINGS AND SPECIFICATIONS EVEN THOUGH NOT SPECIFICALLY NOTED ON THE DOCUMENT. IT IS THE RESPONSIBILITY OF EACH PARTY TO REFER TO THE COMPLETE SET OF CONTRACT DRAWINGS AND SPECIFICATIONS AND NOT TO A PARTIAL OR INCOMPLETE SET OF DOCUMENTS.



Brent Barron Architect

P 6 0 1 . 7 5 0 . 1 7 7 8
114 WOODY HILLS DR. WASSON, MS 39110

ENLARGED FINISH PLANS
CLUB 4 FITNESS - EL PASO MONTWOOD

11705 MONTWOOD DR. EL PASO, TX 79936

20250321

FOR CONSTRUCTION
JUNE 05, 2025

A1.10

FLOOR CALL OUT
WALL BASE CALL OUT

FINISH MATERIAL GENERAL CALL OUT TAG (SPECIFIC NOTES OVERRIDE
GENERAL CALL OUT TAGS)


FINISH LEGEND
1/4" = 1'-0"

COLUMNS GET PB PAINT FLOOR TO DECK OR
CEILING. ON TOP OF PAINT APPLY WRAP 1 TO
4'-0" A.F.F., TYPICAL ALL COLUMNS IN PROJECT



PFT1

 50.8 SQ FT



ENLARGED FINISH PLAN - FRONT OF
HOUSE
1/4" = 1'-0"

NOTE: THE CONTRACT DRAWINGS ARE NOT ORGANIZED SPECIFICALLY FOR ANY CRATE, TRUCK, DISCIPLE, OR SUBCONTRACT. THEREFORE, ADDITIONAL RELATED INFORMATION MAY BE INCLUDED IN OTHER CONTRACT DRAWINGS AND SPECIFICATIONS EVEN
THOUGH NOT SPECIFICALLY NOTED ON THE DOCUMENT. IT IS THE RESPONSIBILITY OF EACH PARTY TO REFER TO THE COMPLETE SET OF CONTRACT DRAWINGS AND SPECIFICATIONS AND NOT TO A PARTIAL OR INCOMPLETE SET OF DOCUMENTS.



Brent Barron Architect

P 6 0 1 - 7 5 0 - 1 7 7 8
114 WOODY HILLS DR. WOODSON, MS 39110

ENLARGED FINISH PLANS
CLUB 4 FITNESS - EL PASO MONTWOOD
11705 MONTWOOD DR. EL PASO, TX 79936

20250321


FOR CONSTRUCTION
JUNE 05, 2025

A1.11

PFT2

260.4 SQ FT

FLOOR CALL OUT
WALL BASE CALL OUT
FINISH MATERIAL GENERAL CALL OUT TAG (SPECIFIC NOTES OVERRIDE
GENERAL CALL OUT TAGS)
FINISH LEGEND
1/4" = 1'-0"

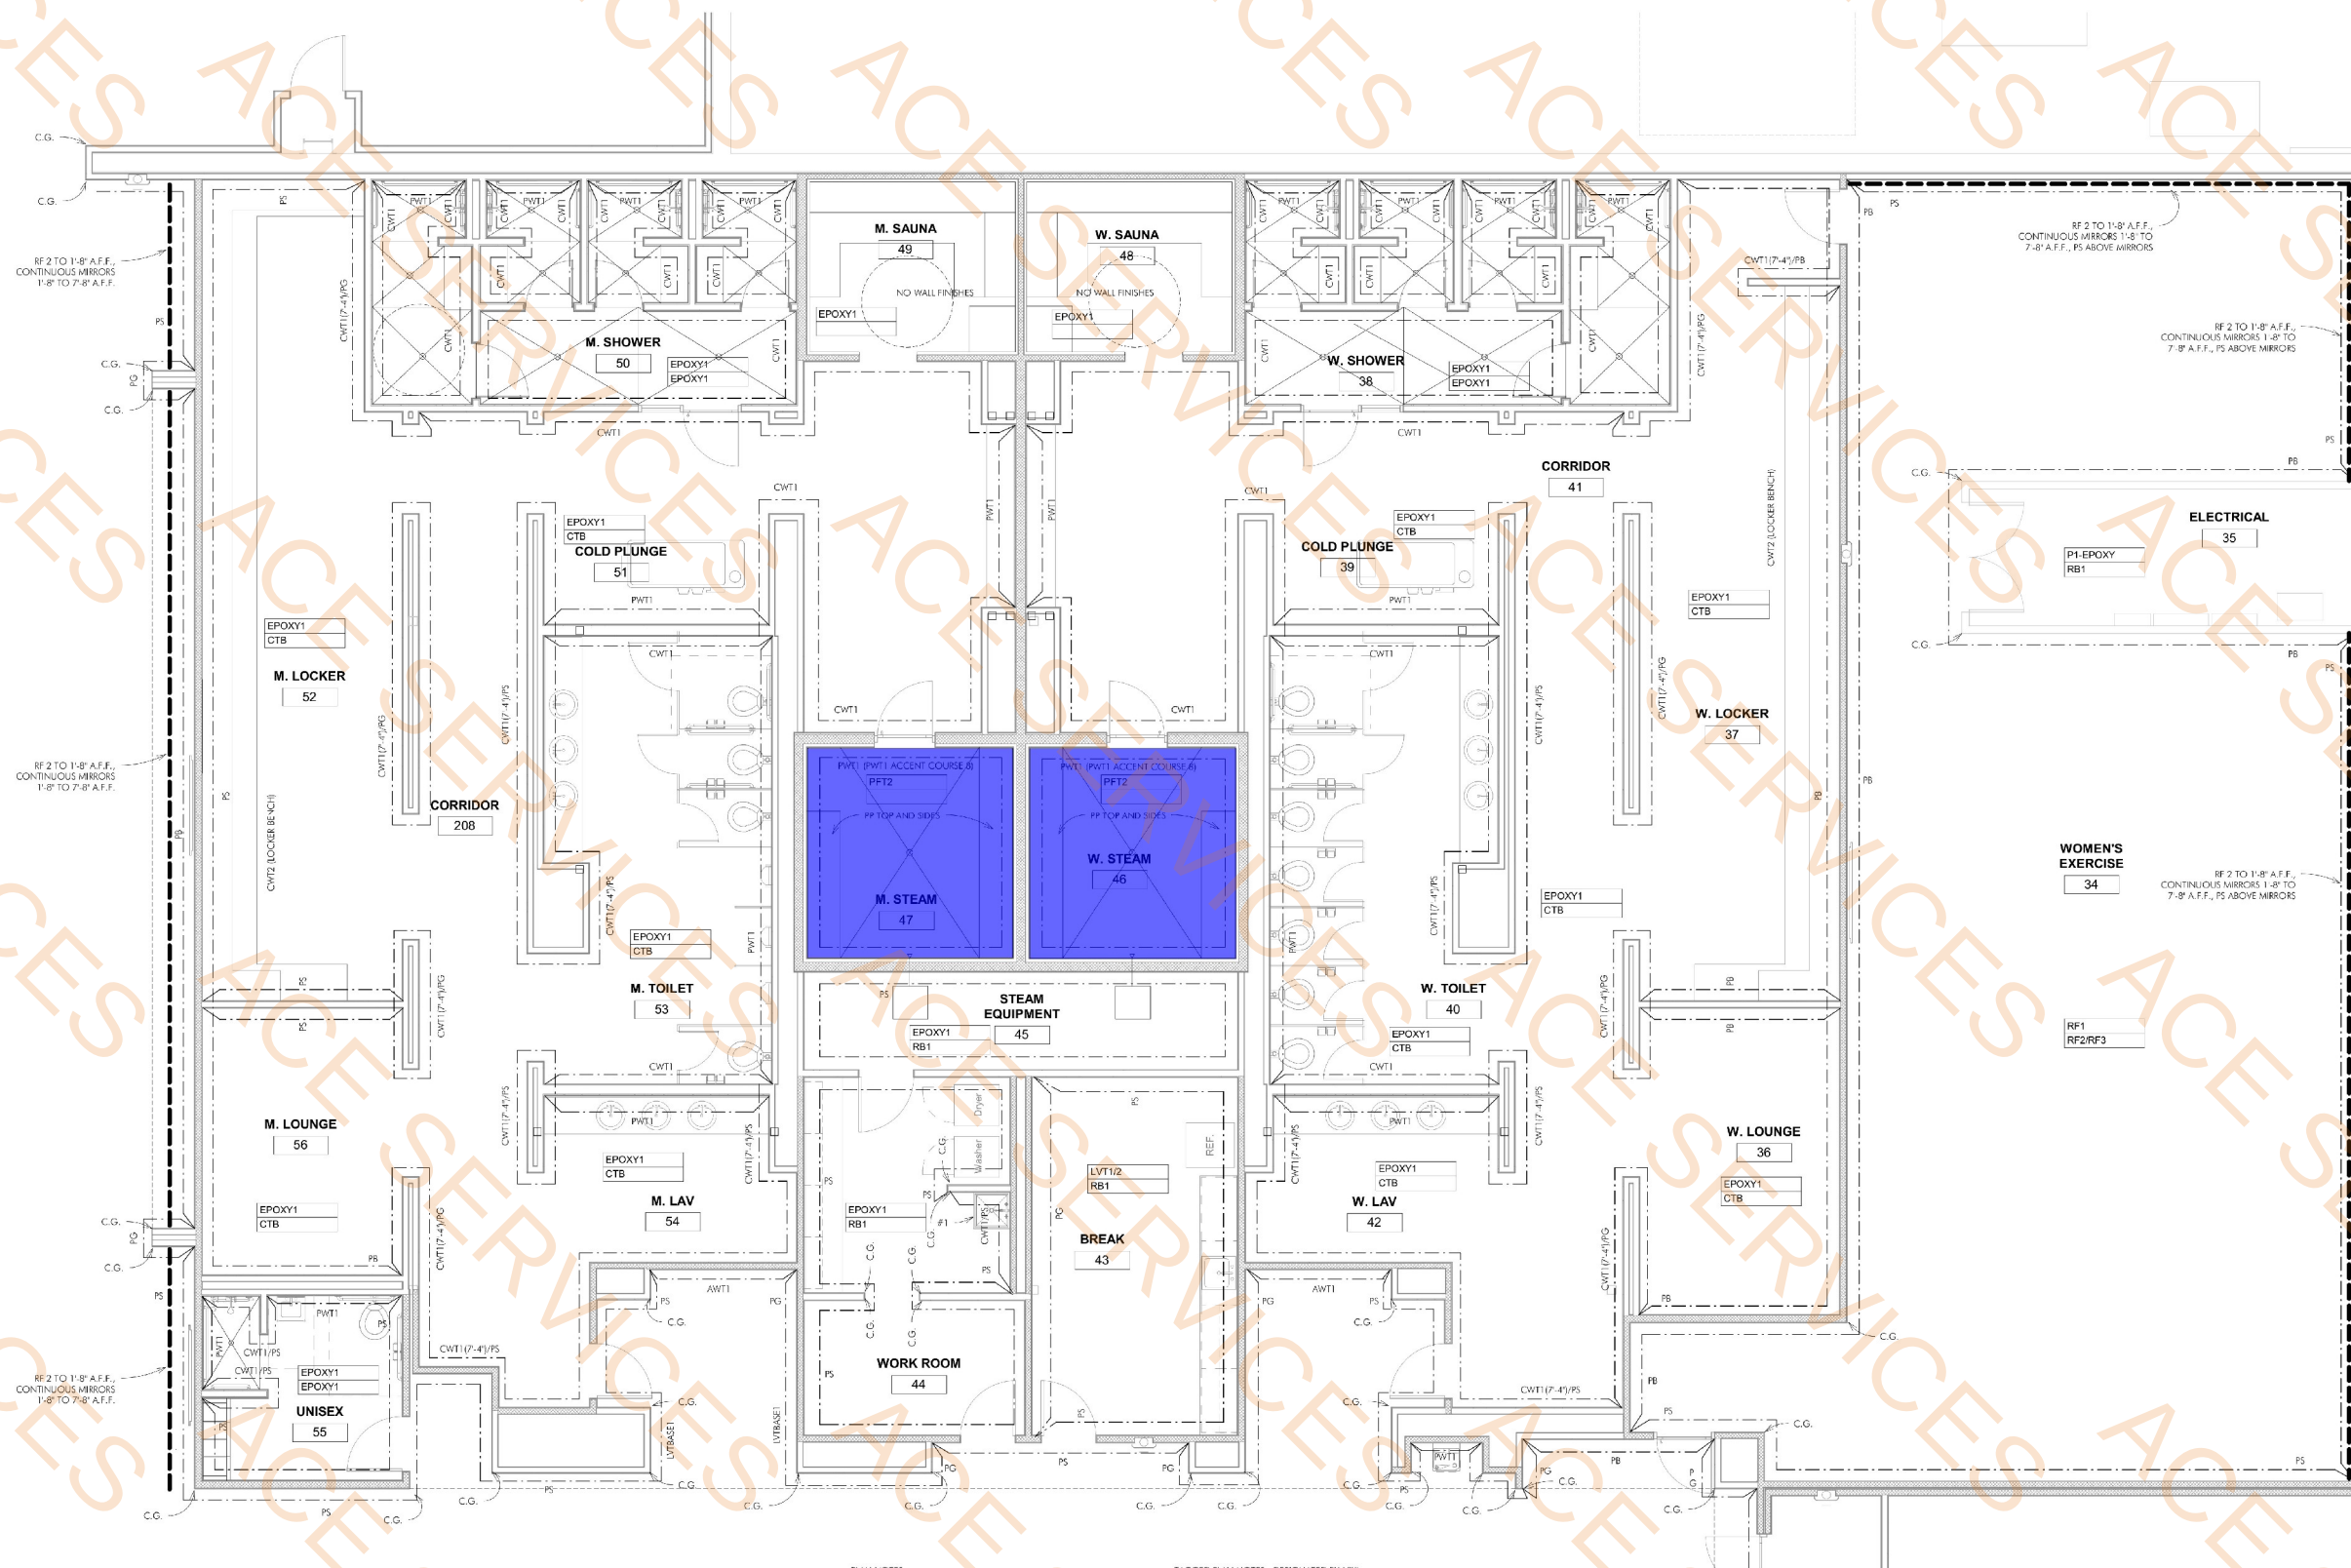

ENLARGED FINISH PLAN - LOCKER
AREA
1/4" = 1'-0"

PLAN NOTES:
1. ***** ALL CASES THE OUTSIDE CORNERS OF WALL TILE
AND THE TOP EDGE OF WALL TILE, WHEN WALL TILE DOES
NOT EXTEND TO THE CEILING, IS TO RECEIVE SCHLUTER
QUADEC-E IN STAINLESS STEEL, NO EXCEPTIONS *****

TAGGED PLAN NOTES - DESIGNATED BY "X"
1. WALL TILE TO BE INSTALLED TO 6'-0" AFF. TOP
EDGE OF TILE AND OUTSIDE CORNERS TO
RECEIVE SCHLUTER QUADEC-E IN STAINLESS STEEL.

NOTE: THE CONTRACT DRAWINGS ARE NOT ORIGINATED SPECIFICALLY FOR ANY GRANT, TRACT, DISCIPLINE, OR SUBCONTRACT. THEREFORE, ADDITIONAL RELATED INFORMATION MAY BE INCLUDED IN OTHER CONTRACT DRAWINGS AND SPECIFICATIONS EVEN
THOUGH NOT SPECIFICALLY NOTED ON THE DOCUMENT. IT IS THE RESPONSIBILITY OF EACH PARTY TO REFER TO THE COMPLETE SET OF CONTRACT DRAWINGS AND SPECIFICATIONS AND NOT TO A PARTIAL OR INCOMPLETE SET OF DOCUMENTS.



Brent Barron Architect








P 6 0 1 - 7 5 0 - 1 7 7 8
114 WOODY HILLS DR. WASSON, MS 39110

INTERIOR ELEVATIONS
CLUB 4 FITNESS - EL PASO MONTWOOD
11705 MONTWOOD DR. EL PASO, TX 79936

20250321

FOR CONSTRUCTION
JUNE 05, 2025

A4.1

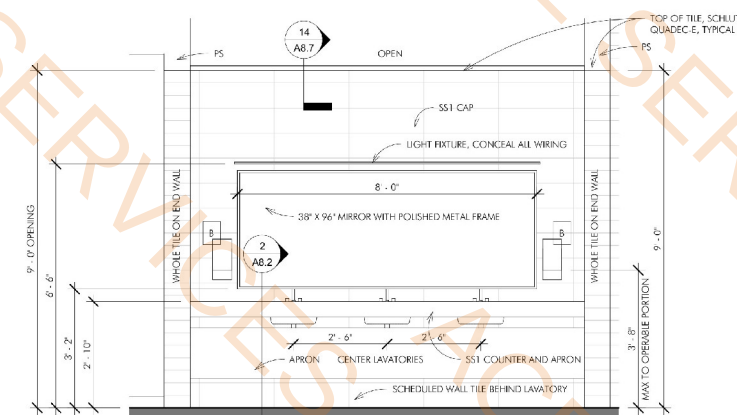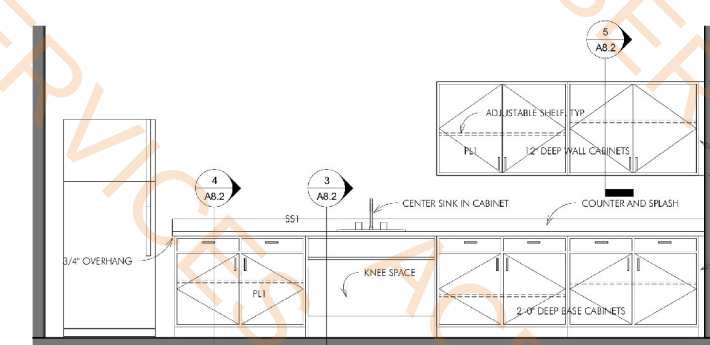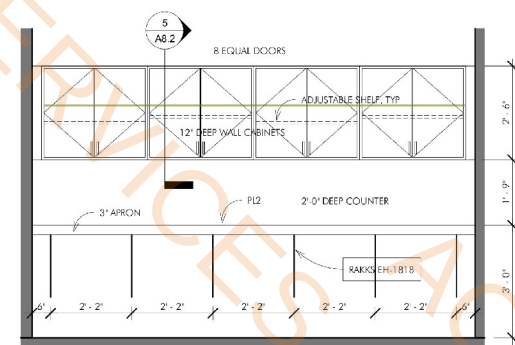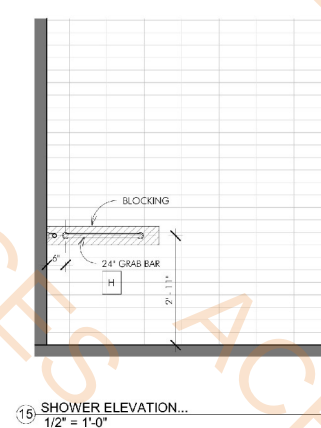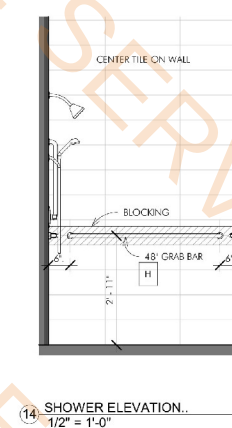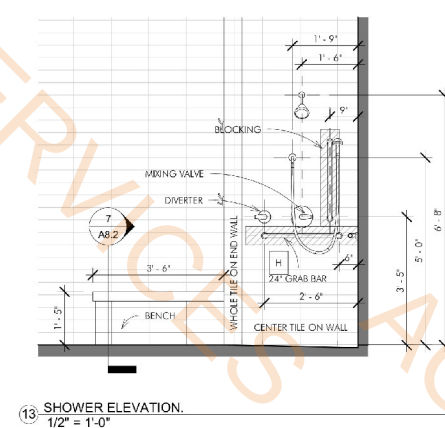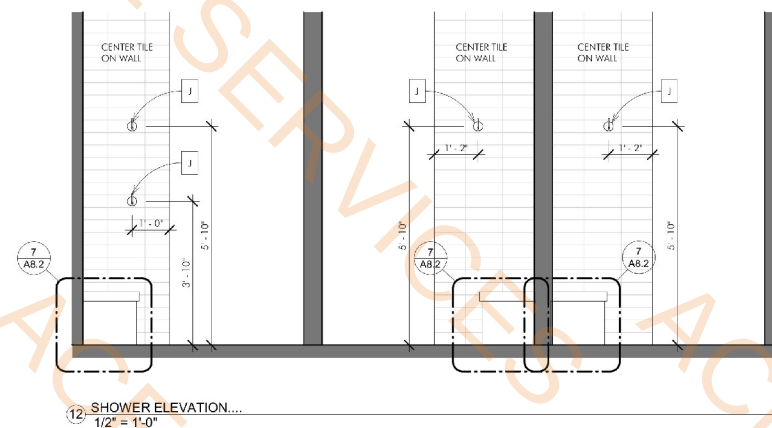


8 WORK ROOM ELEVATION
1/2" = 1'-0"

9 BREAK ROOM ELEVATION
1/2" = 1'-0"


11 LAVATORY ELEVATION
1/2" = 1'-0"

- 1'-4"DX1'-1"H DRAWER
- 1'-4"DX1'-1"H OPEN SHELF
- SS-1 COUNTERTOP AND PLYWOOD 1'-6" D
- A8.7/12 @3'-6"H
- 12"DX2'-6"H WALL CABINETS


- 2.1 FT
- 7.2 FT
- 22.7 FT
- 5.2 FT
- 11.2 FT

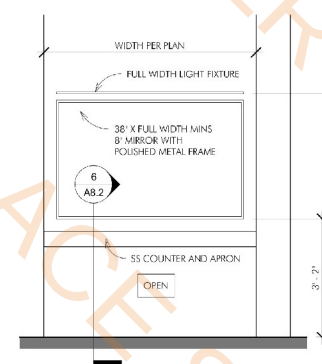

5 LOCKER VANITY COUNTER ELEVATION
1/2" = 1'-0"

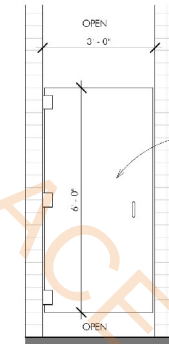


6 SHOWER DOOR ELEVATION.
1/2" = 1'-0"

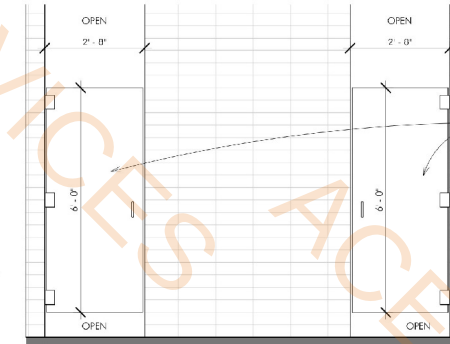


7 SHOWER DOOR ELEVATION.
1/2" = 1'-0"


GLASS SHOWER DOOR NOTES:
1. GLU GLAZING.
2. THREE HINGES PER DOOR.
DUAL PIVOT, SELF-CENTERING
WITHIN 5 DEGREES OF CLOSED
POSITION, EQUAL TO OR
LAURENCE #C00337CH.
3. HANDLES, 8" BACK TO BACK
WITHOUT METAL WASHERS, EQUAL
TO OR LAURENCE #BMVW000CH.

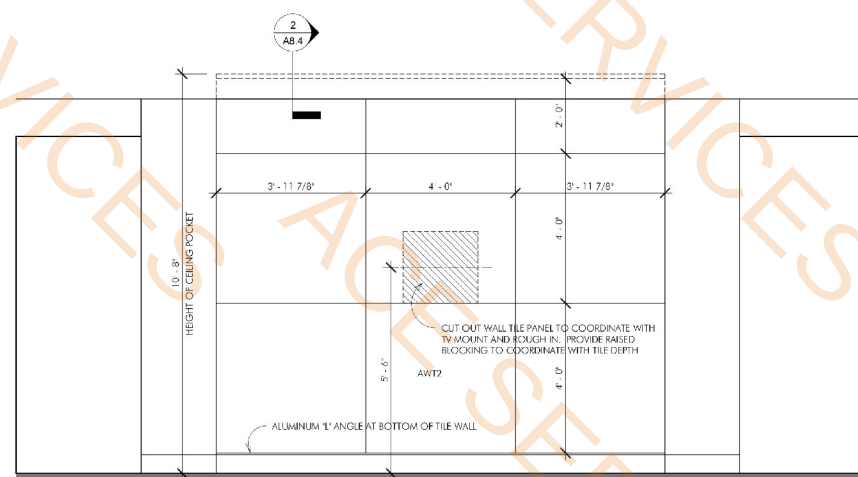

2 INTERIOR ELEVATION - MASSAGE
ROOM
1/2" = 1'-0"

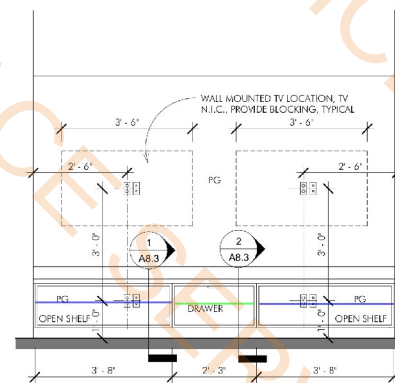

1 INTERIOR ELEVATION - T.V. ROOM
1/2" = 1'-0"

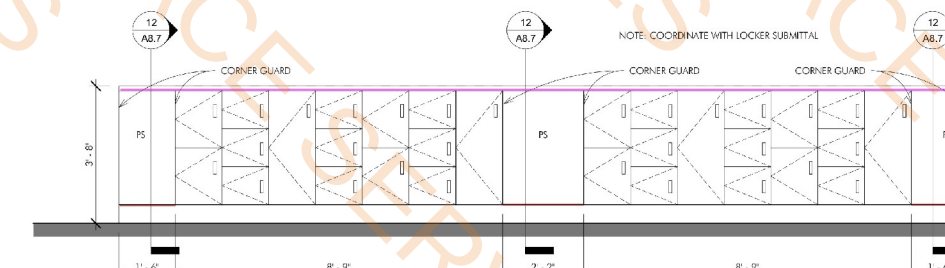

12 EXERCISE ROOM LOCKER ELEVATION
1/2" = 1'-0"

NOTE: THE CONTRACT DRAWINGS ARE NOT ORIGINATED SPECIFICALLY FOR ANY GRANT, TRACT, DISCOUNT, OR SUBCONTRACT. THEREFORE, ADDITIONAL RELATED INFORMATION MAY BE INCLUDED IN OTHER CONTRACT DRAWINGS AND SPECIFICATIONS EVEN
ALTHOUGH NOT SPECIFICALLY NOTED ON THE DOCUMENT. IT IS THE RESPONSIBILITY OF EACH PARTY TO REFER TO THE COMPLETE SET OF CONTRACT DRAWINGS AND SPECIFICATIONS AND NOT TO A PARTIAL OR INCOMPLETE SET OF DOCUMENTS.



20250321

INTERIOR ELEVATIONS
CLUB 4 FITNESS - EL PASO MONTWOOD

A4.2



- NOTE:** THE CONTRACT DRAWINGS ARE NOT ORGANIZED SPECIFICALLY FOR ANY CRAFT, TRADE, DISCIPLINE, OR SUBCONTRACT. THEREFORE, ADDITIONAL RELATED INFORMATION MAY BE INCLUDED IN OTHER CONTRACT DRAWINGS AND SPECIFICATIONS EVEN THOUGH NOT SPECIFICALLY NOTED ON THIS DOCUMENT. IT IS THE RESPONSIBILITY OF EACH PARTY TO REFER TO THE COMPLETE SET OF CONTRACT DRAWINGS AND SPECIFICATIONS, AND NOT TO A PARTIAL, OR INCOMPLETE SET OF DOCUMENTS.



Brent Barron Architect

P 6 0 1 - 7 5 0 - 1 7 7 8
114 WOODY HILLS DR, WACONIA, MN 55110

REFLECTED CEILING PLAN
CLUB 4 FITNESS - EL PASO MONTWOOD

11705 MONTWOOD DR, EL PASO, TX 79936


20250321

FOR CONSTRUCTION
JUNE 05, 2025

A6.1

OPEN CEILING P-5

30606.2 SQ FT

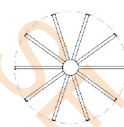

CEILING FAN, MOUNT 18" BELOW LIGHTS

CEILING FAN

PENDANT FIXTURE

RECESSED CAN FIXTURE

SUSPENDED TROUGH FIXTURE, MOUNT LENSE 12" BELOW BAR JOISTS AT LOW SIDE OF STRUCTURE

2X4 TROUGH FIXTURE

RETURN REGISTER

RETURN REGISTER

SUPPLY DIFFUSER


SUPPLY DIFFUSER

EXHAUST FAN

TELEVISION

REFLECTED CEILING PLAN LEGEND
1/8" = 1'-0"

- REFLECTED CEILING PLAN NOTES:
- COORDINATE THE WORK OF ALL TRADES INVOLVED IN THE CEILING WORK TO ENSURE CLEARANCES FOR FIXTURES, DUCTS, PIPING, CEILING SUSPENSION SYSTEM, ETC., NECESSARY TO MAINTAIN THE FINISHED CEILING HEIGHTS INDICATED ON ARCHITECT'S DRAWINGS.
 - PERIMETER CEILING ANGLE, WHERE OCCURS, SHALL BE INSTALLED TIGHT TO VERTICAL SURFACES, FREE FROM CURVES, BREAKS OR OTHER IRREGULARITIES AND FINISHED SAME AS GRID.
 - DO NOT CALLIGR GRID TO WALL.
 - FURNISH AND INSTALL ALL ASSOCIATED TRIM AND SEISMIC BRACING AS REQUIRED.
 - LIGHT FIXTURES, SPRINKLERS AND OTHER CEILING ELEMENTS SHALL BE CENTERED IN INDIVIDUAL CEILING TILES U.N.O. (EXIST). SPRINKLERS TO REMAIN UNLESS CONFLICT WITH NEW ELEMENTS.
 - UNLESS SPECIFICALLY NOTED OTHERWISE ALL CEILING GRID SHALL BE CENTERED BETWEEN PRIMARY WALL SURFACES. AVOID PERIMETER GRID SPACING LESS THAN 12".
 - PROVIDE MILD IN FLANGE CEILING ACCESS PANELS AS REQUIRED FOR EQUIPMENT AND SYSTEM MAINTENANCE, AND MATCH ADJACENT CEILING FINISH U.N.O.
 - PROVIDE MAINTENANCE CLEARANCE FOR MECHANICAL EQUIPMENT ABOVE CEILING.
 - ALL SLOTTED AND CEILING HEIGHTS ARE DIMENSIONED FROM TOP OF FINISHED FLOOR TO BOTTOM OF FINISHED GYPSUM BOARD OR CEILING TILE.
 - ALL SPECIFIC INFORMATION CONCERNING INSTALLATION FOR VARIOUS ABOVE CEILING ELEMENTS ARE TO BE DESIGN BUILD. DOCUMENTATION BY OTHERS.
 - NOTIFY ARCHITECT OF ANY CONFLICTS OF LIGHT FIXTURE LOCATIONS WITH MAIN RUNNERS, DUCTS, STRUCTURES, HVAC AND/OR CONDUIT, PRIOR TO FRAMING FOR LIGHTS. ANY DISCREPANCIES BETWEEN ARCHITECT'S CEILING GRID LOCATION & ACTUAL FIELD CONDITIONS ARE TO BE CLARIFIED WITH THE ARCHITECT PRIOR TO CONSTRUCTING.
 - VERIFY FIELD CONDITIONS AND LOCATIONS OF ALL PLUMBING, MECHANICAL DUCTS, STRUCTURAL ELEMENTS AND ALL OTHER RELATED ITEMS. INSTALL NEW PLUMBING, MECHANICAL FANS, DUCTS, CONDUITS, AND OTHER RELATED ITEMS SO AS TO NOT CONFLICT WITH ANY ALL FIELD CONDITIONS INCLUDING LUMINAIRES.
 - ALL EXIT LIGHT AND EGRESS LIGHT LOCATIONS SHALL BE DETERMINED BY BUILDING AND FIRE INSPECTOR'S FIELD PLACEMENT DETERMINATIONS.
 - INSTALL 2 LAYERS OF 3-1/2" UNFACED BATT INSULATION ABOVE ALL ACT (ACOUSTICAL CEILING TILE).

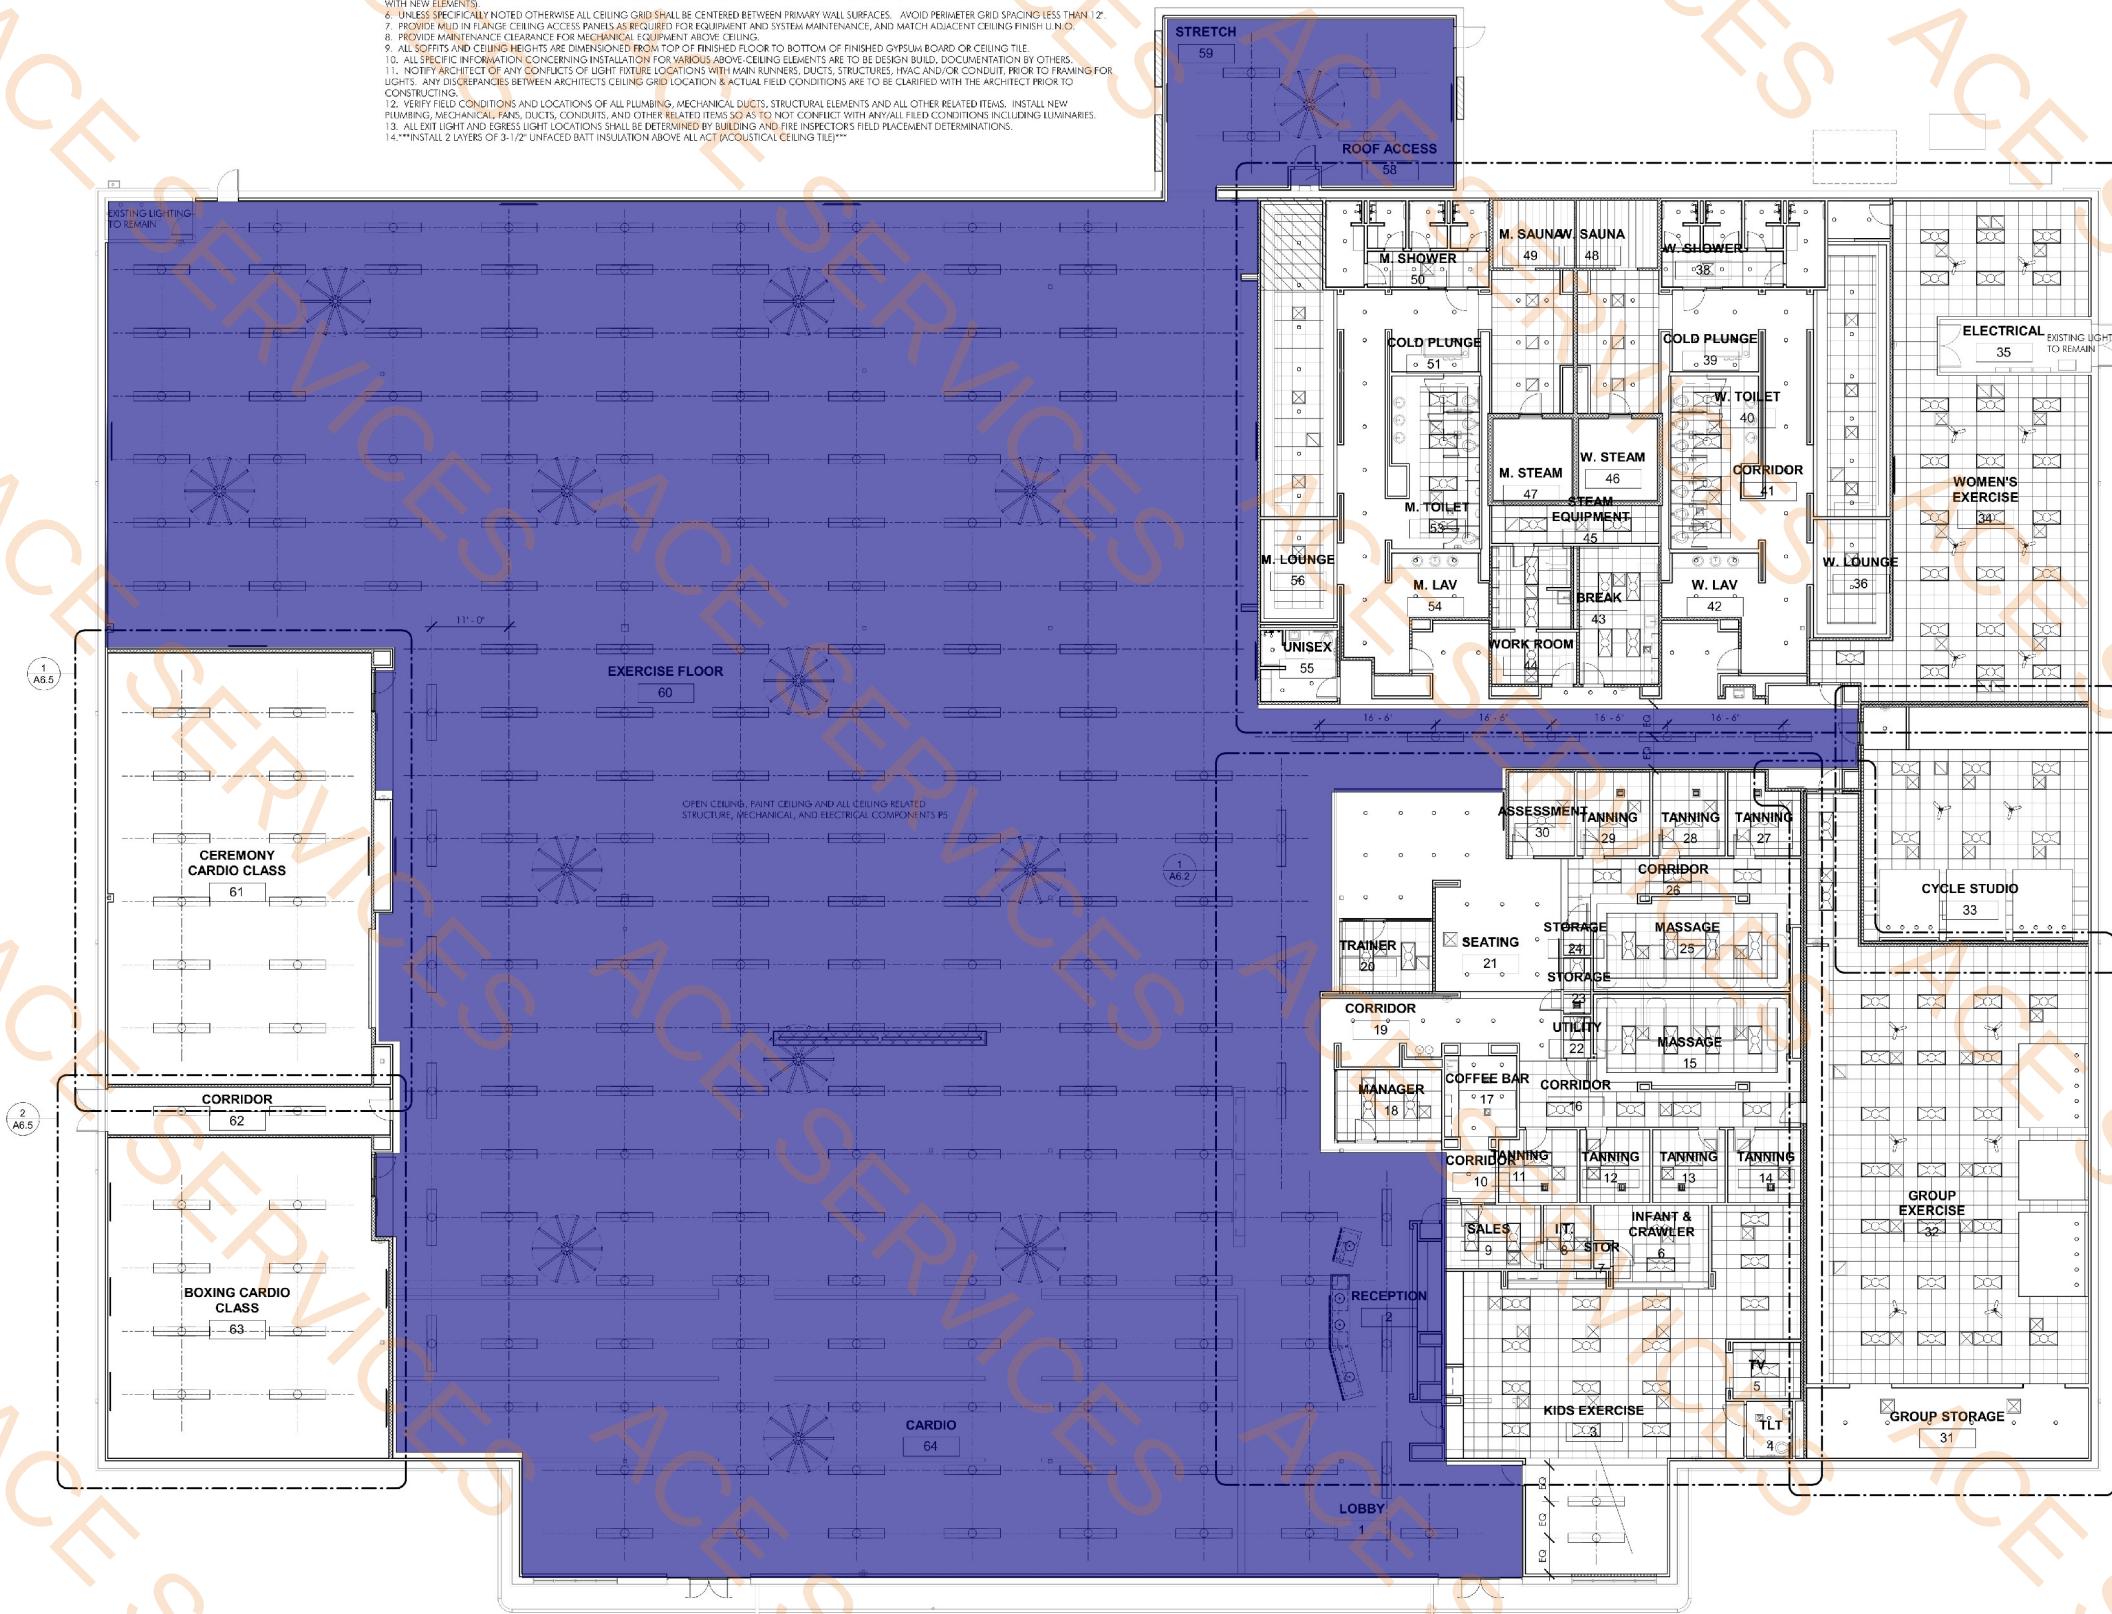

REFLECTED CEILING PLAN
3/32" = 1'-0"

NOTE: THE CONTRACT DRAWINGS ARE NOT ORIGINATED SPECIFICALLY FOR ANY GRANT, TRACT, DISCOUNT, OR SUBCONTRACT. THEREFORE, ADDITIONAL RELATED INFORMATION MAY BE INCLUDED IN OTHER CONTRACT DRAWINGS AND SPECIFICATIONS EVEN IF NOT SPECIFICALLY NOTED ON THE DOCUMENT. IT IS THE RESPONSIBILITY OF EACH PARTY TO REFER TO THE COMPLETE SET OF CONTRACT DRAWINGS AND SPECIFICATIONS AND NOT TO A PARTIAL OR INCOMPLETE SET OF DOCUMENTS.



20250321

ENLARGED REFLECTED CEILING PLAN
CLUB 4 FITNESS - EL PASO MONTWOOD

FOR CONSTRUCTION
JUNE 05, 2025

A6.2



- TYPE-1 GYPBD
- LAT-1
- WHITE EGG CRATE TILES
- TYPE-1 GYPBD PB
- TYPE-1 GYPBD PS
- TYPE-1 GYPBD PG
- TYPE-1 GYPBD P5
- TYPE-1 GYPBD P4
- TYPE-1 GYPBD P6
- OPEN CEILING
- 2"D SOFFIT
- 1"D SOFFIT
- 6"D SOFFIT
- 8"D SOFFIT
- 4"D SOFFIT
- TYPE-1 MOISTURE RESIS
- 8" Runner

1. ALL SUSPENSION SYSTEMS ETC. SHALL BE INSTALLED IN ACCORDANCE WITH THE MANUFACTURER'S RECOMMENDATIONS INDICATED ON ARCHITECT'S DRAWINGS.
2. ALL CEILING LIGHT FIXTURES SHALL BE INSTALLED TO VERTICAL SURFACES AND NOT ON CORNERS, BRACKETS OR OTHER PROTRUSIONS.
3. LIGHTING SHALL BE COORDINATE WITH WALL.
4. ALL ELECTRICAL WORK AND SERVICE EQUIPMENT REQUIRED FOR THE PROJECT SHALL BE INSTALLED IN CONFORMANCE WITH THE LOCAL, STATE, NATIONAL AND INTERNATIONAL ELECTRICAL CODES.
5. ALL ELECTRICAL WIRING SHALL BE CONCEALED BY A CONCEALED WIRING ELEMENT.
6. ALL ELECTRICAL PANELS ARE REQUIRED TO BE LOCATED AT THE MAIN ENTRANCE OF THE BUILDING FOR EASY ACCESS FOR SYSTEM MAINTENANCE, AND MATCHED TO EXISTING CONDITIONS.
7. ALL SLOTTES AND CEILING HEIGHTS ARE DIMENSIONED FROM TOP OF FINISHED FLOOR TO BOTTOM OF FINISHED GYPSUM BOARDED CEILING TILE.
8. ALL SPECIFIC INFORMATION CONCERNING INSTALLATION FOR VARIOUS ABOVE-CEILING ELEMENTS ARE TO BE DESIGN BUILT, DOCUMENTED BY OTHERS.
9. NOTIFY ARCHITECT OF ANY CONFLICTS OF LIGHT FIXTURE LOCATIONS WITH MAIN RIGGERS, DUCTS, STRUCTURES, HVAC AND/OR CONDENSATE PIPING TO FRAMING FOR LIGHTS. ANY DISCREPANCIES BETWEEN ARCHITECTS CEILING GRID LOCATION & ACTUAL FIELD CONDITIONS ARE TO BE CLARIFIED WITH THE ARCHITECT PRIOR TO CONSTRUCTING.
10. VERIFY FIELD CONDITIONS AND LOCATIONS OF ALL PLUMBING, MECHANICAL DUCTS, STRUCTURAL ELEMENTS AND ALL OTHER RELATED ITEMS. CONSULT WITH PLUMBING, MECHANICAL, FANS, DUCTS, CONDUNITs, AND OTHER RELATED ITEMS SO AS TO NOT CONTACT WITH ANY/ALL FIELD CONDITIONS INCLUDING LUMINAIRES.
11. ALL EXIST LIGHT AND EGRESS LIGHT INSTALLATION SHALL BE DETERMINED BY BUILDING AND FIRE INSPECTORS FIELD PLACEMENT DETERMINATIONS.
12. "INSTALL LAYERS OF 3-1/2" UNFACED BATT INSULATION ABOVE ALL ACoustICAL CEILING TILES!"

TAGGED REFLECTED CEILING PLAN NOTES - DESIGNATED BY *#X
1. WHITE EGG CRATE TILES.

0.0 SQ FT	
3553.5 SQ FT	
61.3 SQ FT	
327.0 SQ FT	
261.6 SQ FT	
713.4 SQ FT	
166.6 SQ FT	
42.9 SQ FT	
130.0 SQ FT	
4.5 SQ FT	
134.8 SQ FT	
77.7 FT	
45.9 FT	
5.0 FT	
3.0 FT	
52.1 SQ FT	
462.8 FT	

DASHED LINES REPRESENT
WALL THAT GOES ALL THE
WAY TO THE DECK

DASHED LINES REPRESENT
#ALL THAT GOES ALL THE

MOUNT PENDANTS SO BASE IS 8'-6" A.F.

1 ENLARGED REFLECTED CEILING PLAN
1/4" = 1'-0"

NOTE: THE CONTRACT DRAWINGS ARE NOT ORGANIZED SPECIFICALLY FOR ANY CRAFT, TRADE, DISCIPLINE, OR SUBCONTRACT. THEREFORE, ADDITIONAL RELATED INFORMATION MAY BE INCLUDED IN OTHER CONTRACT DRAWINGS AND SPECIFICATIONS EVEN THOUGH NOT SPECIFICALLY NOTED ON THIS DOCUMENT. IT IS THE RESPONSIBILITY OF EACH PARTY TO REFER TO THE COMPLETE SET OF CONTRACT DRAWINGS AND SPECIFICATIONS, AND NOT TO A PARTIAL OR INCOMPLETE SET OF DOCUMENTS.





Brent Barron Architect

P 6 0 1 - 7 5 0 - 1 7 7 8
114 WOODY HILLS DR. WASSON, MO 63010

ENLARGED REFLECTED CEILING PLAN
CLUB 4 FITNESS - EL PASO MONTWOOD

11705 MONTWOOD DR. EL PASO, TX 79936

20250321

FOR CONSTRUCTION
JUNE 05, 2025

A6.3

- LAT-1
- TYPE-1 GYPBD
- LAT-3
- JOIST CEILING
- TAG-1 CEILING
- SCHLUTER DILEX-BWS
- OPEN CEILING
- TYPE-1 GYPBD P5
- TYPE-1 GYPBD PS
- TYPE-1 GYPBD PG
- 2"D SOFFIT
- A8.4/3
- A8.4/1
- A8.4/10
- A8.4/2
- TYPE-1 MOISTURE RESISTANT GYPBD P-5
- 8" Runner


- 3367.5 SQ FT
- 204.9 SQ FT
- 727.7 SQ FT
- 218.3 SQ FT
- 261.9 SQ FT
- 46.6 SQ FT
- 94.7 SQ FT
- 1595.2 SQ FT
- 236.2 SQ FT
- 457.6 SQ FT
- 286.7 SQ FT
- 245.9 SQ FT
- 27.4 SQ FT
- 2.9 SQ FT
- 22.6 SQ FT
- 315.9 SQ FT
- 741.9 SQ FT

REFLECTED CEILING PLAN NOTES:

- COORDINATE THE WORK OF ALL TRADES INVOLVED IN THE CEILING WORK TO ENSURE CLEARANCES FOR FIXTURES, DUCTS, PIPING, CEILING SUSPENSION SYSTEM, ETC., NECESSARY TO MAINTAIN THE FINISHED CEILING HEIGHTS INDICATED ON ARCHITECTS DRAWINGS.
- PERIMETER CEILING ANGLE, WHERE OCCURS, SHALL BE INSTALLED TIGHT TO VERTICAL SURFACES, FREE FROM CURVES, BREAKS OR OTHER IRREGULARITIES AND FINISHED SAME AS GRID.
- DO NOT CALLIG GRID TO WALL.
- FURNISH AND INSTALL ALL ASSOCIATED TRIM AND SEWIC BRACING AS REQUIRED.
- LIGHT FIXTURES, SPRINKLERS AND OTHER CEILING ELEMENTS SHALL BE CENTERED IN INDIVIDUAL CEILING TILES UNLESS OTHERWISE NOTED.
- UNLESS SPECIFICALLY NOTED OTHERWISE ALL CEILING GRID SHALL BE CENTERED BETWEEN PRIMARY WALL SURFACES. AVOID PERIMETER GRID SPACING LESS THAN 12".
- PROVIDE MUD IN FLANGE CEILING ACCESS PANELS AS REQUIRED FOR EQUIPMENT AND SYSTEM MAINTENANCE, AND MATCH ADJACENT CEILING FINISH UNLESS OTHERWISE NOTED.
- PROVIDE MAINTENANCE CLEARANCE FOR MECHANICAL EQUIPMENT ABOVE CEILING.
- ALL SOFFITS AND CEILING HEIGHTS ARE DIMENSIONED FROM TOP OF FINISHED FLOOR TO BOTTOM OF FINISHED GYPSUM BOARD OR CEILING TILE.
- ALL SPECIFIC INFORMATION CONCERNING INSTALLATION FOR VARIOUS ABOVE-CEILING ELEMENTS ARE TO BE DESIGN BUILD, DOCUMENTATION BY OTHERS.
- NOTIFY ARCHITECT OF ANY CONFLICTS OF LIGHT FIXTURE LOCATIONS WITH MAIN RUNNERS, DUCTS, STRUCTURES, HVAC AND/OR CONDUIT PRIOR TO FRAMING FOR LIGHTS. ANY DISCREPANCIES BETWEEN ARCHITECTS CEILING GRID LOCATION & ACTUAL FIELD CONDITIONS ARE TO BE CLARIFIED WITH THE ARCHITECT PRIOR TO CONSTRUCTING.
- VERIFY FIELD CONDITIONS AND LOCATIONS OF ALL PLUMBING, MECHANICAL DUCTS, STRUCTURAL ELEMENTS AND ALL OTHER RELATED ITEMS. INSTALL NEW PLUMBING, MECHANICAL, FANS, DUCTS, CONDUITS, AND OTHER RELATED ITEMS SO AS TO NOT INTERFERE WITH ANY/ALL FIELD CONDITIONS INCLUDING LUMINAIRES.
- ALL EXISTING LIGHT LOCATIONS SHALL BE DETERMINED BY BUILDING AND FIRE INSPECTORS FIELD PLACEMENT DETERMINATIONS.
- INSTALL 2 LAYERS OF 3-1/2" UNFACED BATT INSULATION ABOVE ALL ACT (ACOUSTICAL CEILING TILE).

TAGGED PLAN NOTES - DESIGNATED BY "X"

- 4005137-35 STRUCTURAL STUD GALVANIZED CEILING JOISTS @ 16" O.C., R30 BATT INSULATION WITH RETAINER WIRES, FULL COVERAGE, NO GAPS, 2" THICK KERDI BOARD SHEATHING, CERAMIC TILE TO BE SELECTED. REFERENCE STEAM ROOM NOTES FOR DETAILS.
- SCHLUTER DILEX-BWS

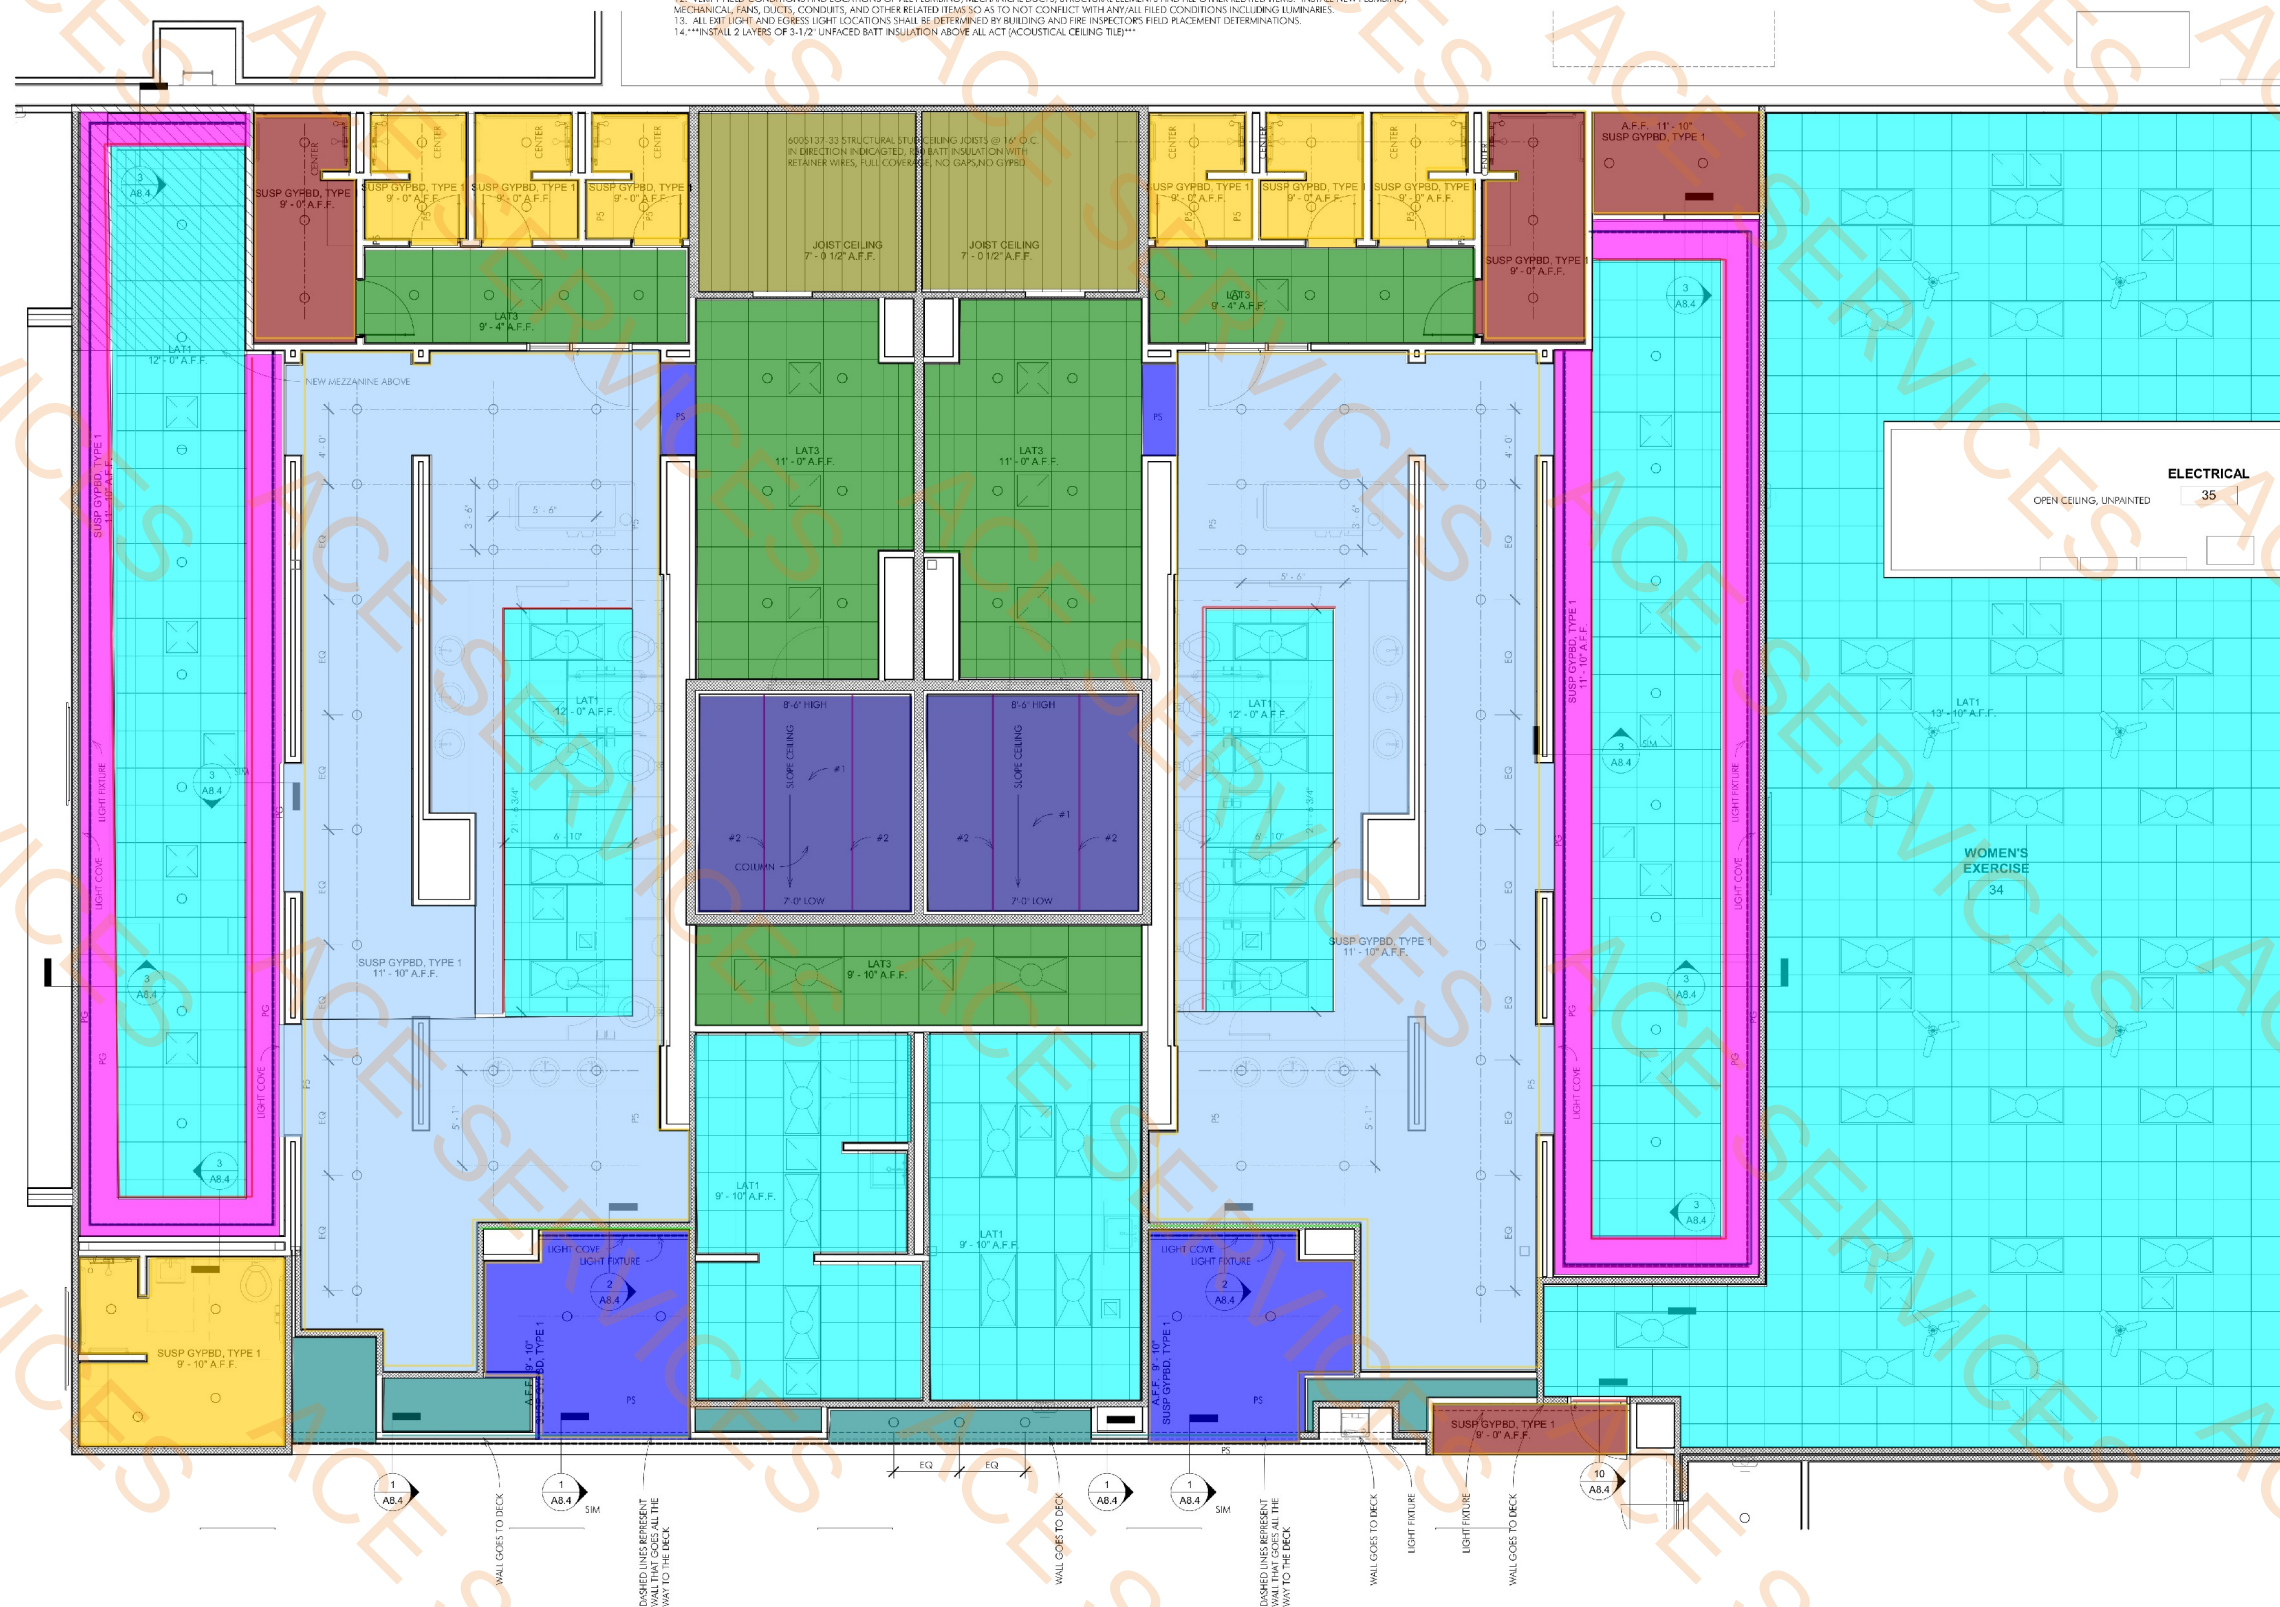

ENLARGED REFLECTED CEILING PLAN -
LOCKER ROOMS
1/4" = 1'-0"

NOTE: THE CONTRACT DRAWINGS ARE NOT ORIGINATED SPECIFICALLY FOR ANY GRANT, TRACT, DISCIPLINE, OR SUBCONTRACT. THEREFORE, ADDITIONAL RELATED INFORMATION MAY BE INCLUDED IN OTHER CONTRACT DRAWINGS AND SPECIFICATIONS EVEN THOUGH NOT SPECIFICALLY NOTED ON THE DOCUMENT. IT IS THE RESPONSIBILITY OF EACH PARTY TO REFER TO THE COMPLETE SET OF CONTRACT DRAWINGS AND SPECIFICATIONS AND NOT TO A PARTIAL OR INCOMPLETE SET OF DOCUMENTS.




ENLARGED REFLECTED CEILING PLAN
CLUB 4 FITNESS - EL PASO MONTWOOD

11705 MONTWOOD DR, EL PASO, TX 79930

20250321

FOR CONSTRUCTION
JUNE 05, 2025

A6.4

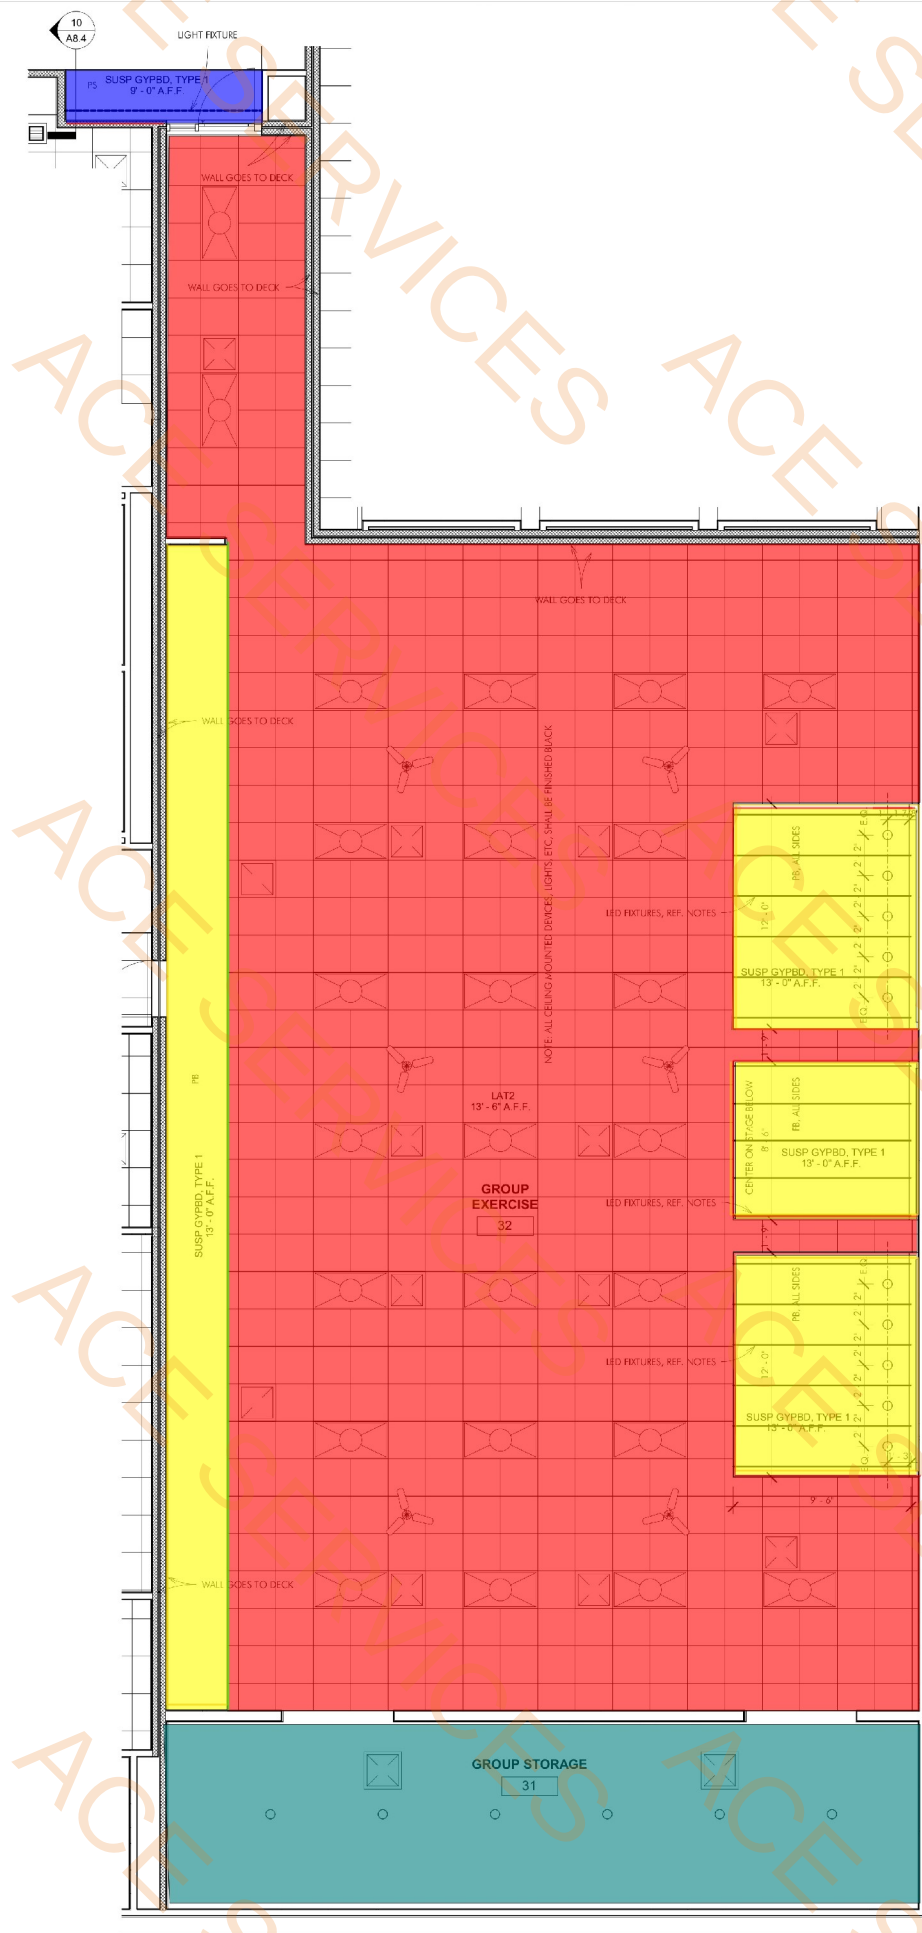

ENLARGED REFLECTED CEILING PLAN -
GROUP EXERCISE
1/4" = 1'-0"

NOTE: THE CONTRACT DRAWINGS ARE NOT ORGANIZED SPECIFICALLY FOR ANY CRAFT, TRADE, DISCIPLINE, OR SUBCONTRACT. THEREFORE, ADDITIONAL RELATED INFORMATION MAY BE INCLUDED IN OTHER CONTRACT DRAWINGS AND SPECIFICATIONS EVEN THOUGH NOT SPECIFICALLY NOTED ON THIS DOCUMENT. IT IS THE RESPONSIBILITY OF EACH PARTY TO REFER TO THE COMPLETE SET OF CONTRACT DRAWINGS AND SPECIFICATIONS, AND NOT TO A PARTIAL OR INCOMPLETE SET OF DOCUMENTS.



Brent Barron Architect

P 6 0 1 - 7 5 0 - 1 7 7 8
114 WOODY HILLS DR, WADSWORTH, TX 75070

ENLARGED REFLECTED CEILING PLAN
CLUB 4 FITNESS - EL PASO MONTWOOD

11705 MONTWOOD DR, EL PASO, TX 79936


20250321

FOR CONSTRUCTION
JUNE 05, 2025


A6.5

OPEN CEILING P-9

4110.1 SQ FT












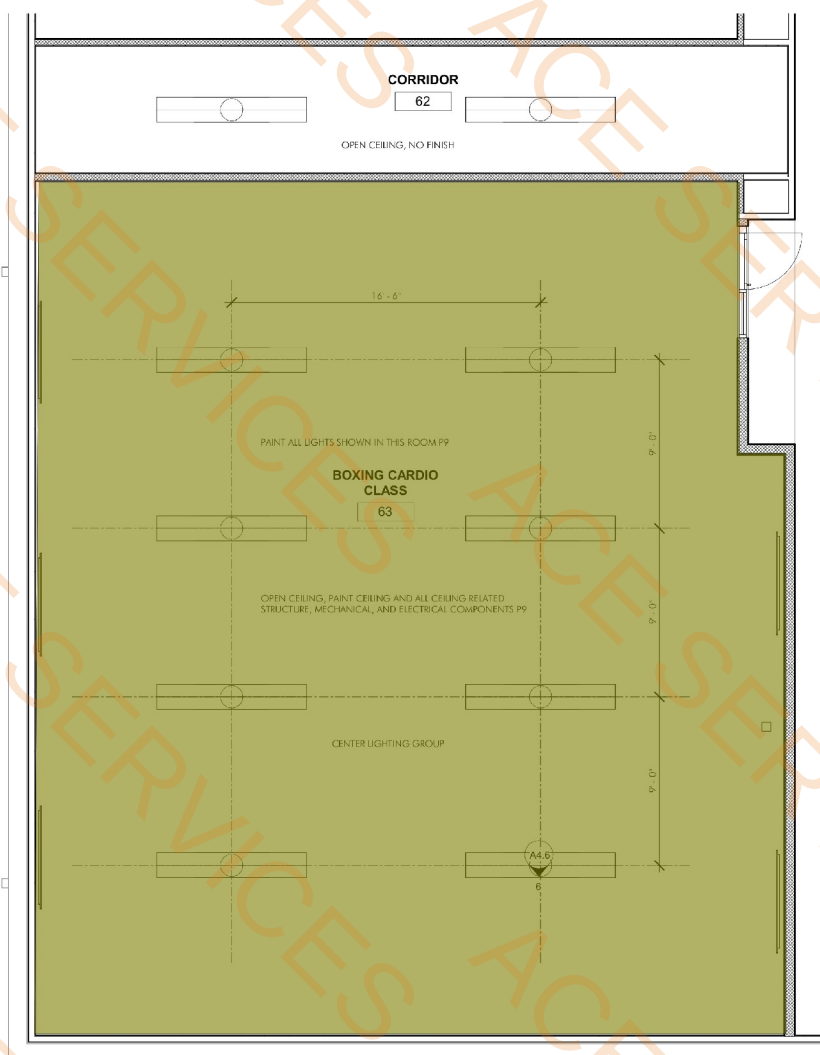


2 ENLARGED REFLECTED CEILING PLAN -
BOXING CARDIO
1/4" = 1'-0"

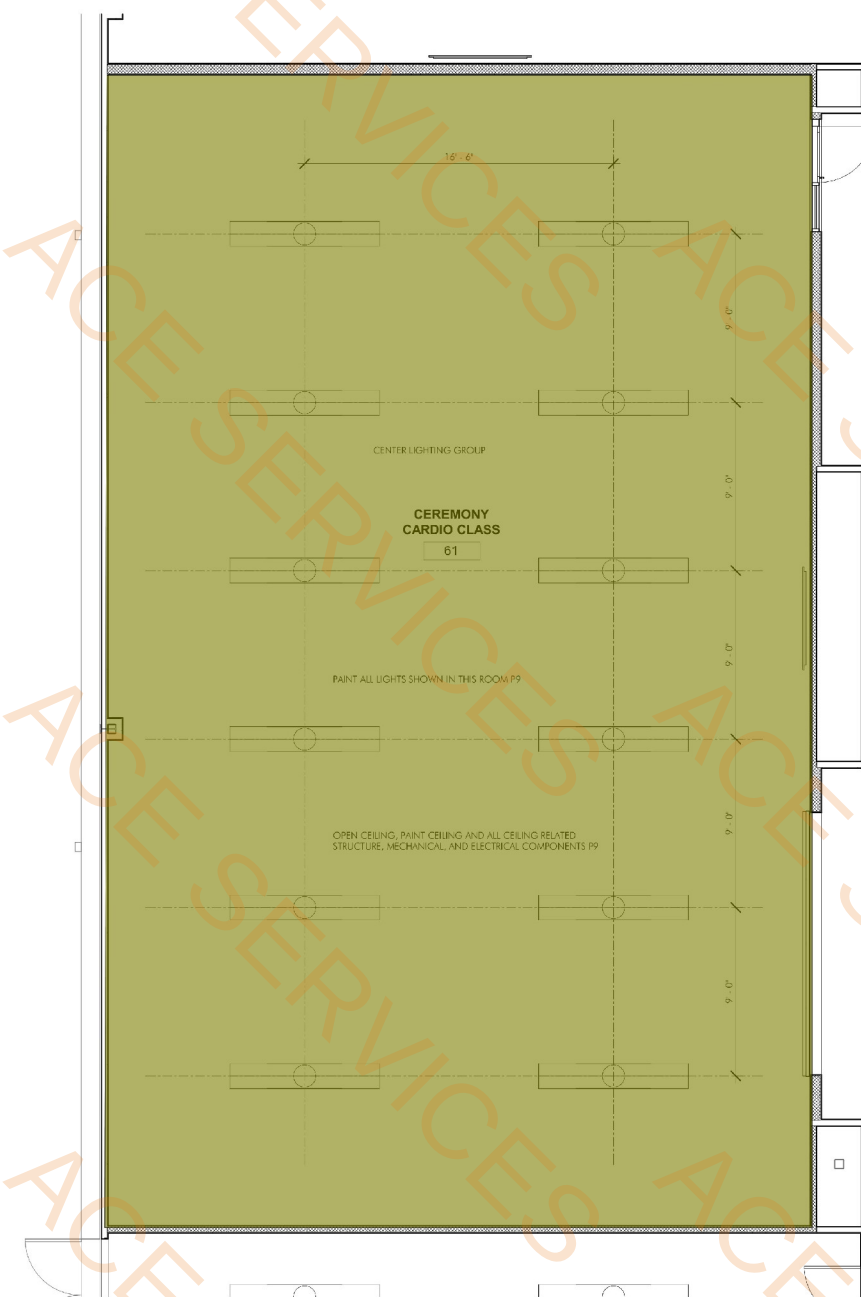

1 ENLARGED REFLECTED CEILING PLAN -
CEREMONY CARDIO
1/4" = 1'-0"

NOTE: THE CONTRACT DRAWINGS ARE NOT ORIGINATED SPECIFICALLY FOR ANY GRANT, TRACT, DISCIPLINE, OR SUBCONTRACT. THEREFORE, ADDITIONAL RELATED INFORMATION MAY BE INCLUDED IN OTHER CONTRACT DRAWINGS AND SPECIFICATIONS EVEN
IF NOT SPECIFICALLY NOTED ON THE DOCUMENT. IT IS THE RESPONSIBILITY OF EACH PARTY TO REFER TO THE COMPLETE SET OF CONTRACT DRAWINGS AND SPECIFICATIONS AND NOTED A PARTIAL OR INCOMPLETE SET OF DOCUMENTS.

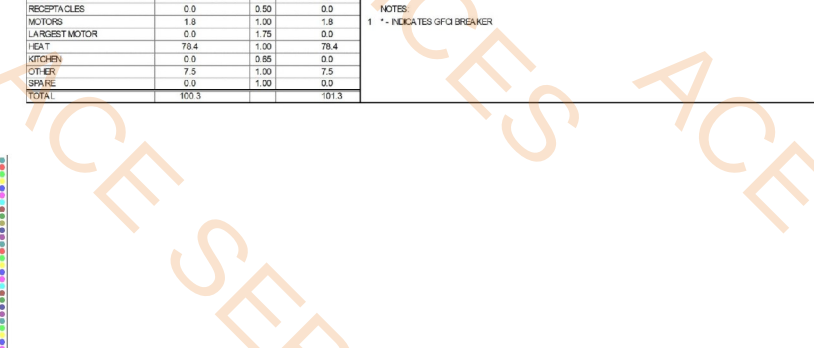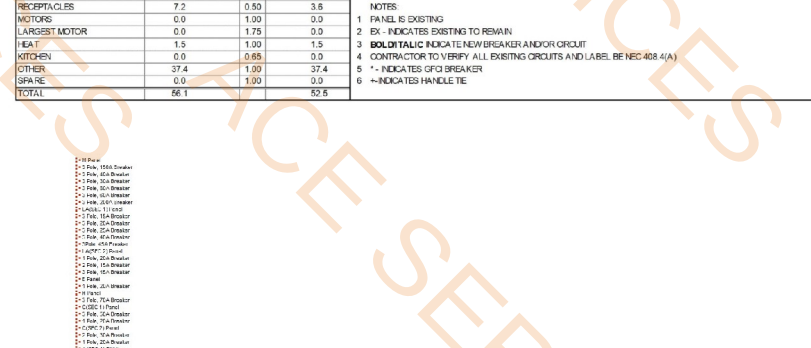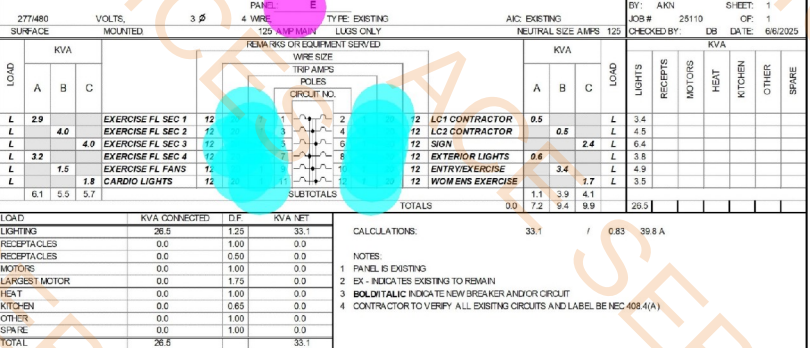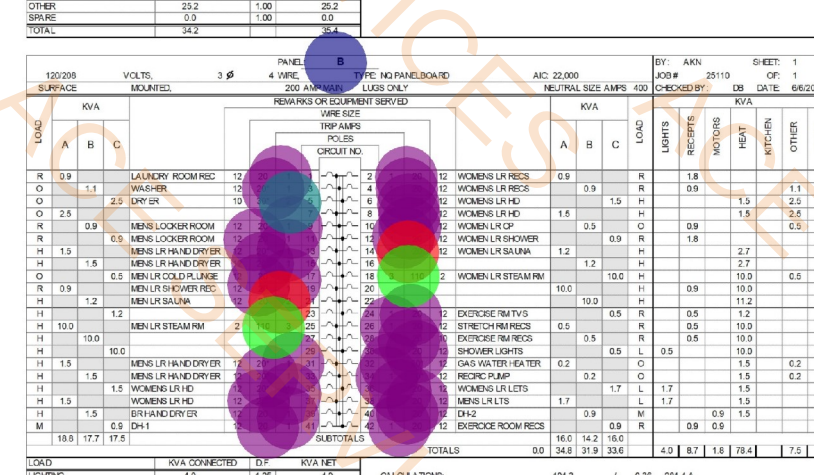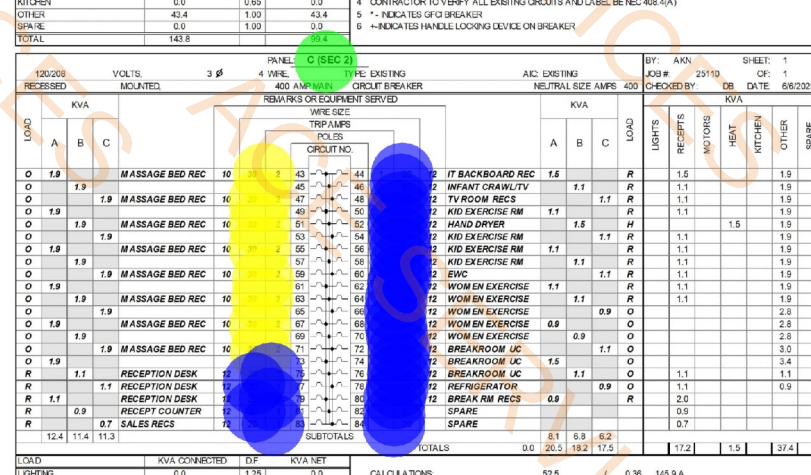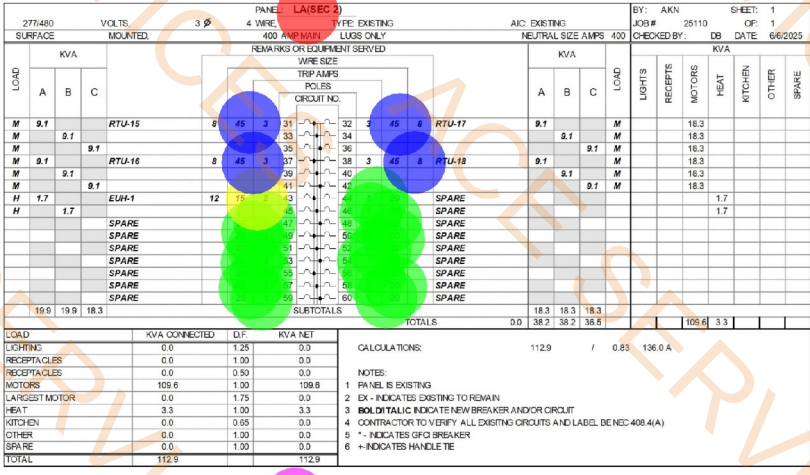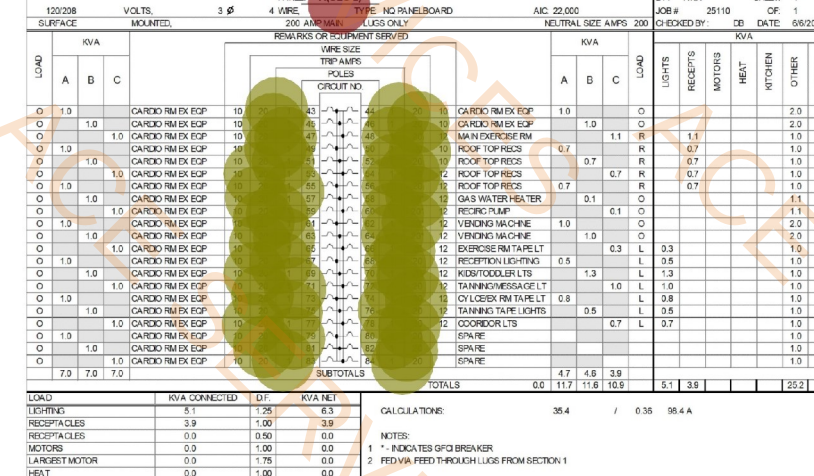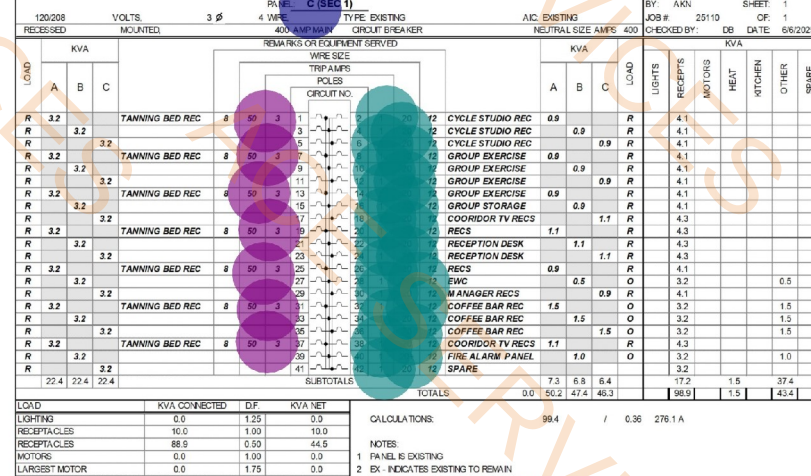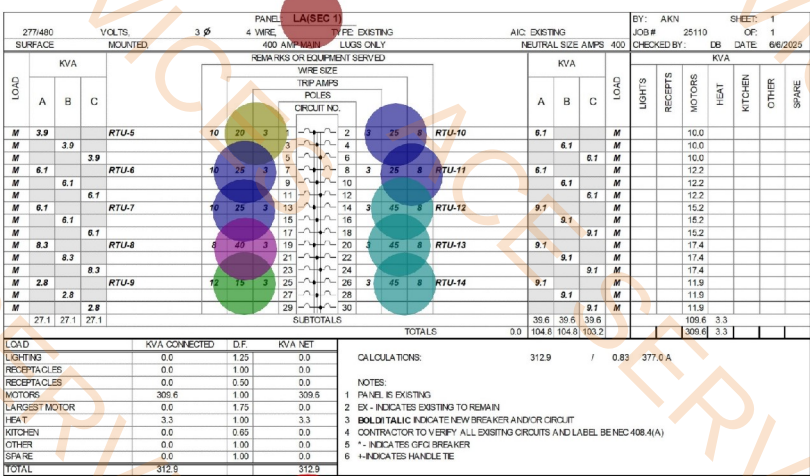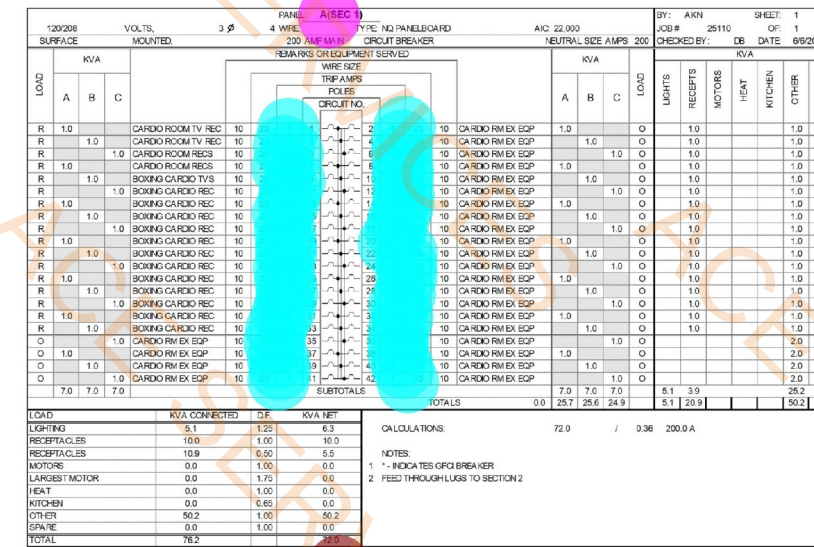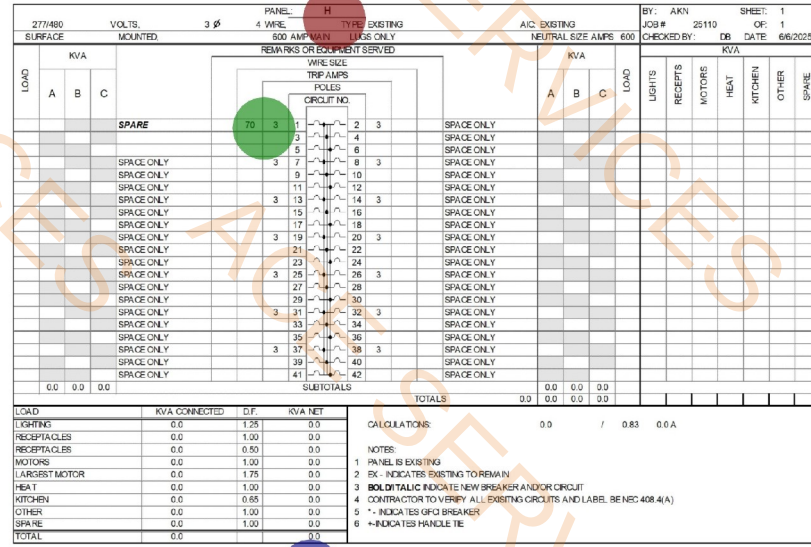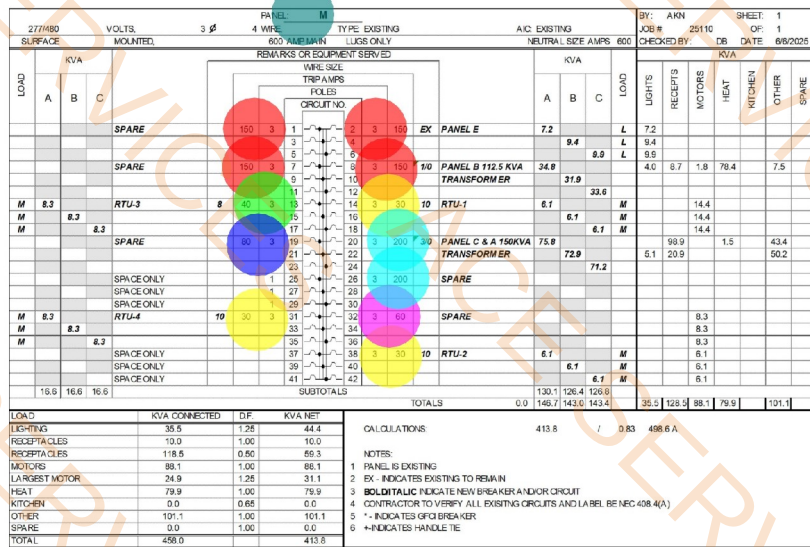

NOTE: THE CONTRACT DRAWINGS ARE NOT ORGANIZED SPECIFICALLY FOR ANY CRAFT, TRADE, DISCIPLINE, OR SUBCONTRACT. THEREFORE, ADDITIONAL RELATED INFORMATION MAY BE INCLUDED IN OTHER CONTRACT DRAWINGS AND SPECIFICATIONS AND NOT BE A PARTIAL OR INCOMPLETE SET OF DOCUMENTS.

Brent Barron Architect

11400 WOODHILL DR. WOODBRIDGE, VA 22191

709 Calabazas St.
Belmont, NC 28012
P: (704) 399-3943
www.allied-engineers.com
ALLIED #25110

6-05-25
Texas Registered Firm
F-13463

EDWIN D. BELLY
105415
LICENSED
ELECTRICIAN

20250321

PANEL SCHEDULES
CLUB 4 FITNESS - EL PASO MONTWOOD

FOR CONSTRUCTION
June 5, 2025

E0.3

- 2.0 EA
142.0 EA
9.0 EA
11.0 EA
6.0 EA
5.0 EA
13.0 EA
1.0 EA
11.0 EA



 
1/ SCALE: $3/32'' = 1'-0''$

GENERAL NOTE:

1. ALL EMERGENCY LIGHTS, EXIT SIGNS AND NIGHT LIGHTS (NL) ARE TO BE CONNECTED TO LOCAL CIRCUIT AHEAD OF ALL CONTROLS. NL ARE TO BE RUN CONTINUALLY.
2. REFER TO 5/E/2 FOR TIME CONTROL DETAILS.
3. ALL EXISTING INTERIOR LIGHT FIXTURES AND CONTROLS ARE TO BE REMOVED DURING DEMO PHASE, UNLESS NOTED OTHERWISE.
4. CONTRACTOR SHALL EXAMINE THE ARCHITECTURAL DRAWINGS FOR ADDITIONAL DETAILS ON LIGHTING AND LIGHTING CONTROLS.

KEY NOTES:


1. LOCATION OF MAIN EXERCISE ROOM SWITCH BANK.
2. CONNECT STRETCH ROOM LIGHTS AND FANS TO CIRCUIT E-1.
3. EXTEND LIGHTING AND CONTROLS CIRCUIT TO CORRIDOR/ENTRY LIGHTS AS SHOWN ON 1/E1.3
4. JUNCTION BOX AND CIRCUIT FOR FUTURE EXTERIOR AND/OR INTERIOR BUILDING SIGNS. VERIFY EXACT LOCATION AND ORIENTATION PRIOR TO POUR-IN. PROVIDE ADDITIONAL JUNCTION BOXES AS NEEDED FOR SIGN CONNECTIONS. THIS CIRCUIT WILL BE CONTROLLED VIA TIME CLOCK (LC2) IN THE LCP/BMS.



NOTE: THE CONTRACT DRAWINGS ARE NOT ORGANIZED SPECIFICALLY FOR ANY CRAFT, TRADE, DISCIPLINE, OR SUBCONTRACT. THEREFORE, ADDITIONAL RELATED INFORMATION MAY BE INCLUDED IN OTHER CONTRACT DRAWINGS AND SPECIFICATIONS EVEN THOUGH NOT SPECIFICALLY NOTED ON THIS DOCUMENT. IT IS THE RESPONSIBILITY OF EACH PARTY TO REFER TO THE COMPLETE SET OF CONTRACT DRAWINGS AND SPECIFICATIONS, AND NOT TO A PARTIAL OR INCOMPLETE SET OF DOCUMENTS.

P 601.750.1778
114 WOODY HILLS DR, MADISON, MS 39110

 709 Catawba St.
Belmont, NC 28012
P: (704) 399-3943
www.allied-engineers.com
ALLIED #25110




1705 MONTWOOD DR, EL PASO, TX 79936

20250321

FOR CONSTRUCTION
June 5, 2025

E1.1

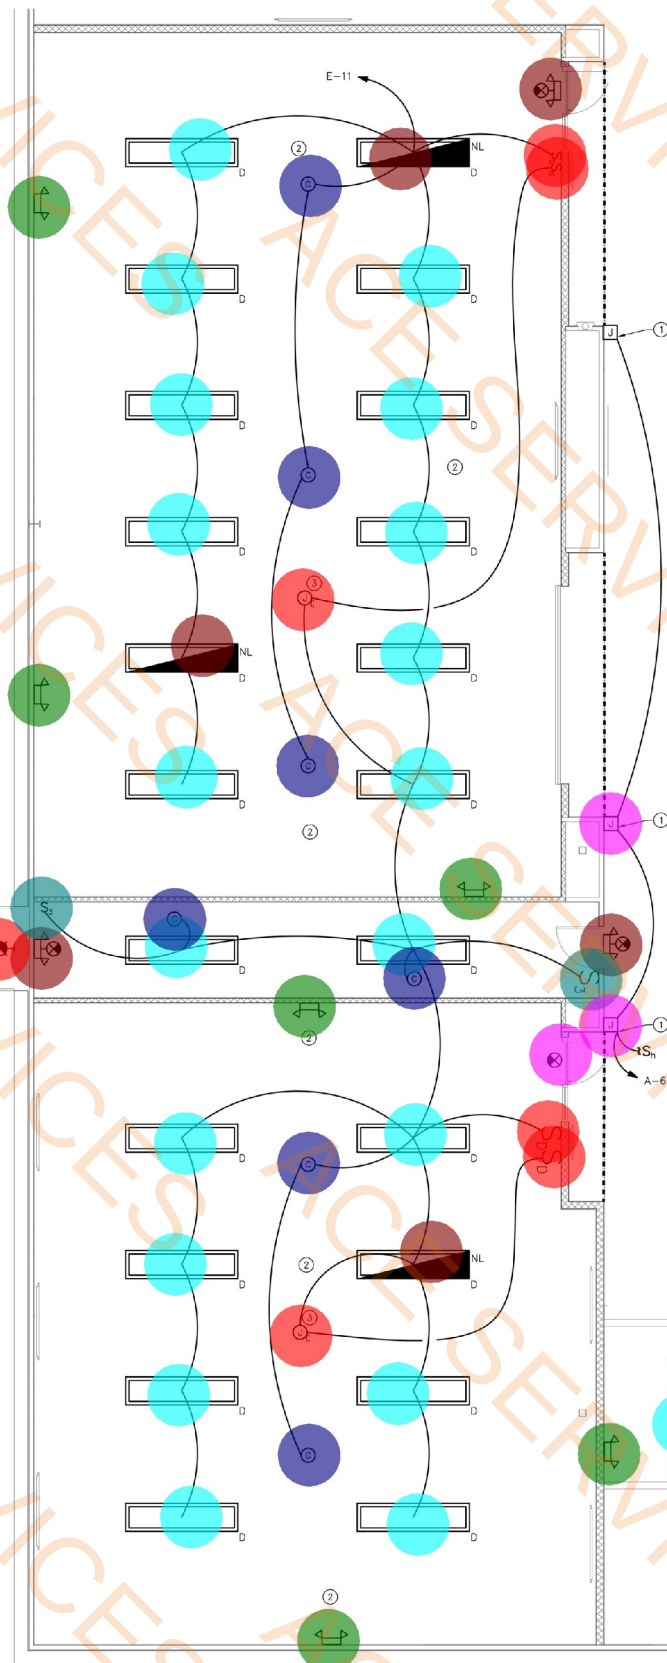

1 ENLARGED CARDO PLAN - LIGHTING
E1.2 SCALE: 3/16" = 1'-0"

- 6" Aperture Recessed Led Downlight, ALZAK Reflector
 - 8Ft Lowbay Surface Strip Led With Frost Lens, White Finish Typical, Black Finish When Specified
 - 8Ft Lowbay Surface Strip Led With Frost Lens, White Finish Typical, Black Finish When Specified W/Emergency Bz
 - Large Exercise Room Fan
 - Universal Mounted Combo Emergency/Exit Led Light With Polycarbonate Housing With Contained Powerpack For 90 Min. Operation, L
 - Ceiling Mounted Combo Emergency/Exit Led Light With Polycarbonate Housing With Contained Powerpack For 90 Min. Operation, L
 - Wall Or Ceiling Mounted Emergency Led Light With Polycarbonate Housing With Contained Powerpack For 90 Min. Operation, L
 - Universal Mounted Led Exit Light With Polycarbonate Housing With Contained Powerpack For 90 Min. Operation, L
 - Sensor Switch Or equal.
 - Three Pole Switch
 - Dimmer Switch
 - Ceiling Mounted Junction Box
 - GFCI Wall Mounted Junction Box
 - Wall Mounted Junction Box
 - Remote Head Feed From Combo
- | | | | | | | | | | | | | | | |
|--------|---------|--------|--------|--------|--------|--------|--------|--------|--------|--------|--------|--------|--------|--------|
| 0.0 EA | 43.0 EA | 6.0 EA | 1.0 EA | 4.0 EA | 2.0 EA | 9.0 EA | 1.0 EA | 7.0 EA | 2.0 EA | 4.0 EA | 3.0 EA | 0.0 EA | 2.0 EA | 1.0 EA |
|--------|---------|--------|--------|--------|--------|--------|--------|--------|--------|--------|--------|--------|--------|--------|

GENERAL NOTES:


1. ALL EMERGENCY LIGHTS, EXIT SIGNS AND NIGHT LIGHTS (NL) ARE TO BE CONNECTED TO LOCAL CIRCUIT AHEAD OF ALL CONTROLS. NL ARE TO BE RUN CONTINUALLY.
2. REFER TO 5/E0.2 FOR TIME CLOCK CONTROLS DETAIL.
3. ALL POWER OUTLETS, SWITCHES, AND COVER PLATES IN CEREMONY AND BOXING ROOMS SHALL BE BLACK.
4. ALL EXISTING INTERIOR LIGHT FIXTURES AND CONTROLS ARE TO BE REMOVED DURING DEMO PHASE, UNLESS NOTED OTHERWISE.
5. REFER TO 2/E1.1 FOR SWITCH BANK DETAILS.
6. REFER TO 1/E1.1 FOR LOCATION OF SWITCH BANK.
7. CONTRACTOR SHALL EXAMINE THE ARCHITECTURAL DRAWINGS FOR ADDITIONAL DETAILS ON LIGHTING AND LIGHTING CONTROLS.

SPECIAL LIGHTING NOTES:

1. REGARDING THE SWITCH BANK CONTROLS FOR MANUAL LOCAL OVERRIDE LIGHTING CONTROL, PROVIDE MULTIPLE GANG BOXES, AS REQUIRED, AT THE SWITCH BANK LOCATION. LABEL EACH SWITCH ACCORDING TO THE LIGHTING ZONE CONTROLLED. VERIFY EXACT MOUNTING LOCATION, LABELING AND SWITCHING WITH THE OWNER PRIOR TO ROUGH-IN.
2. LOWER CASE LETTERING ADJACENT TO LIGHTING SWITCHES AND LIGHTING FIXTURES DESIGNATE WHICH FIXTURES ARE TO BE CONTROLLED BY A BMS/LCS LOW VOLTAGE MANUAL OVERRIDE DEVICE. THESE LOW VOLTAGE CIRCUIT CONNECTIONS ARE SHOWN FOR DESIGN INTENT PURPOSES ONLY, AND CAN BE MODIFIED BY THE CURRENTLY AVAILABLE ELECTRONIC CONTROL BANKS. THE ELECTRICAL CONTRACTOR SHALL PROVIDE ALL EQUIPMENT AND WIRING NECESSARY TO PROVIDE A COMPLETE AND OPERABLE BMS SYSTEM.
3. ALL SWITCHES FOR LIGHTING IN THE EXERCISE AREAS SHALL BE PROVIDED IN LOCKABLE ENCLOSURES TO PREVENT UNINTENTIONAL MANUAL SHUTOFF WHICH WOULD ENDANGER THE SAFETY OF PATRONS. THE ELECTRICAL CONTRACTOR SHALL COORDINATE EXACT ENCLOSURE DETAILS AND MOUNTING LOCATIONS WITH THE ARCHITECT AND OWNER PRIOR TO ROUGH-IN.

KEY NOTES:

1. RGBW LED TAPE LIGHT, 4.6W/FT, USE PRISM LIGHTING: CAT-PZM-TLH-54-24V-RGBW-16. PROVIDE THE NECESSARY QUANTITY OF DRIVERS, DIMM CONTROLLERS, AND ACCESSORIES AS REQUIRED FOR A COMPLETE WORKING SYSTEM. SEE ARCHITECTURAL DRAWINGS FOR EXACT PLACEMENT OF TAPE LIGHT. LIGHTS ARE 120V AND SHOULD BE POWERED FROM, AND SWITCHED WITH, THE APPROPRIATE LIGHTING CIRCUIT AS SHOWN. JUNCTION BOX AND CONNECTIONS ARE TO BE CONCEALED ABOVE CEILING.
2. EMERGENCY LIGHT/EXIT SIGN AND NORMAL EGRESS LIGHTING IS TO HAVE BLACK HOUSING AND FINISHES IN THIS SPACE.
3. PROVIDE CEILING MOUNTED JUNCTION BOX FOR CONNECTION TO FUTURE FIXTURE. CONNECT TO LOCAL LIGHTING LIGHTING CIRCUIT AS SHOWN AND SWITCHING. COORDINATE WITH OWNER EXACT LOCATION PRIOR TO ROUGH-IN. NO LOAD ADDED.

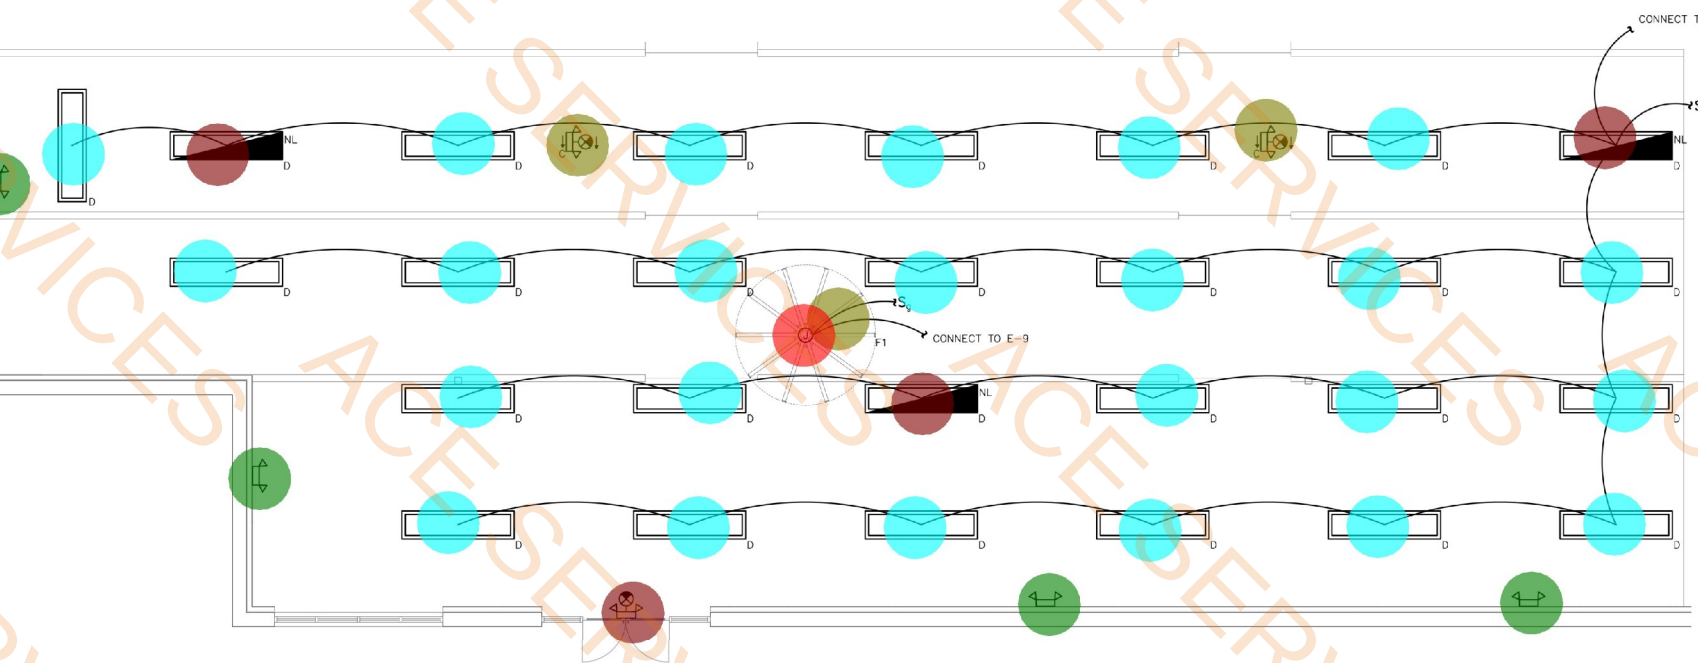

NOTE: THE CONTRACT DRAWINGS ARE NOT ORGANIZED SPECIFICALLY FOR ANY CRAFT, TRADE, DISCIPLINE, OR SUBCONTRACT. THEREFORE, ADDITIONAL RELATED INFORMATION MAY BE INCLUDED IN OTHER CONTRACT DRAWINGS AND SPECIFICATIONS EVEN THOUGH NOT SPECIFICALLY NOTED ON THIS DOCUMENT. IT IS THE RESPONSIBILITY OF EACH PARTY TO REFER TO THE COMPLETE SET OF CONTRACT DRAWINGS AND SPECIFICATIONS, AND NOT TO A PARTIAL OR INCOMPLETE SET OF DOCUMENTS.

ENLARGED CARDO PLAN - LIGHTING
CLUB 4 FITNESS - EL PASO MONTWOOD
11705 MONTWOOD DR, EL PASO, TX 79936
20250321

FOR CONSTRUCTION
June 5, 2025


E1.2

ALLIED
CONSULTING ENGINEERS

709 Calawaba St.
Belmont, NC 28012
P: (704) 359-3943
www.allied-engineers.com
ALLIED #25110

STATE OF TEXAS
EDWIN D. BELLY
105415
LICENSED PROFESSIONAL ENGINEER
6-05-25
Texas Registered Firm
F-13463

Brent Barron Architect
P 6 0 1 . 7 5 0 . 1 7 7 8
1 4 WOODY HILLS DR, MADISON, MS 39110

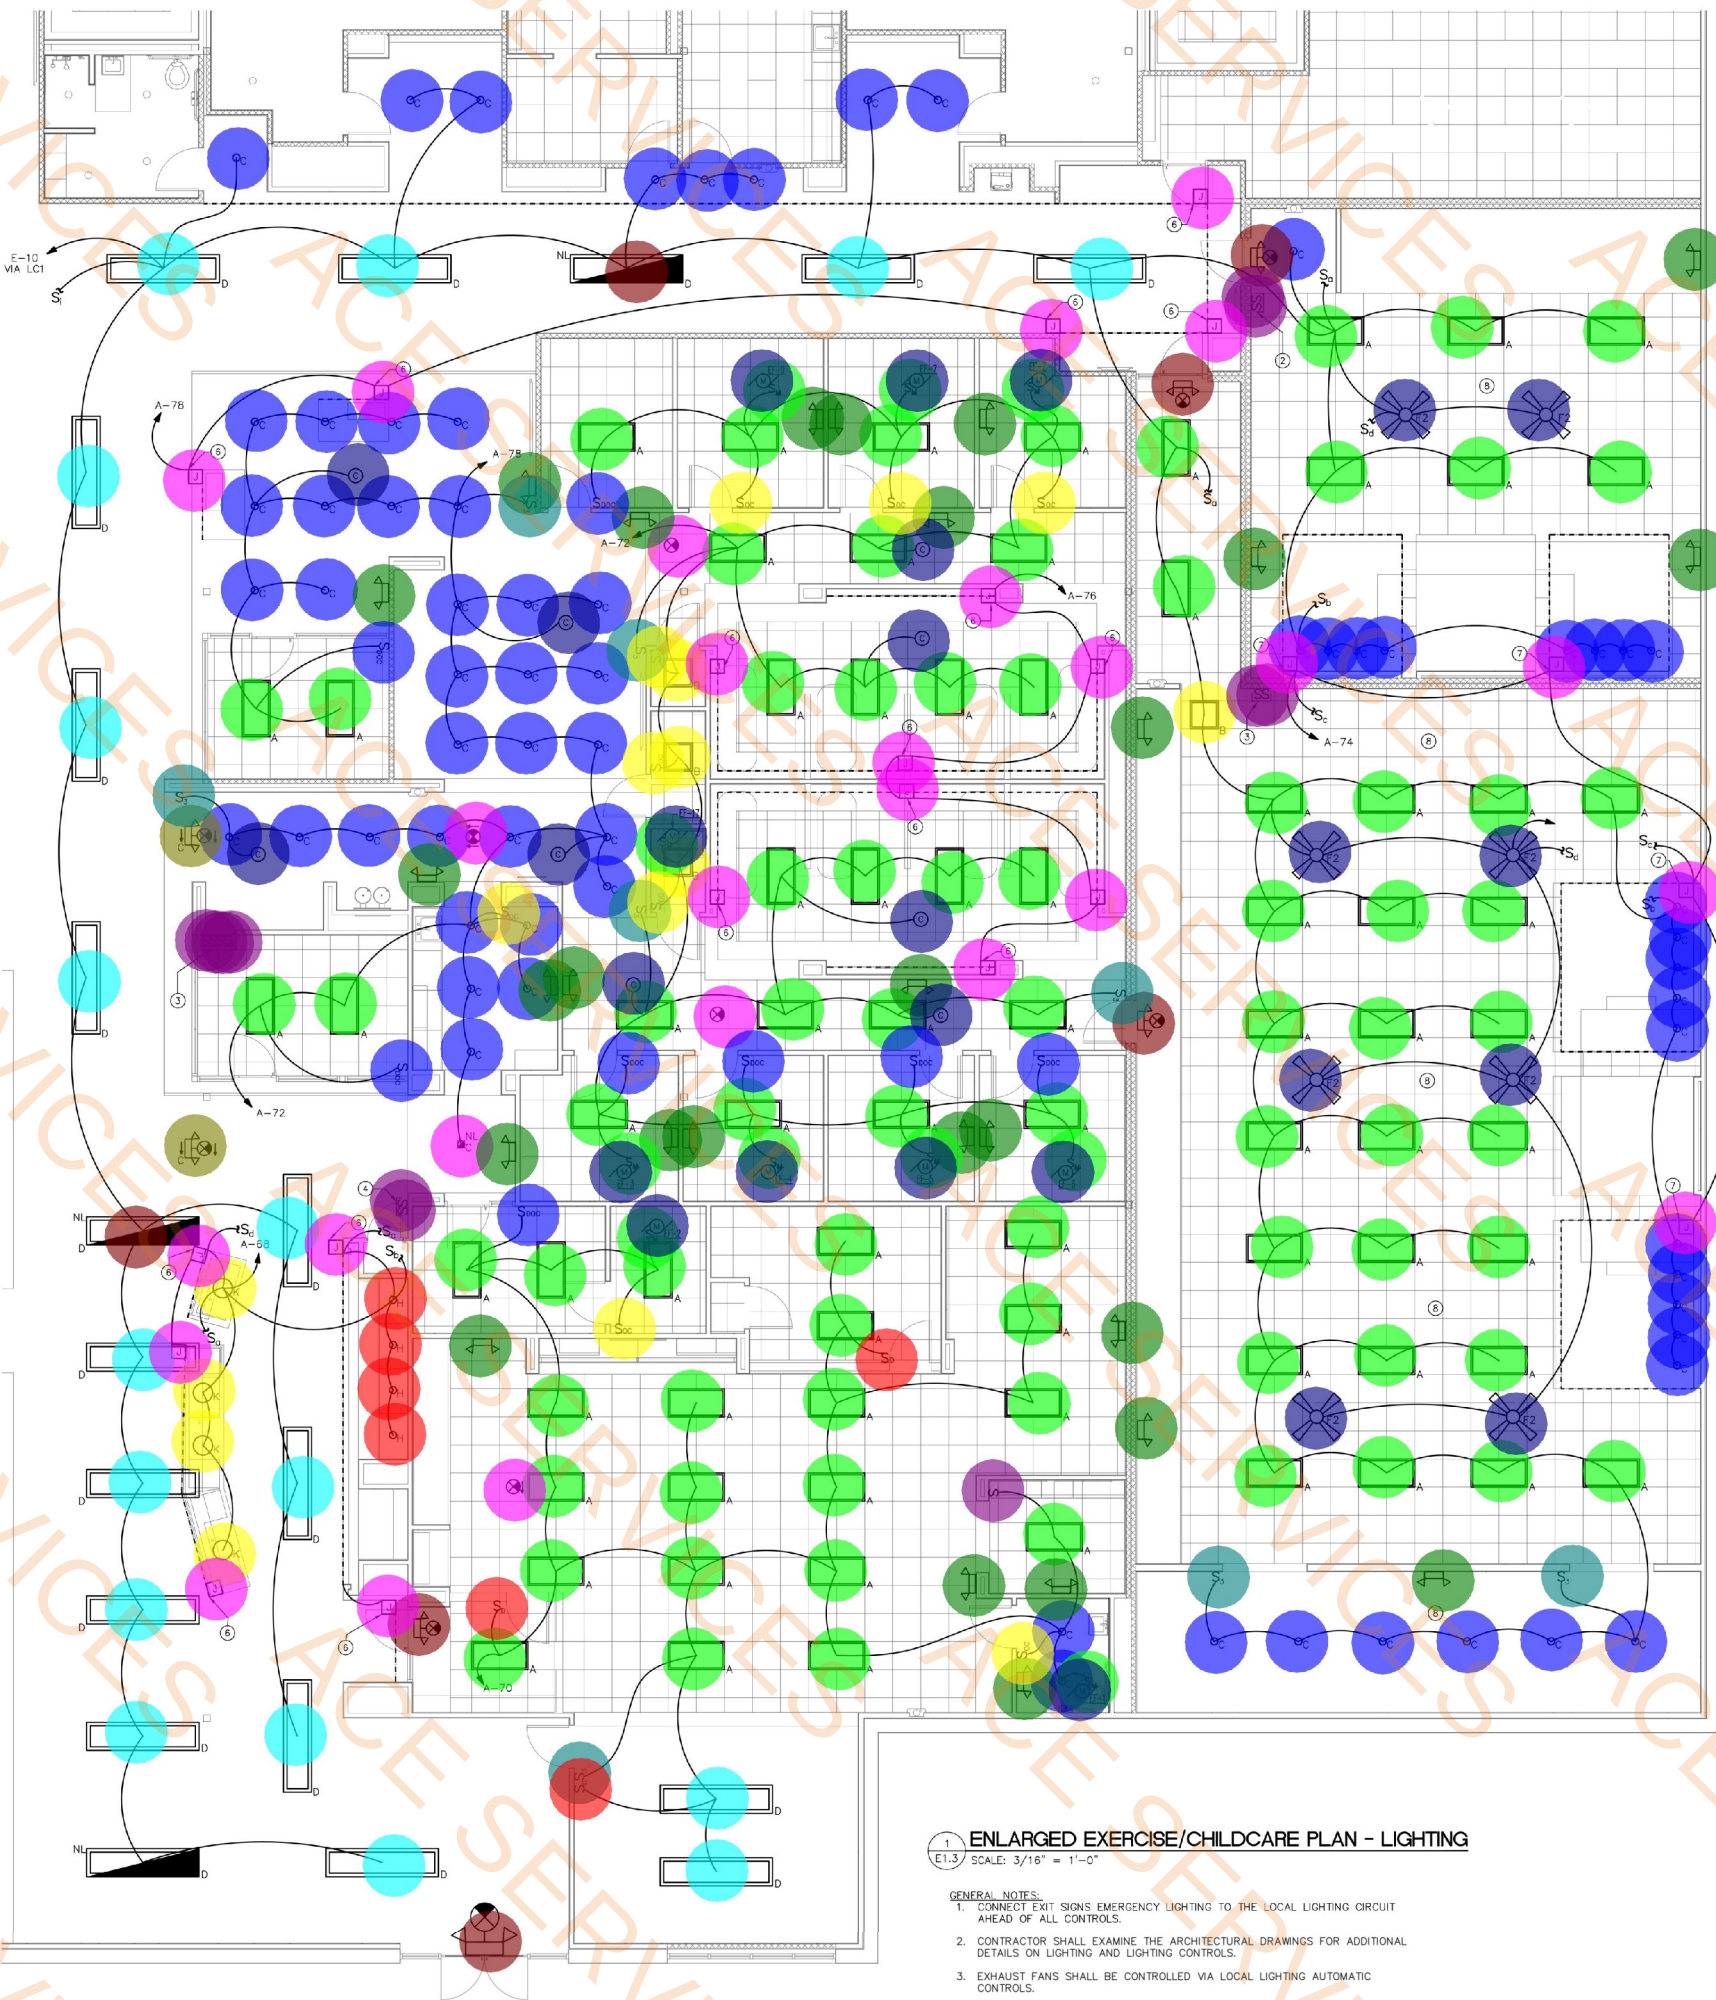

1 ENLARGED EXERCISE/CHILDCARE PLAN - LIGHTING

E1.3 SCALE: 3/16" = 1'-0"


- GENERAL NOTES:
1. CONNECT EXIT SIGNS EMERGENCY LIGHTING TO THE LOCAL LIGHTING CIRCUIT AHEAD OF ALL CONTROLS.
 2. CONTRACTOR SHALL EXAMINE THE ARCHITECTURAL DRAWINGS FOR ADDITIONAL DETAILS ON LIGHTING AND LIGHTING CONTROLS.
 3. EXHAUST FANS SHALL BE CONTROLLED VIA LOCAL LIGHTING AUTOMATIC CONTROLS.

NOTE: THE CONTRACT DRAWINGS ARE NOT ORGANIZED SPECIFICALLY FOR ANY CRAFT, TRADE, DISCIPLINE, OR SUBCONTRACT. THEREFORE, ADDITIONAL RELATED INFORMATION MAY BE INCLUDED IN OTHER CONTRACT DRAWINGS AND SPECIFICATIONS EVEN THOUGH NOT SPECIFICALLY NOTED ON THIS DOCUMENT. IT IS THE RESPONSIBILITY OF EACH PARTY TO REFER TO THE COMPLETE SET OF CONTRACT DRAWINGS AND SPECIFICATIONS, AND NOT TO A PARTIAL OR INCOMPLETE SET OF DOCUMENTS.

- 2x4 Recessed Led Flat Panel 79.0 EA
- 2x2 Recessed Led Flat Panel - Type: B - Color Temp/Lumens: LED4000K 3740 Lumens - Volts: 120/277 - Watts: 28... 40 EA
- 6" Aperture Recessed Led Downlight, ALZAK Reflector 66.0 EA
- 6" Aperture Recessed Led Downlight, ALZAK Reflector W/Emergency Backup - Night Lights Are Connected Ahead... 1.0 EA
- 8F1 Lowbay Surface Strip Led With Frost Lens, White Finish Typical, Black Finish When Specified 17.0 EA
- 8F1 Lowbay Surface Strip Led With Frost Lens, White Finish Typical, Black Finish When Specified W/Emergency B... 8.0 EA
- Medium Exercise Room Fan 4.0 EA
- 4" Adjustable Led Downlight With Selectable Lumens - Type: H - Color Temp/Lumens: LED4000K 729 Lumens - Volt... 4.0 EA
- Led Decorative Pendant, 40" Diameter, 3-ARM, Bright Satin Aluminum Finish, Bottom Of Fixture 4.0 EA
- Wall Or Ceiling Mounted Emergency Led Light With Polycarbonate Housing With Contained Powerpack For 90 Min. C27.0 EA
- Ceiling Mounted Combo Emergency/Exit Led Light With Polycarbonate Housing With Contained Powerpack For 90... 2.0 EA
- Universal Mounted Combo Emergency/Exit Led Light With Polycarbonate Housing With Contained Powerpack For 90... 4.0 EA
- Universal Mounted Led Exit Light With Polycarbonate Housing With Contained Powerpack For 90 Min. Operation, L... 4.0 EA
- Remote Head Feed From Combo 0.0 EA
- Sensor Switch Or Equal - Ceiling Mounted Dual Technology Occupancy Manual Via Wall Switch Auto Off-30Min. Ti... 9.0 EA
- Single Pole Switch 11.0 EA
- Three Pole Switch 8.0 EA
- Dimmer Switch - 1200W - 120 V - Mfr. LUTRON NT-Series - Provide Double Gang J-Box For Dimmers 1600W And A... 10.0 EA
- Fractional Horsepower Manual Motor Starter Switch With O.L.S 9.0 EA
- Sensor Switch Or Equal - Wall Mounted Dual Technology Occupancy - Manual On-Auto Off-30Min. Timeout 8.0 EA
- Sensor Switch Or Equal 22.0 EA
- Wall Mounted Junction Box 10.0 EA
- Fractional Horsepower Motor Connection

4 RECEPTION DESK SWITCH BANK


E1.3 NO SCALE

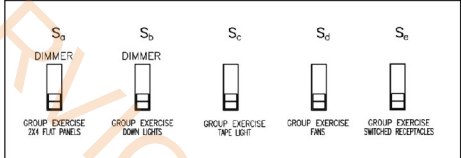

DIMMER SWITCHES WILL BE INDICATED ABOVE. COORDINATE DIMMER REQUIREMENTS WITH THE FIXTURE PACKAGE PRIOR TO ROUGH-IN.

3 GROUP EXERCISE SWITCH BANK DETAIL

E1.3 NO SCALE

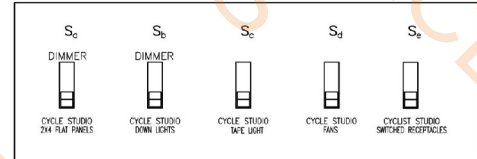

DIMMER SWITCHES WILL BE INDICATED ABOVE. COORDINATE DIMMER REQUIREMENTS WITH THE FIXTURE PACKAGE PRIOR TO ROUGH-IN.

2 CYCLE STUDIO SWITCH BANK DETAIL


E1.3 NO SCALE

- KEY NOTES:
1. LOCATION OF MAIN EXERCISE ROOM SWITCH BANK, REFER TO 2/E1.1 FOR DETAILS.
 2. LOCATION OF CYCLE STUDIO ROOM SWITCH BANK, REFER TO 2/E1.3 FOR DETAILS.
 3. LOCATION OF GROUP EXERCISE ROOM SWITCH BANK, REFER TO 3/E1.3 FOR DETAILS.
 4. LOCATION OF RECEPTION AREA SWITCH BANK, REFER TO 4/E1.3 FOR DETAILS.
 5. JUNCTION BOX AND CIRCUIT FOR FUTURE EXTERIOR AND/OR INTERIOR BUILDING SIGNS. VERIFY EXACT LOCATION AND ORIENTATION PRIOR TO ROUGH-IN. PROVIDE ADDITIONAL JUNCTION BOXES AS NEEDED FOR SIGN CONNECTIONS. THIS CIRCUIT TO BE CONTROLLED VIA TIME CLOCK (LC2) IN THE LPT/EMS. JUNCTION BOX AND CONNECTIONS ARE TO BE CONCEALED ABOVE CEILING.
 6. RGBW LED TAPE LIGHT, 4.6W/FT, USE PRIZM LIGHTING: CAT#P2M-TL1-54-24V-RGBW-16. PROVIDE THE NECESSARY QUANTITY OF DRIVERS, DMX CONTROLLERS, AND ACCESSORIES AS REQUIRED FOR A COMPLETE WORKING SYSTEM. SEE ARCHITECTURAL DRAWINGS FOR EXACT PLACEMENT OF TAPE LIGHT. LIGHTS ARE 120V AND SHOULD BE POWERED FROM, AND SWITCHED WITH, THE APPROPRIATE LIGHTING CIRCUIT AS SHOWN. COORDINATE WITH OWNER ON DESIRED LOCATION OF LIGHTING CONTROL SWITCH PRIOR TO ROUGH-IN. JUNCTION BOX AND CONNECTIONS ARE TO BE CONCEALED ABOVE CEILING.
 7. PROVIDE PRIZM LIGHTING NEOLUX L-SERIES SIDE BEND ROF FLEXIBLE LED, 91 LUMENS/FT, CAT#P2M-NFL-XFT-RGB. PROVIDE ALL NECESSARY DRIVERS, DMX CONTROLLERS, AND ACCESSORIES REQUIRED FOR A COMPLETE WORKING SYSTEM. COORDINATE ALL LENGTHS AND PATTERNS WITH THE ARCHITECT AND GC PRIOR TO INSTALLATION. THIS NOTE TYPICAL FOR ALL LIGHT STRIPS SHOWN IN CYCLE STUDIO AND GROUP EXERCISE ROOMS. ALL TRANSFORMERS, WIRING, CONNECTORS, ETC. ARE TO BE HIDDEN ABOVE THE CEILING FOR A CLEAN INSTALLATION.
 8. ALL EMERGENCY LIGHT/EXIT SIGN, NORMAL EGRESS LIGHTING, SWITCHES, AND COVER PLATES ARE TO HAVE BLACK FINISHES IN THIS SPACE. RECESS LAY-IN FIXTURES ARE TO HAVE BLACK TRIM.

SPECIAL LIGHTING NOTES:

1. REGARDING THE SWITCH BANK CONTROLS FOR MANUAL LOCAL OVERRIDE LIGHTING CONTROL, PROVIDE MULTIPLE GANG BOXES, AS REQUIRED, AT THE SWITCH BANK LOCATION. LABEL EACH SWITCH ACCORDING TO THE LIGHTING ZONE CONTROLLED. VERIFY EXACT MOUNTING LOCATION AND LABELING WITH THE OWNER PRIOR TO ROUGH-IN.
2. LOWER CASE LETTERING ADJACENT TO LIGHTING SWITCHES AND LIGHTING FIXTURES DESIGNATE WHICH FIXTURES ARE TO BE CONTROLLED BY A BMS/LCS LOW VOLTAGE MANUAL OVERRIDE DEVICE. THESE LOW VOLTAGE CIRCUIT CONNECTIONS ARE SHOWN FOR DESIGN INTENT PURPOSES ONLY, AND CAN BE MODIFIED BY THE CURRENTLY AVAILABLE ELECTRONIC CONTROL BANKS. THE ELECTRICAL CONTRACTOR SHALL PROVIDE ALL EQUIPMENT AND WIRING NECESSARY TO PROVIDE A COMPLETE AND OPERABLE BMS SYSTEM.
3. ALL SWITCHES FOR LIGHTING IN THE EXERCISE AREAS SHALL BE PROVIDED IN LOCKABLE ENCLOSURES TO PREVENT UNINTENTIONAL MANUAL SHUTOFF WHICH WOULD ENDANGER THE SAFETY OF PATRONS. THE ELECTRICAL CONTRACTOR SHALL COORDINATE EXACT ENCLOSURE DETAILS AND MOUNTING LOCATIONS WITH THE ARCHITECT AND OWNER PRIOR TO ROUGH-IN.

ALLIED
CONSULTING ENGINEERS
709 Calatuba St.
Belmont, NC 28012
P: (704) 399-3943
www.allied-engineers.com
ALLIED #25110

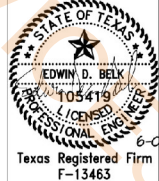


ENLARGED EXERCISE/CHILDCARE PLAN - LIGHTING
CLUB 4 FITNESS - EL PASO MONTWOOD
11705 MONTWOOD DR, EL PASO, TX 79936
20250321

FOR CONSTRUCTION
June 5, 2025

E1.3

- 2x4 Recessed Led Flat Panel
- 6" Aperature Recessed Led Downlight. ALZAK Reflector
- 8Ft Lowbay Surface Strip Led With Frost Lens. White Finish Typical, Black Finish When Specified
- Medium Exercise Room Fan
- 96" Above Mirror Led Light, Bright Satin Aluminum Finish, Damp Rated
- 6" Shower/Steam Room Rated led Downlight
- Universal Mounted Combo Emergency/Exit Led Light With Polycarbonate Housing With Contained Powerpack For 90 Min. Operation, Lead Calcium Battery, White Housing Typical, Black Housing When Specified
- Wall Or Ceiling Mounted Emergency Led Light With Polycarbonate Housing With Contained Powerpack For 90 Min. Operation, Lead Calcium Battery, White Housing Typical, Black Housing When Specified In Exercise Room,
- Universal Mounted Led Exit Light With Polycarbonate Housing With Contained Powerpack For 90 Min. Operation, Lead Calcium Battery, White Housing Typical, Black Housing When Specified In Exercise Room,
- Remote Head Feed From Combo
- Sensor Switch Or equal.
- Single Pole Switch
- Dimmer Switch
- Sensor Switch Or Equal.
- Sensor Switch Or Equal.
- Fractional Horsepower Manual Motor Starter Switch With O.L.'S
- Weatherproof Fractional Horsepower Manual Motor Starter Switch With O.L.'S
- GFCI Wall Mounted Junction Box
- Wall Mounted Junction Box
- Fused Disconnect Switch
- Fractional Horsepower Motor Connection

- 43.0 EA
- 78.0 EA
- 4.0 EA
- 8.0 EA
- 6.0 EA
- 24.0 EA
- 8.0 EA
- 13.0 EA
- 16.0 EA
- 0.0 EA
- 20.0 EA
- 6.0 EA
- 1.0 EA
- 3.0 EA
- 5.0 EA
- 0.0 EA
- 2.0 EA
- 0.0 EA
- 6.0 EA
- 2.0 EA
- 5.0 EA

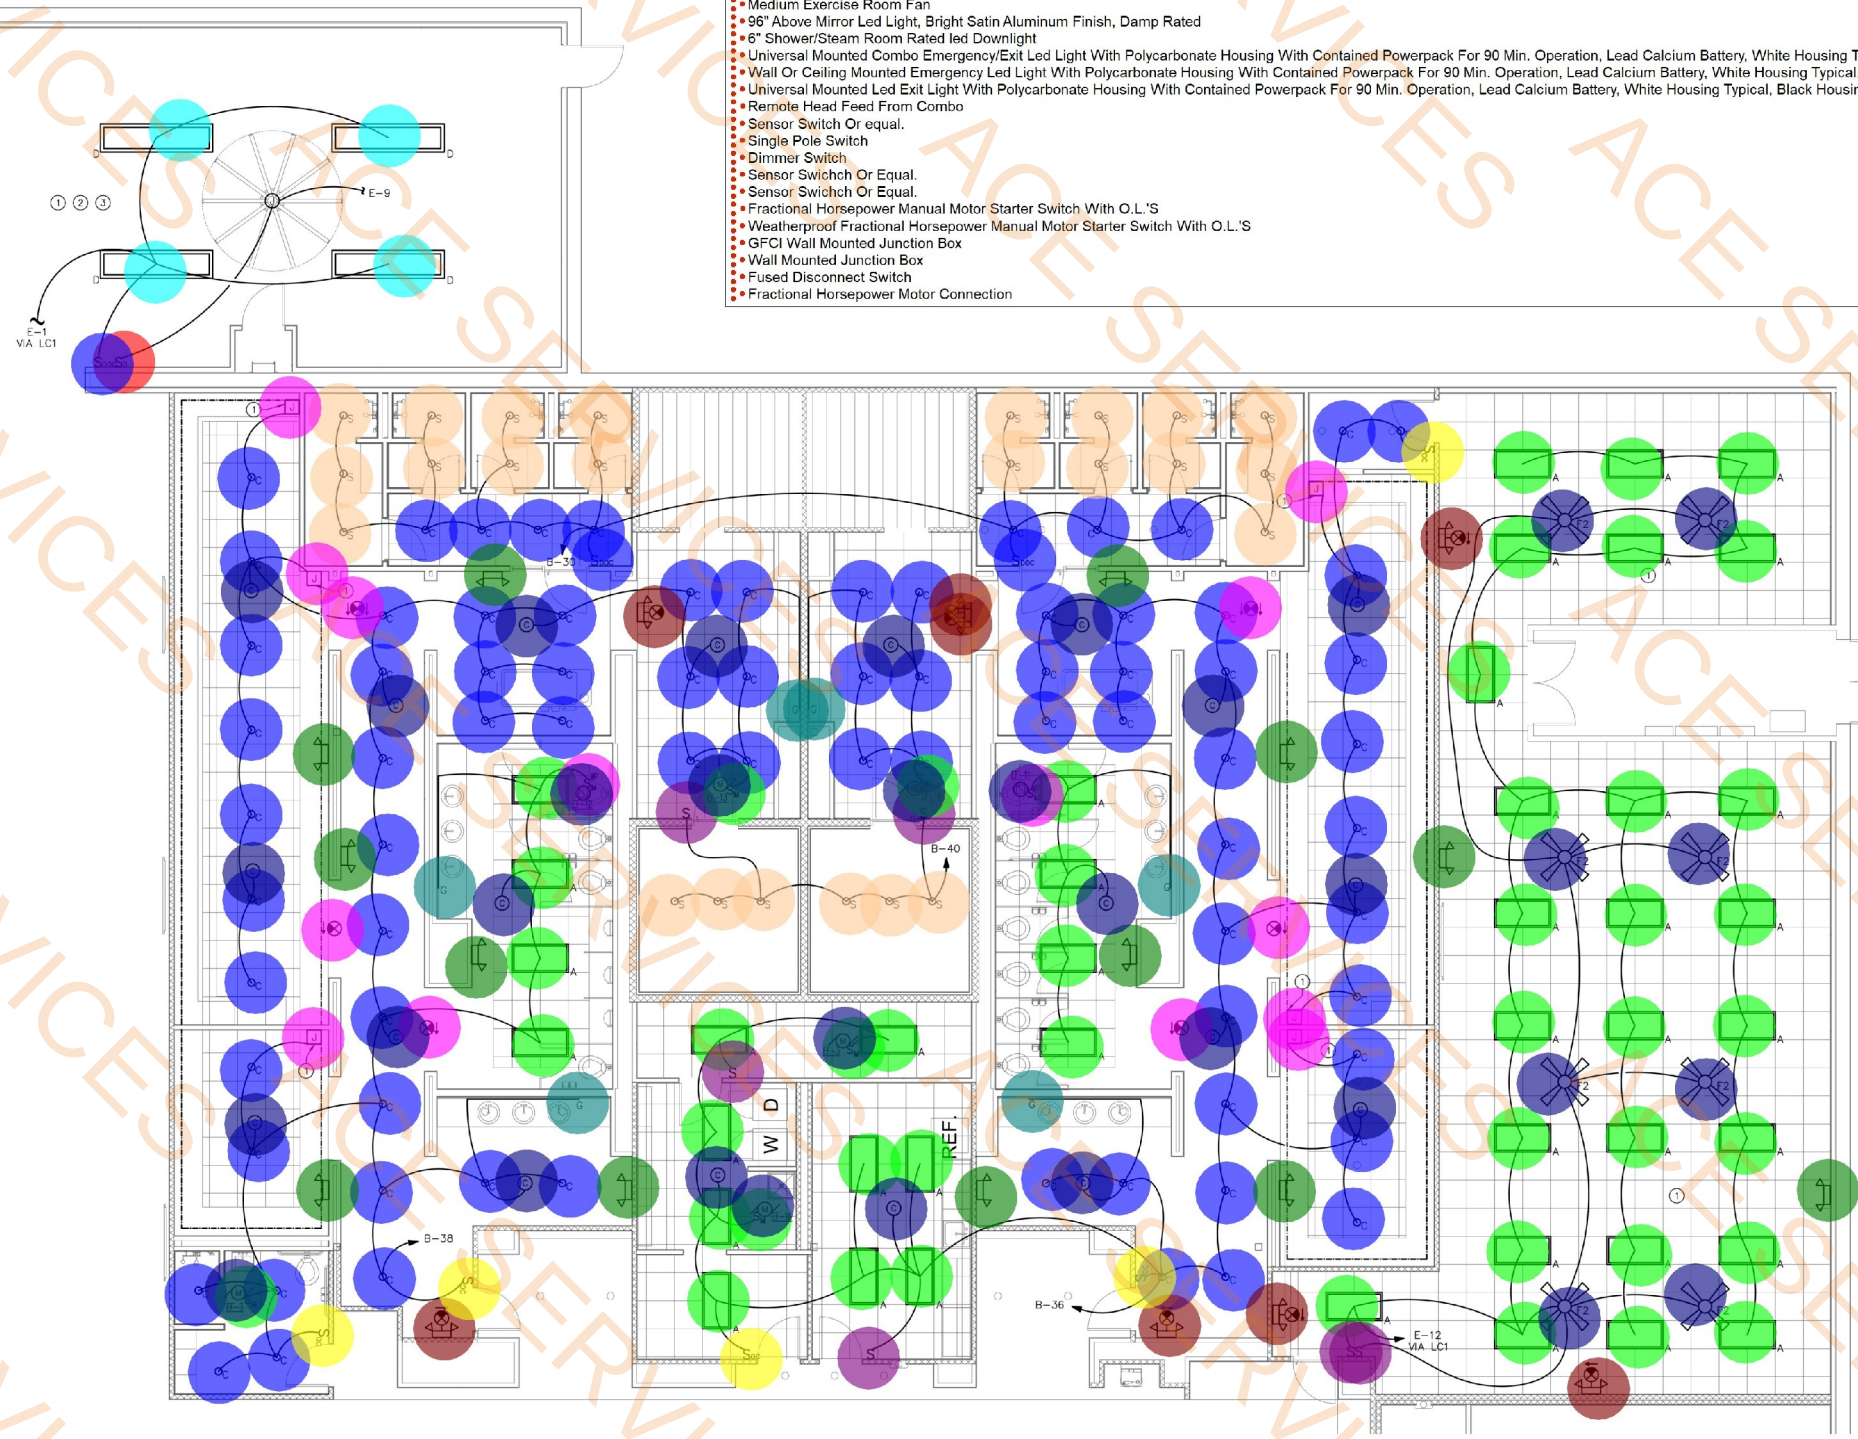

1 ENLARGED LOCKER ROOM PLAN - LIGHTING
E1.4 SCALE: 3/16" = 1'-0"

- GENERAL NOTES:**
1. CONNECT EXIT SIGNS EMERGENCY LIGHTING TO THE LOCAL LIGHTING CIRCUIT AHEAD OF ALL CONTROLS.
 2. CONTRACTOR SHALL EXAMINE THE ARCHITECTURAL DRAWINGS FOR ADDITIONAL DETAILS ON LIGHTING AND LIGHTING CONTROLS.
 3. EXHAUST FANS SHALL BE CONTROLLED VIA LOCAL LIGHTING AUTOMATIC CONTROLS.

- SPECIAL LIGHTING NOTES:**
1. REGARDING THE SWITCH BANK CONTROLS FOR MANUAL LOCAL OVERRIDE LIGHTING CONTROL, PROVIDE MULTIPLE GANG BOXES, AS REQUIRED, AT THE SWITCH BANK LOCATION. LABEL EACH SWITCH ACCORDING TO THE LIGHTING ZONE CONTROLLED. VERIFY EXACT MOUNTING LOCATION AND LABELING WITH THE OWNER PRIOR TO ROUGH-IN.
 2. LOWER CASE LETTERING ADJACENT TO LIGHTING SWITCHES AND LIGHTING FIXTURES DESIGNATE WHICH FIXTURES ARE TO BE CONTROLLED BY A BMS/LCS LOW VOLTAGE MANUAL OVERRIDE DEVICE. THESE LOW VOLTAGE CIRCUIT CONNECTIONS ARE SHOWN FOR DESIGN INTENT PURPOSES ONLY, AND CAN BE MODIFIED BY THE CURRENTLY AVAILABLE ELECTRONIC CONTROL BANKS. THE ELECTRICAL CONTRACTOR SHALL PROVIDE ALL EQUIPMENT AND WIRING NECESSARY TO PROVIDE A COMPLETE AND OPERABLE BMS SYSTEM.
 3. ALL SWITCHES FOR LIGHTING IN THE EXERCISE AREAS SHALL BE PROVIDED IN LOCKABLE ENCLOSURES TO PREVENT UNINTENTIONAL MANUAL SHUTOFF WHICH WOULD ENDANGER THE SAFETY OF PATRONS. THE ELECTRICAL CONTRACTOR SHALL COORDINATE EXACT ENCLOSURE DETAILS AND MOUNTING LOCATIONS WITH THE ARCHITECT AND OWNER PRIOR TO ROUGH-IN.

- KEY NOTES:**
1. ROBW LED TAPE LIGHT, 4.6W/FT. USE PRIZM LIGHTING: CAT-P2M-TLH-54-24V-ROBW-16. PROVIDE THE NECESSARY QUANTITY OF DRIVERS, DIMM CONTROLLERS, AND ACCESSORIES AS REQUIRED FOR A COMPLETE WORKING SYSTEM. SEE ARCHITECTURAL DRAWINGS FOR EXACT PLACEMENT OF TAPE LIGHT. LIGHTS ARE 120V AND SHOULD BE POWERED FROM, AND SWITCHED WITH, THE APPROPRIATE LIGHTING CIRCUIT AS SHOWN. COORDINATE WITH OWNER ON DESIRED LOCATION OF LIGHTING CONTROL SWITCH PRIOR TO ROUGH-IN. JUNCTION BOX AND CONNECTIONS ARE TO BE CONCEALED ABOVE CEILING.

NOTE: THE CONTRACT DRAWINGS ARE NOT ORGANIZED SPECIFICALLY FOR ANY CRAFT, TRADE, DISCIPLINE, OR SUBCONTRACT. THEREFORE, ADDITIONAL RELATED INFORMATION MAY BE INCLUDED IN OTHER CONTRACT DRAWINGS AND SPECIFICATIONS EVEN THOUGH NOT SPECIFICALLY NOTED ON THIS DOCUMENT. IT IS THE RESPONSIBILITY OF EACH PARTY TO REFER TO THE COMPLETE SET OF CONTRACT DRAWINGS AND SPECIFICATIONS, AND NOT TO A PARTIAL OR INCOMPLETE SET OF DOCUMENTS.

Brent Barron Architect

P 6 0 1 . 7 5 0 . 1 7 7 8
114 WOODHILL DR, MADISON, MS 39110

ALLIED

CONSULTING ENGINEERS

709 Calawha St.
Belmont, NC 28012
P: (704) 399-3943
www.allied-engineers.com
ALLIED #25110

STATE OF TEXAS
EDWIN D. BELLY
105419
LICENSED PROFESSIONAL ENGINEER
6-05-25
Texas Registered Firm
F-13463


ENLARGED LOCKER ROOM PLAN - LIGHTING
CLUB 4 FITNESS - EL PASO MONTWOOD

11705 MONTWOOD DR, EL PASO, TX 79936

20250321

FOR CONSTRUCTION
June 5, 2025

E1.4

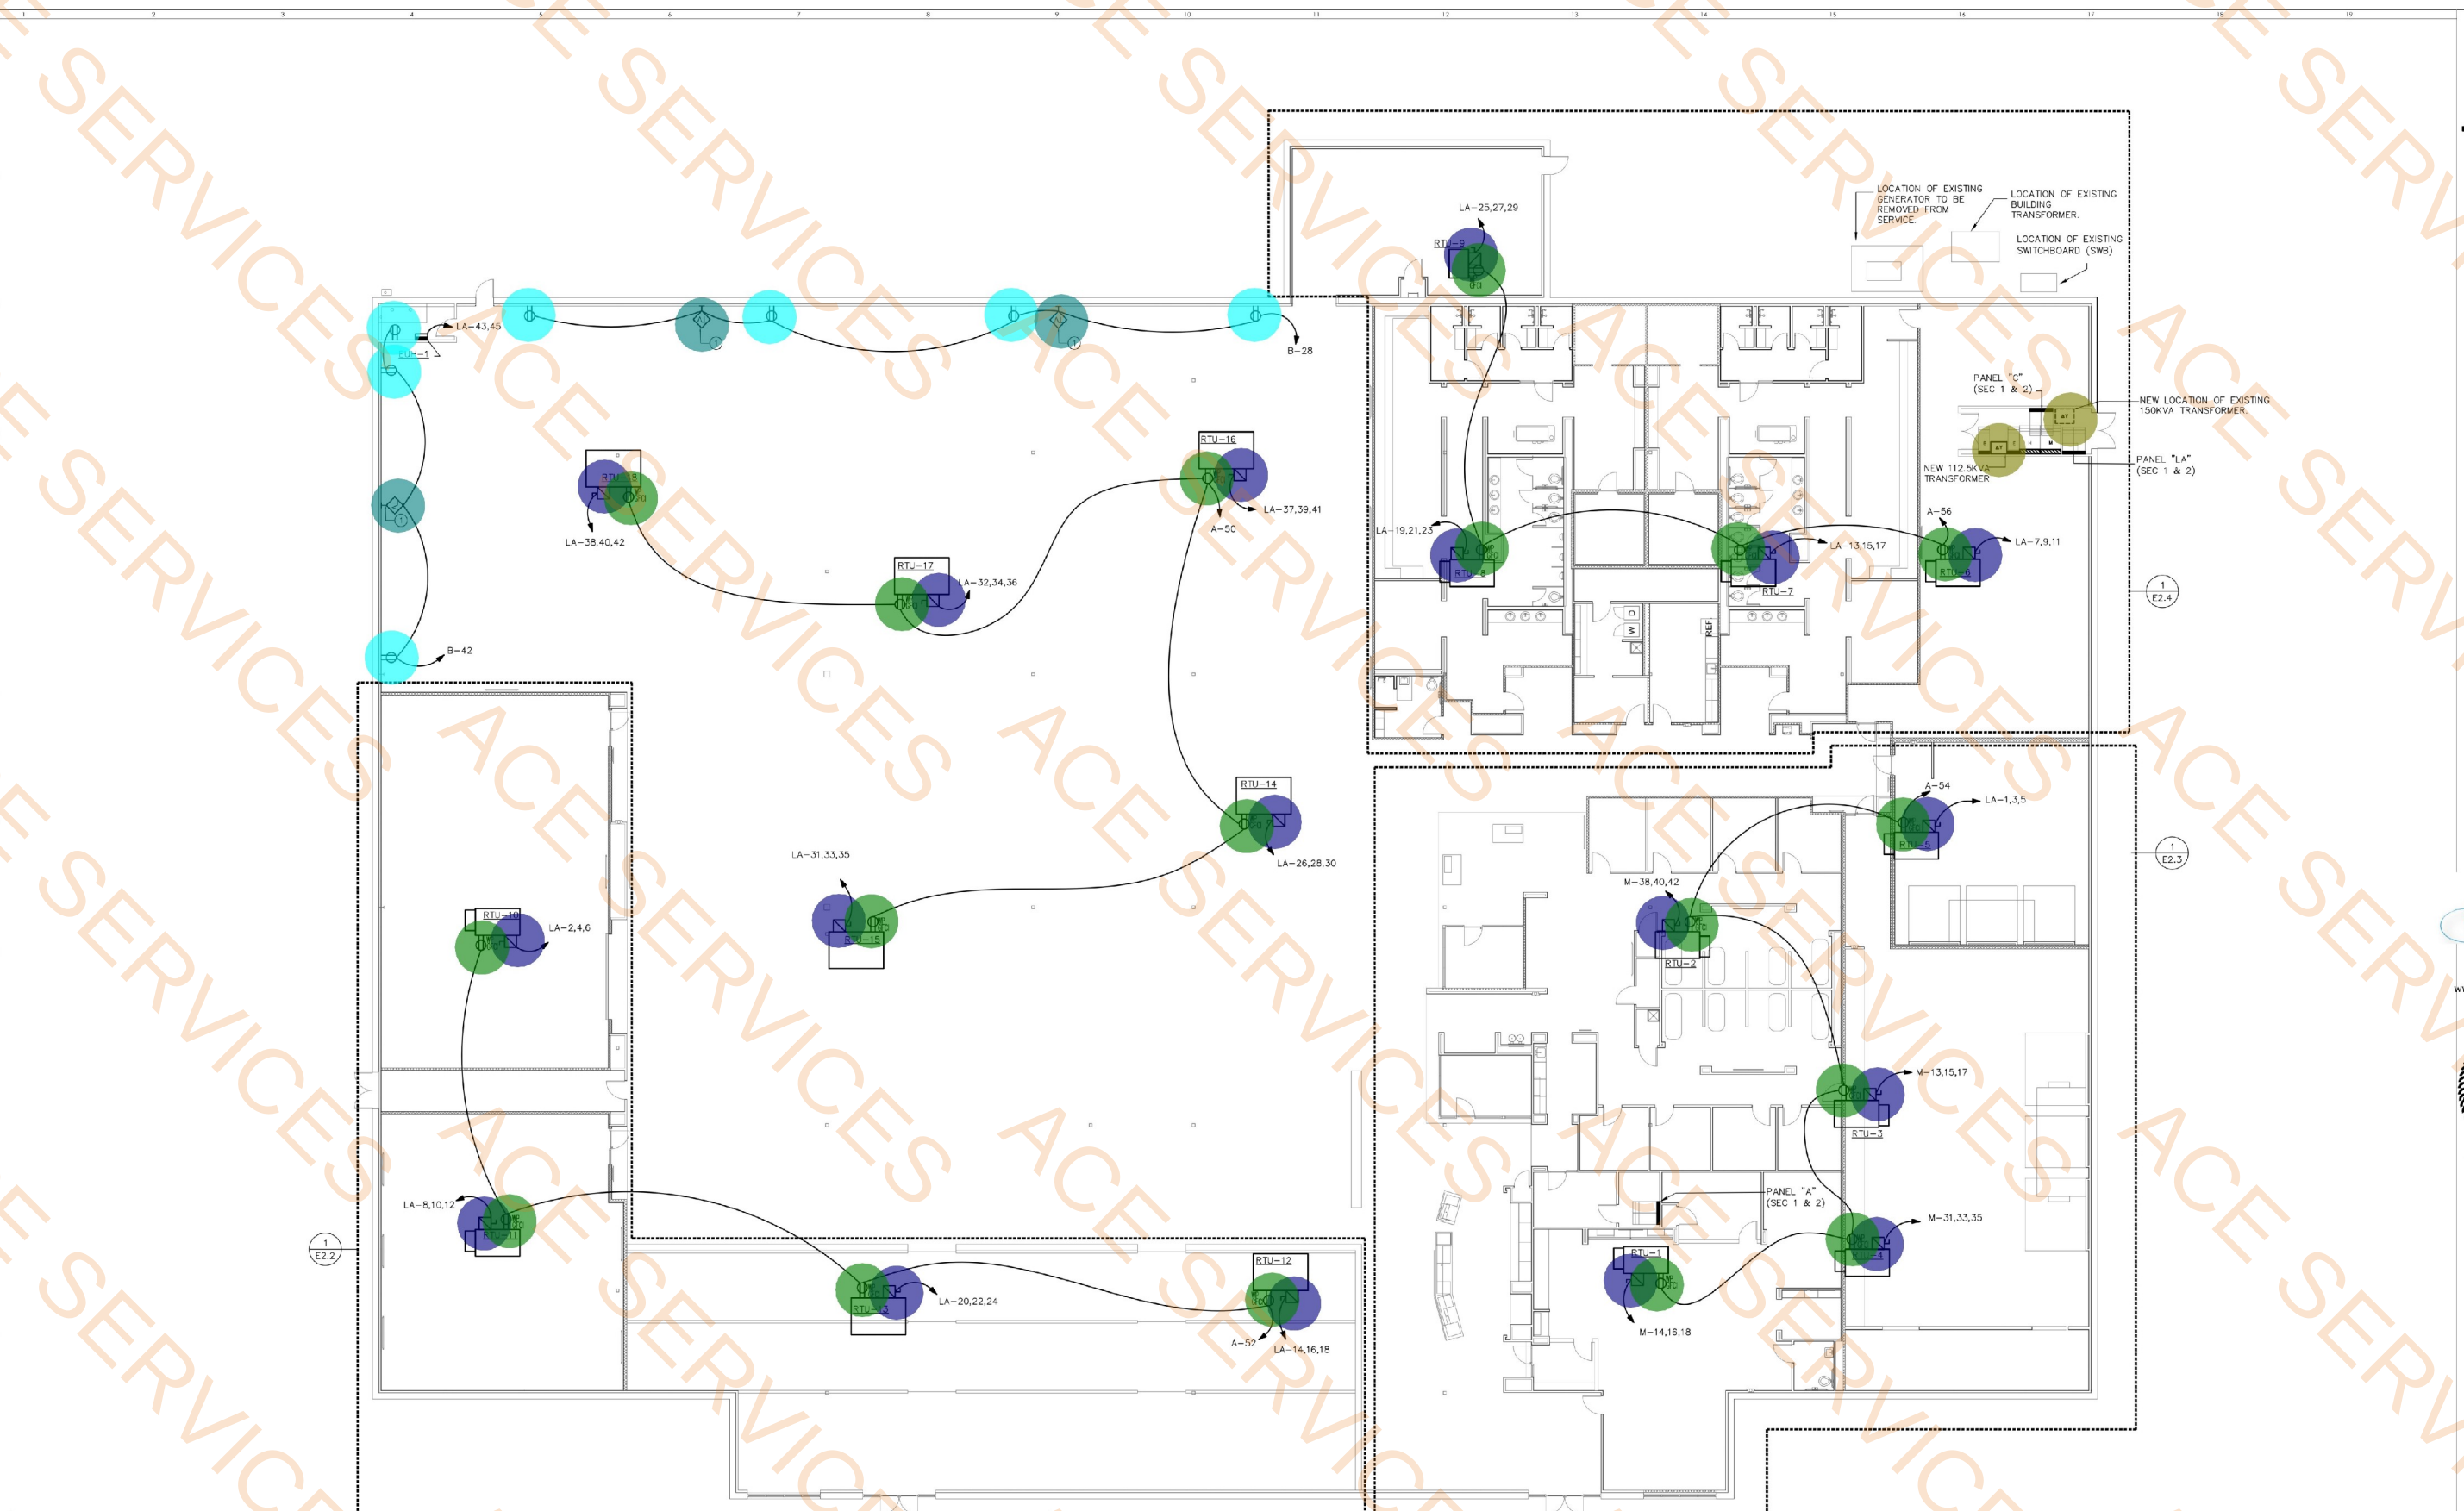

Duplex Receptacle

Weatherproof GFCI Duplex Receptacle

Floor Mounted Dry Type Transformer

Fused Disconnect Switch

Recessed Television Outlet

7.0 EA

18.0 EA

2.0 EA

18.0 EA

3.0 EA

PLAN - POWER

HAVE 94" EMT RUN FROM THE DEVICE TO DOWN TO 12" ABOVE THE COMMUNICATION BACKBONE

ALL GEAR (WITH EXCEPTION TO THE FIRE REMOVED DURING DEMO)

ASSOCIATED DEVICES/DISCONNECTS ARE TO BE LOCATED WITH ARCHITECTURAL AND MECHANICAL CONDUITS.

KEY NOTES:
1. COORDINATE WITH ARCHITECT ON EXACT LOCATION AND HEIGHT OF RECESSED TV OUTLET PRIOR TO ROUGH-IN. REFER TO 3/E0.2 FOR TV BOX DETAILS. PROVIDE (1) 94" C FOR POWER AND (1) 1 1/2" C RUN BACK TO TV RACK LOCATION FOR DATA CABLEING. EACH TV BOX IS TO HAVE (1) 20A DUPLEX POWER OUTLET.

NOTE: THE CONTRACT DRAWINGS ARE NOT ORGANIZED SPECIFICALLY FOR ANY CRAFT, TRADE, DISCIPLINE, OR SUBCONTRACT. THEREFORE, ADDITIONAL RELATED INFORMATION MAY BE INCLUDED IN OTHER CONTRACT DRAWINGS AND SPECIFICATIONS EVEN THOUGH NOT SPECIFICALLY NOTED ON THIS DOCUMENT. IT IS THE RESPONSIBILITY OF EACH PARTY TO REFER TO THE COMPLETE SET OF CONTRACT DRAWINGS AND SPECIFICATIONS, AND NOT TO A PARTIAL OR INCOMPLETE SET OF DOCUMENTS.

Brent Barron Architect

P 6 0 1 . 7 5 0 . 1 7 7 8
114 WOODHILL DR, WADSWORTH, MS 39110

ALLIED CONSULTING ENGINEERS

709 Calabash St.
Belmont, NC 28012
P: (704) 399-3943
www.allied-engineers.com
ALLIED #25110

STATE OF TEXAS
EDWIN D. BELK
105415
PROFESSIONAL ENGINEER
6-05-25
Texas Registered Firm
F-13463


OVERALL BUILDING PLAN - POWER
CLUB 4 FITNESS - EL PASO MONTWOOD

11705 MONTWOOD DR, EL PASO, TX 79936

20250321

FOR CONSTRUCTION
June 5, 2025

E2.1

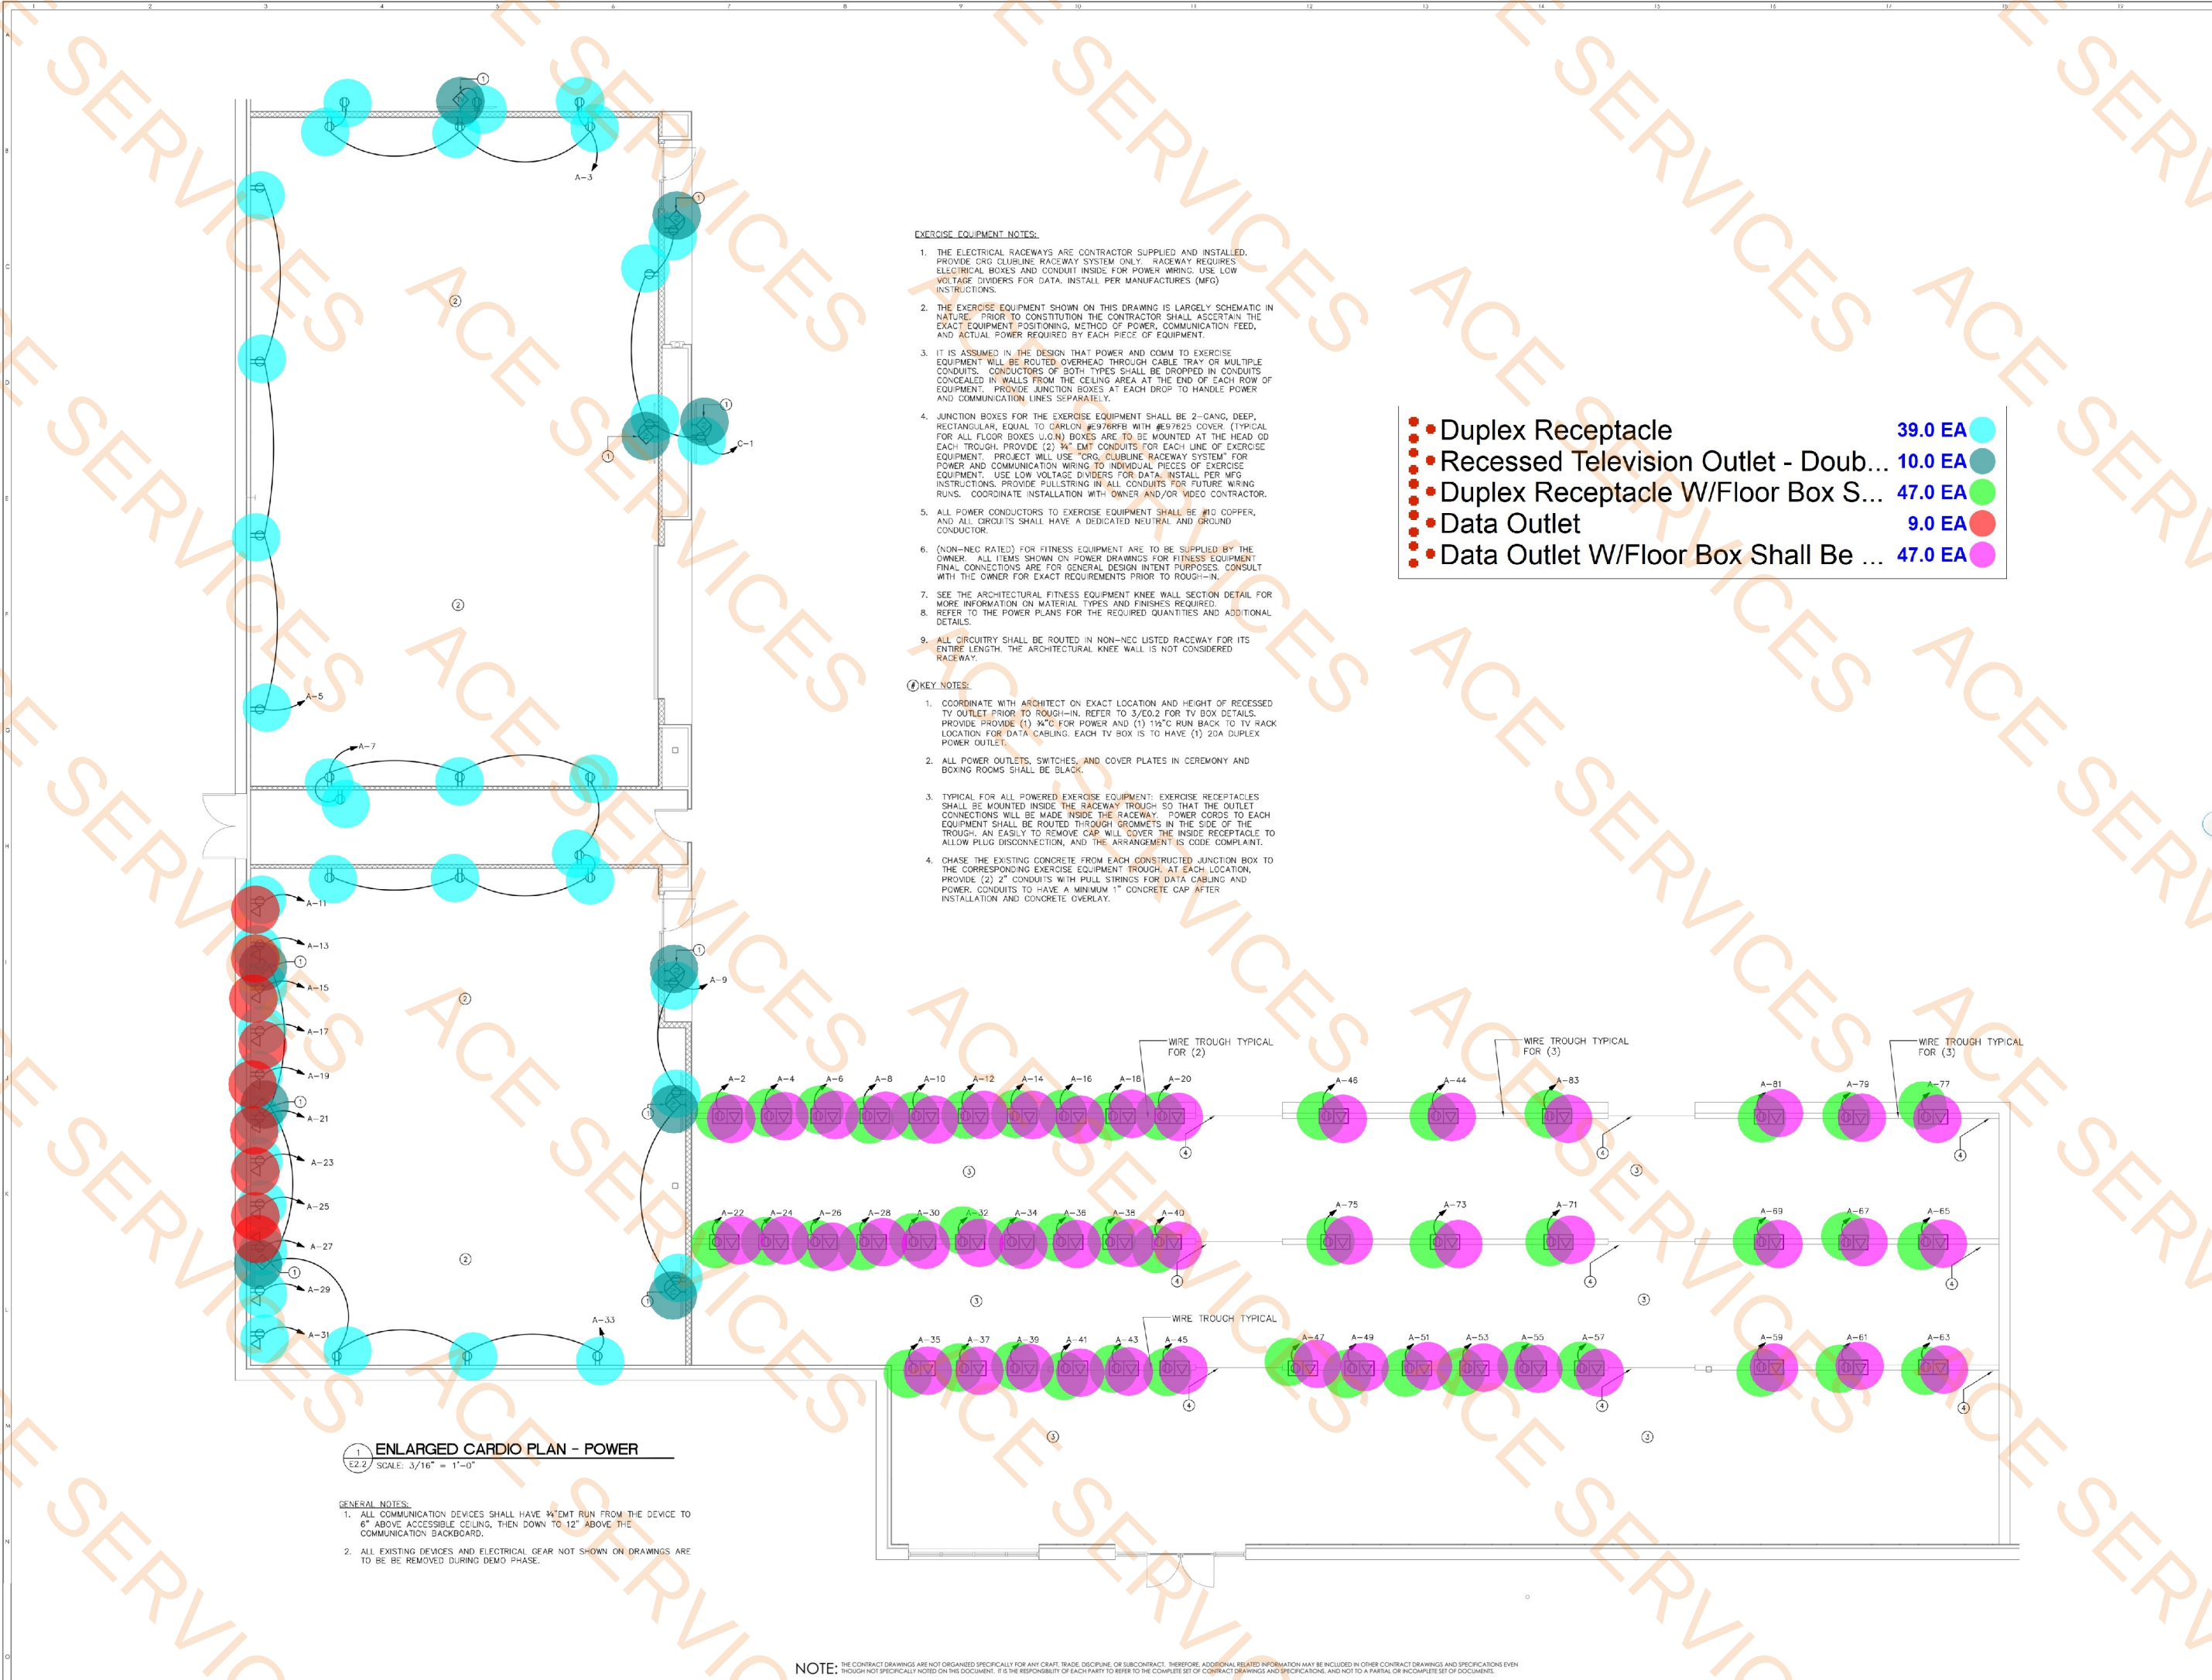

Brent Barron Architect

P 6 0 1 . 7 5 0 . 1 7 8
114 WOODY HILLS DR, MADISON, MS 39110

ALLIED
CONSULTING ENGINEERS

709 Calatwa St.
Belmont, NC 28012
P: (704) 399-3943
www.allied-engineers.com
ALLIED #25110

STATE OF TEXAS
EDWIN D. BELK
105419
LICENSED PROFESSIONAL ENGINEER
6-05-25
Texas Registered Firm
F-13463


ENLARGED CARDIO PLAN - POWER
CLUB 4 FITNESS - EL PASO MONTWOOD

11705 MONTWOOD DR, EL PASO, TX 79936

20250321

FOR CONSTRUCTION
June 5, 2025

E2.2

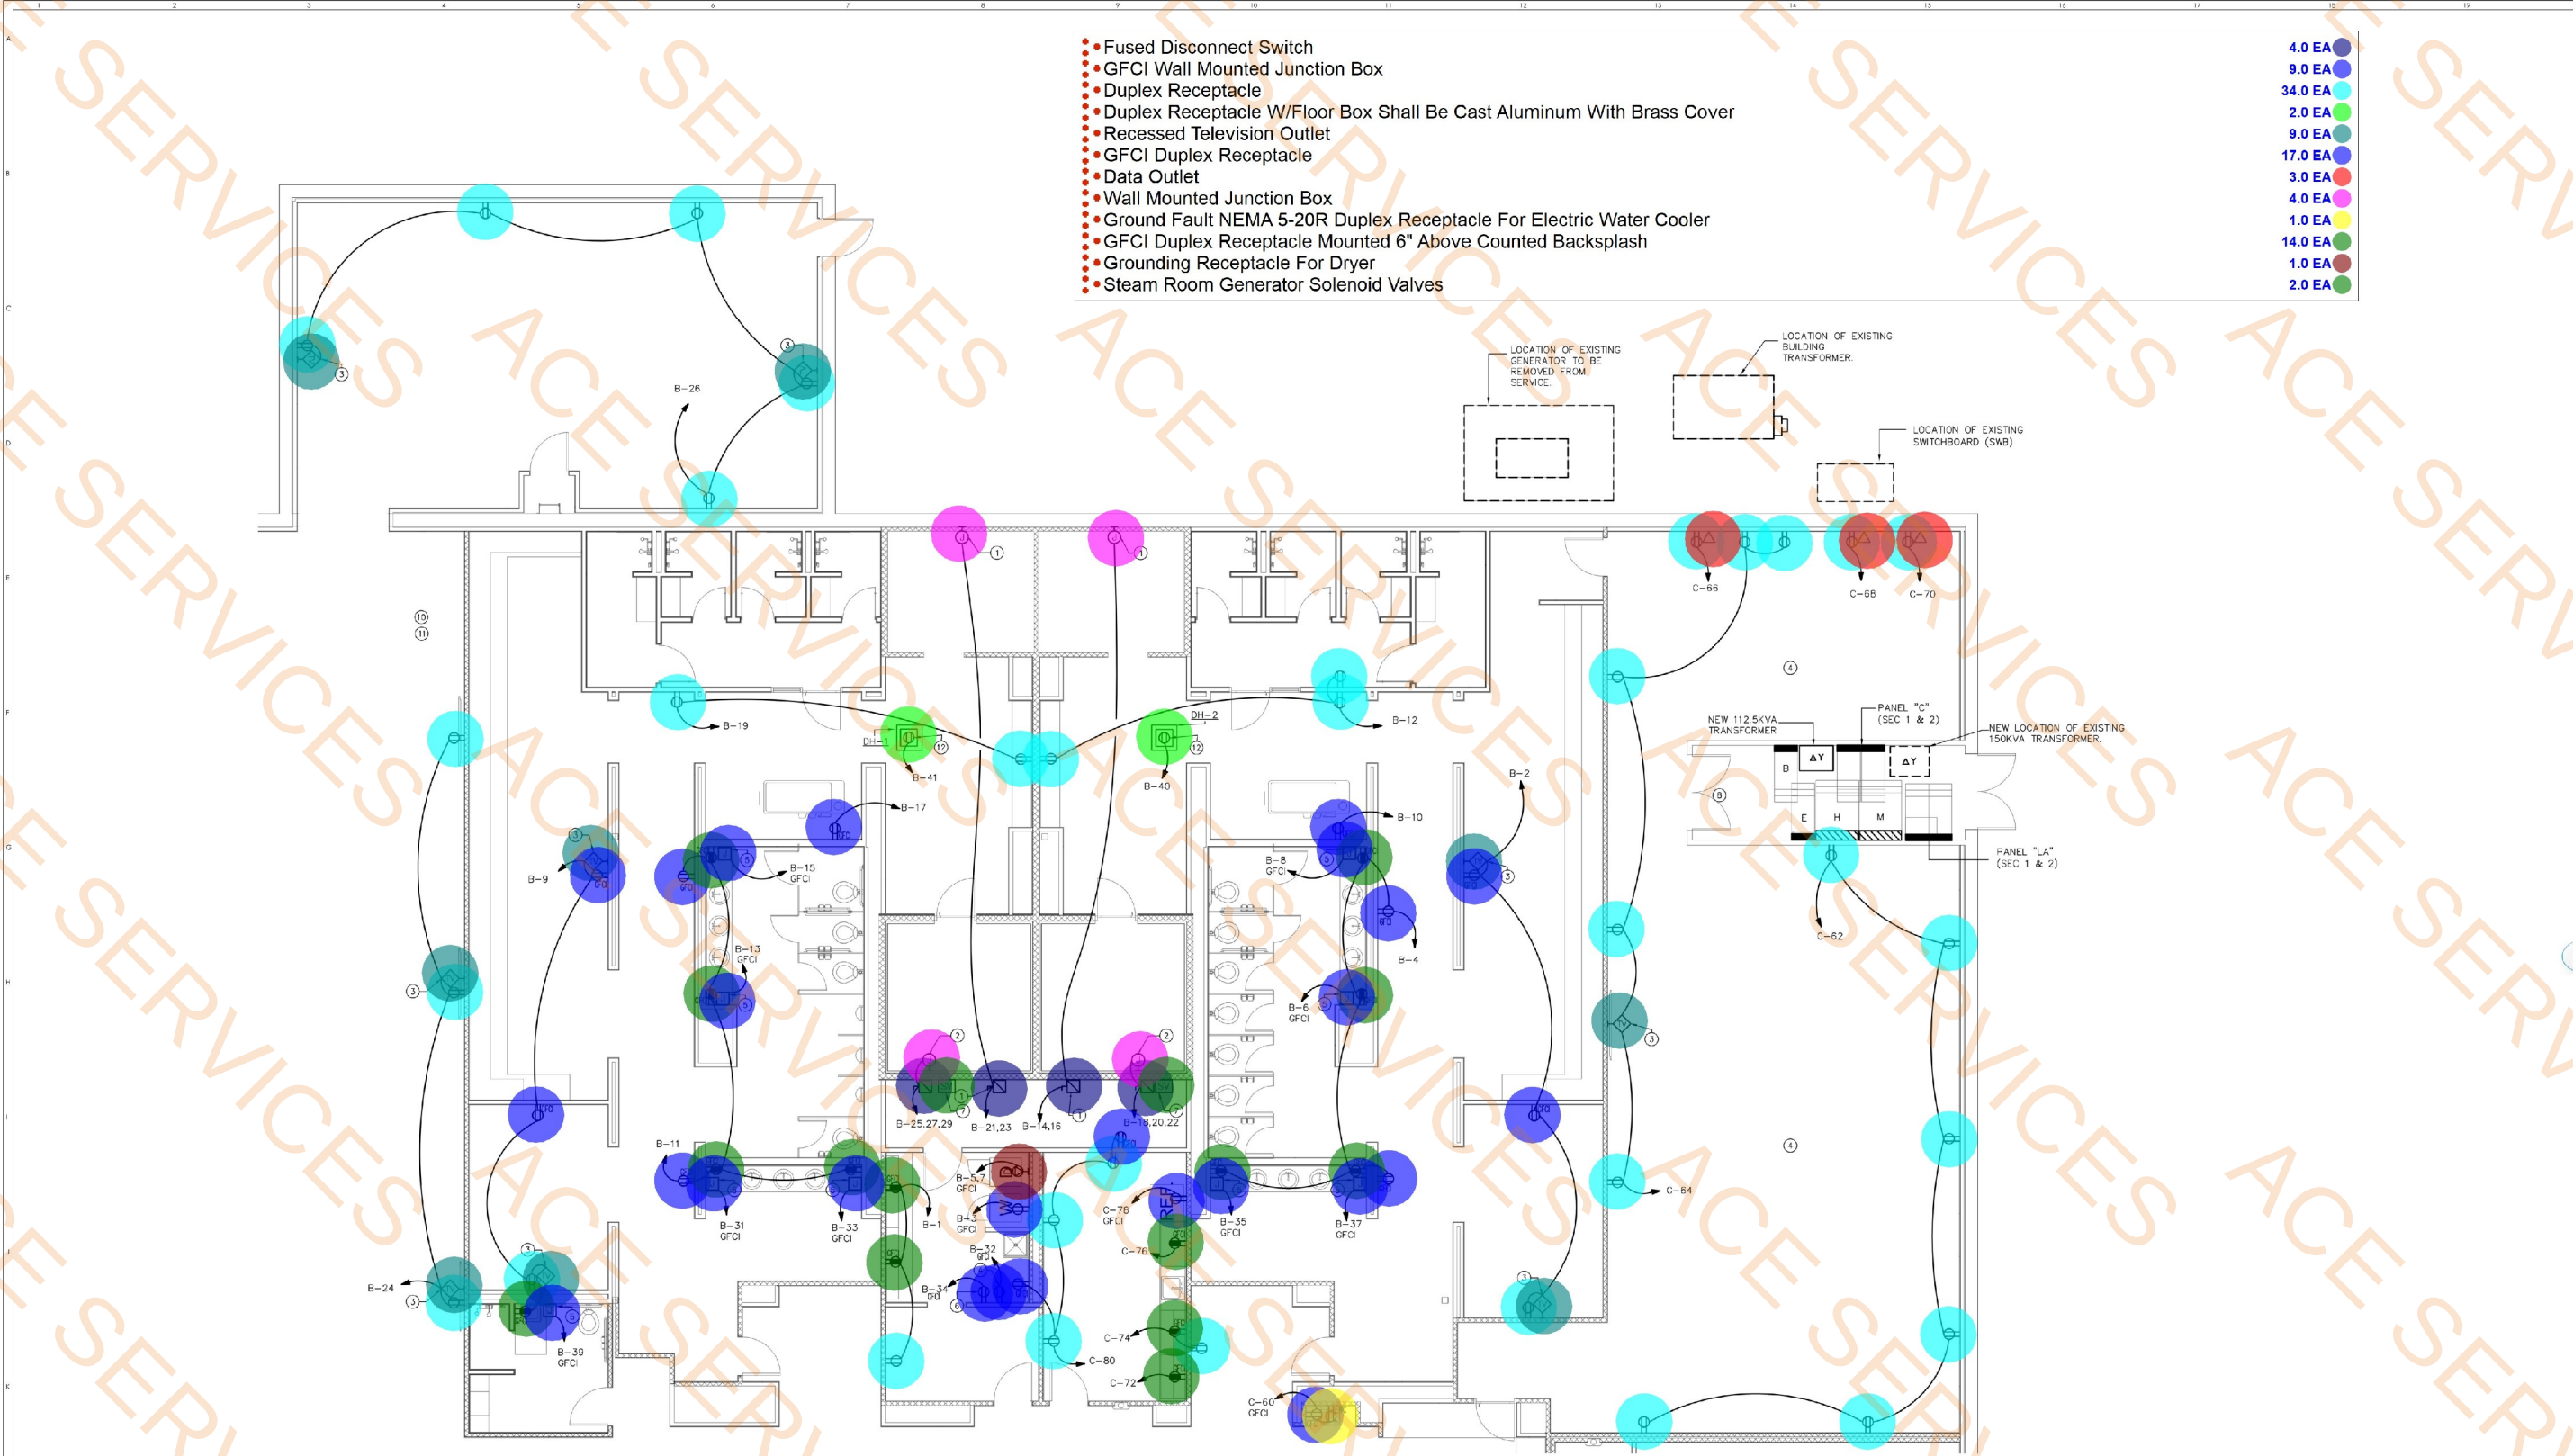

- Fused Disconnect Switch
- GFCI Wall Mounted Junction Box
- Duplex Receptacle
- Duplex Receptacle W/Floor Box Shall Be Cast Aluminum With Brass Cover
- Recessed Television Outlet
- GFCI Duplex Receptacle
- Data Outlet
- Wall Mounted Junction Box
- Ground Fault NEMA 5-20R Duplex Receptacle For Electric Water Cooler
- GFCI Duplex Receptacle Mounted 6" Above Counted Backsplash
- Grounding Receptacle For Dryer
- Steam Room Generator Solenoid Valves

- 4.0 EA
- 9.0 EA
- 34.0 EA
- 2.0 EA
- 9.0 EA
- 17.0 EA
- 3.0 EA
- 4.0 EA
- 1.0 EA
- 14.0 EA
- 1.0 EA
- 2.0 EA

- EXERCISE EQUIPMENT NOTES:**
1. THE EXERCISE EQUIPMENT SHOWN ON THIS DRAWING IS LARGELY SCHEMATIC IN NATURE. PRIOR TO CONSTRUCTION THE CONTRACTOR SHALL ASCERTAIN THE EXACT EQUIPMENT POSITIONING, METHOD OF POWER, COMMUNICATION FEED, AND ACTUAL POWER REQUIRED BY EACH PIECE OF EQUIPMENT.
 2. IT IS ASSUMED IN THE DESIGN THAT POWER AND COMM TO EXERCISE EQUIPMENT WILL BE ROUTED OVERHEAD THROUGH CABLE TRAY OR MULTIPLE CONDUITS. CONDUCTORS OF BOTH TYPES SHALL BE DROPPED IN CONDUITS FROM THE CEILING AREA AT THE END OF EACH ROW OF EQUIPMENT. PROVIDE JUNCTION BOXES AT EACH DROP TO HANDLE POWER AND COMMUNICATION LINES SEPARATELY.
 3. JUNCTION BOXES FOR THE EXERCISE EQUIPMENT SHALL BE 2-GANG, DEEP, RECTANGULAR, EQUAL TO CARLON #E976RFB WITH #E97625 COVER. (TYPICAL FOR ALL FLOOR BOXES U.O.N.) BOXES ARE TO BE MOUNTED AT THE HEAD OF EACH TROUGH. PROVIDE (2) 3/4" EMT CONDUITS FOR EACH LINE OF EXERCISE EQUIPMENT. PROJECT WILL USE "ORG. CLIBLINE RACEWAY SYSTEM" FOR POWER AND COMMUNICATION WIRING TO INDIVIDUAL PIECES OF EXERCISE EQUIPMENT. USE LOW VOLTAGE DIVIDERS FOR DATA. INSTALL PER MFG INSTRUCTIONS. PROVIDE PULLSTICKS IN ALL CONDUITS FOR FUTURE WIRING RUNS. COORDINATE INSTALLATION WITH OWNER AND/OR VIDEO CONTRACTOR.
 4. ALL POWER CONDUCTORS TO EXERCISE EQUIPMENT SHALL BE #10 COPPER, AND ALL CIRCUITS SHALL HAVE A DEDICATED NEUTRAL AND GROUND CONDUCTOR.
 5. (NON-NEC RATED) FOR FITNESS EQUIPMENT ARE TO BE SUPPLIED BY THE OWNER. ALL ITEMS SHOWN ON POWER DRAWINGS FOR FITNESS EQUIPMENT FINAL CONNECTIONS ARE FOR GENERAL DESIGN INTENT PURPOSES. CONSULT WITH THE OWNER FOR EXACT REQUIREMENTS PRIOR TO ROUGH-IN.
 6. SEE THE ARCHITECTURAL FITNESS EQUIPMENT KNEE WALL SECTION DETAIL FOR MORE INFORMATION ON MATERIAL TYPES AND FINISHES REQUIRED.
 7. REFER TO THE POWER PLANS FOR THE REQUIRED QUANTITIES AND ADDITIONAL DETAILS.
 8. ALL CIRCUITRY SHALL BE ROUTED IN NON-NEC LISTED RACEWAY FOR ITS ENTIRE LENGTH. THE ARCHITECTURAL KNEE WALL IS NOT CONSIDERED RACEWAY.

ENLARGED LOCKER ROOM PLAN - POWER
SCALE: 3/16" = 1'-0"

- GENERAL NOTES:**
1. ALL COMMUNICATION DEVICES SHALL HAVE 1/2" EMT RUN FROM THE DEVICE TO 6" ABOVE ACCESSIBLE CEILING, THEN DOWN TO 12" ABOVE THE COMMUNICATION BACKBOARD.
 2. COORDINATE MANUFACTURE'S REQUIREMENTS AND LOCATIONS OF POWER AND/OR DATA FEEDS TO ALL GYM EQUIPMENT, TANNING BEDS, HYDRO MASSAGERS, ETC. PRIOR TO CONSTRUCTION ROUGH-IN.
 3. ALL EXISTING DEVICES AND ELECTRICAL GEAR NOT SHOWN ON DRAWINGS ARE TO BE REMOVED DURING DEMO PHASE.
 4. CENTERLINE HEIGHT OF GFCI RECEPTACLES BY LAVATORIES SHALL BE 8" ABOVE THE HEIGHT OF THE LAVATORY.

- KEY NOTES:**
1. PROVIDED (1) 30/750-2P DISCONNECT SWITCH FOR EACH SAUNA. ROUTE CONDUITS FROM DISCONNECT TO SAUNA CONNECTION POINT. COORDINATE WITH SAUNA INSTALLER PRIOR TO ROUGH-IN FOR CONNECTION POINTS.
 2. PROVIDED (1) 200/F110-3P DISCONNECT SWITCH FOR EACH STEAM ROOM. ROUTE CONDUITS FROM DISCONNECT TO STEAM ROOM CONNECTION POINT. COORDINATE WITH STEAM ROOM INSTALLER PRIOR TO ROUGH-IN FOR CONNECTION POINTS.
 3. COORDINATE WITH ARCHITECT ON EXACT LOCATION AND HEIGHT OF RECESSED TV OUTLET PRIOR TO ROUGH-IN. REFER TO 3/EO.2 FOR TV BOX DETAILS. PROVIDE (1) 1/2" FOR POWER AND (1) 1/2" FOR TV BACK TO TV RACK LOCATION FOR DATA CABLING. EACH TV BOX IS TO HAVE (1) 20A DUPLEX POWER OUTLET.
 4. REMOVE EXISTING 150KVA TRANSFORMER AND PANELS "C" AND "LA" FROM MEZZANINE, AND RELOCATE TO NEW LOCATIONS SHOWN IN ELECTRICAL ROOM. REMOVE ALL EXISTING CONDUIT AND WIRE BACK TO SOURCE.
 5. PROVIDE JUNCTION BOX FOR DIRECT POWER CONNECTION TO WALL MOUNTED HAND DRYER. COORDINATE WITH OWNER ON DESIRED MOUNTING HEIGHT PRIOR TO ROUGH-IN.
 6. PROVIDE DEDICATED OUTLET WITHIN 2FT OF RECIRO PUMP FOR POWER. COORDINATE WITH PLUMBING ON EXACT LOCATION PRIOR TO ROUGH-IN.
 7. PROVIDE 120V POWER TO STEAM ROOM GENERATOR SOLENOID VALVES FROM LOCAL CIRCUIT C-80. COORDINATE EXACT LOCATION WITH STEAM GENERATOR INSTALLER PRIOR TO ROUGH-IN.

8. REMOVE ALL EXISTING DATA AND TELEPHONE EQUIPMENT FROM MAIN ELECTRICAL ROOM.
9. REMOVE EXISTING 30KVA TRANSFORMER. RE-ROUTE EXISTING CONDUIT FROM SWB TO NEW LOCATION OF PANEL "LA" SECTIONS 1 & 2.
10. REMOVE EXISTING 150KVA TRANSFORMER AND PANELS "C" AND "LA" FROM MEZZANINE, AND RELOCATE TO NEW LOCATIONS SHOWN IN ELECTRICAL ROOM. REMOVE ALL EXISTING CONDUIT AND WIRE BACK TO SOURCE.
11. VERIFY EXISTING LOCATION (APPROPRIATELY AT THIS SPOT) OF BUILDING FIRE PUMP ON THE MEZZANINE. DISCONNECT POWER AND EXTEND EXISTING CONDUIT AND WIRE FROM CURRENT LOCATION TO NEW LOCATION FIRE PUMP. FIELD VERIFY ALL OF THE EXISTING CONDITIONS PRIOR TO START OF WORK. COORDINATE WITH OWNER ON THE NEW LOCATION OF FIRE PUMP PRIOR TO ROUGH-IN.
12. PROVIDE 20A DUPLEX RECEPTACLE ABOVE CEILING WITHIN 2FT OF DH-1 OR DH-2 FOR POWER CONNECTION. COORDINATE WITH MECHANICAL FOR EXACT LOCATION AND CONNECTION REQUIREMENTS PRIOR TO ROUGH-IN.

NOTE: THE CONTRACT DRAWINGS ARE NOT ORGANIZED SPECIFICALLY FOR ANY CRAFT, TRADE, DISCIPLINE, OR SUBCONTRACT. THEREFORE, ADDITIONAL RELATED INFORMATION MAY BE INCLUDED IN OTHER CONTRACT DRAWINGS AND SPECIFICATIONS EVEN THOUGH NOT SPECIFICALLY NOTED ON THIS DOCUMENT. IT IS THE RESPONSIBILITY OF EACH PARTY TO REFER TO THE COMPLETE SET OF CONTRACT DRAWINGS AND SPECIFICATIONS, AND NOT TO A PARTIAL OR INCOMPLETE SET OF DOCUMENTS.

Brent Barron Architect

P 6 0 1 . 7 5 0 . 1 7 7 8
114 WOODY HILLS DR, WADSWORTH, MS 39110

ALLIED

CONSULTING ENGINEERS
709 Calabwa St.
Belmont, NC 28012
P: (704) 399-3943
www.allied-engineers.com
ALLIED #25110


STATE OF TEXAS
EDWIN D. BELLY
105419
LICENSED PROFESSIONAL ENGINEER
6-05-25
Texas Registered Firm
F-13463

ENLARGED LOCKER ROOM PLAN - POWER

CLUB 4 FITNESS - EL PASO MONTWOOD
11705 MONTWOOD DR, EL PASO, TX 79926
20250321

FOR CONSTRUCTION
June 5, 2025

E2.4

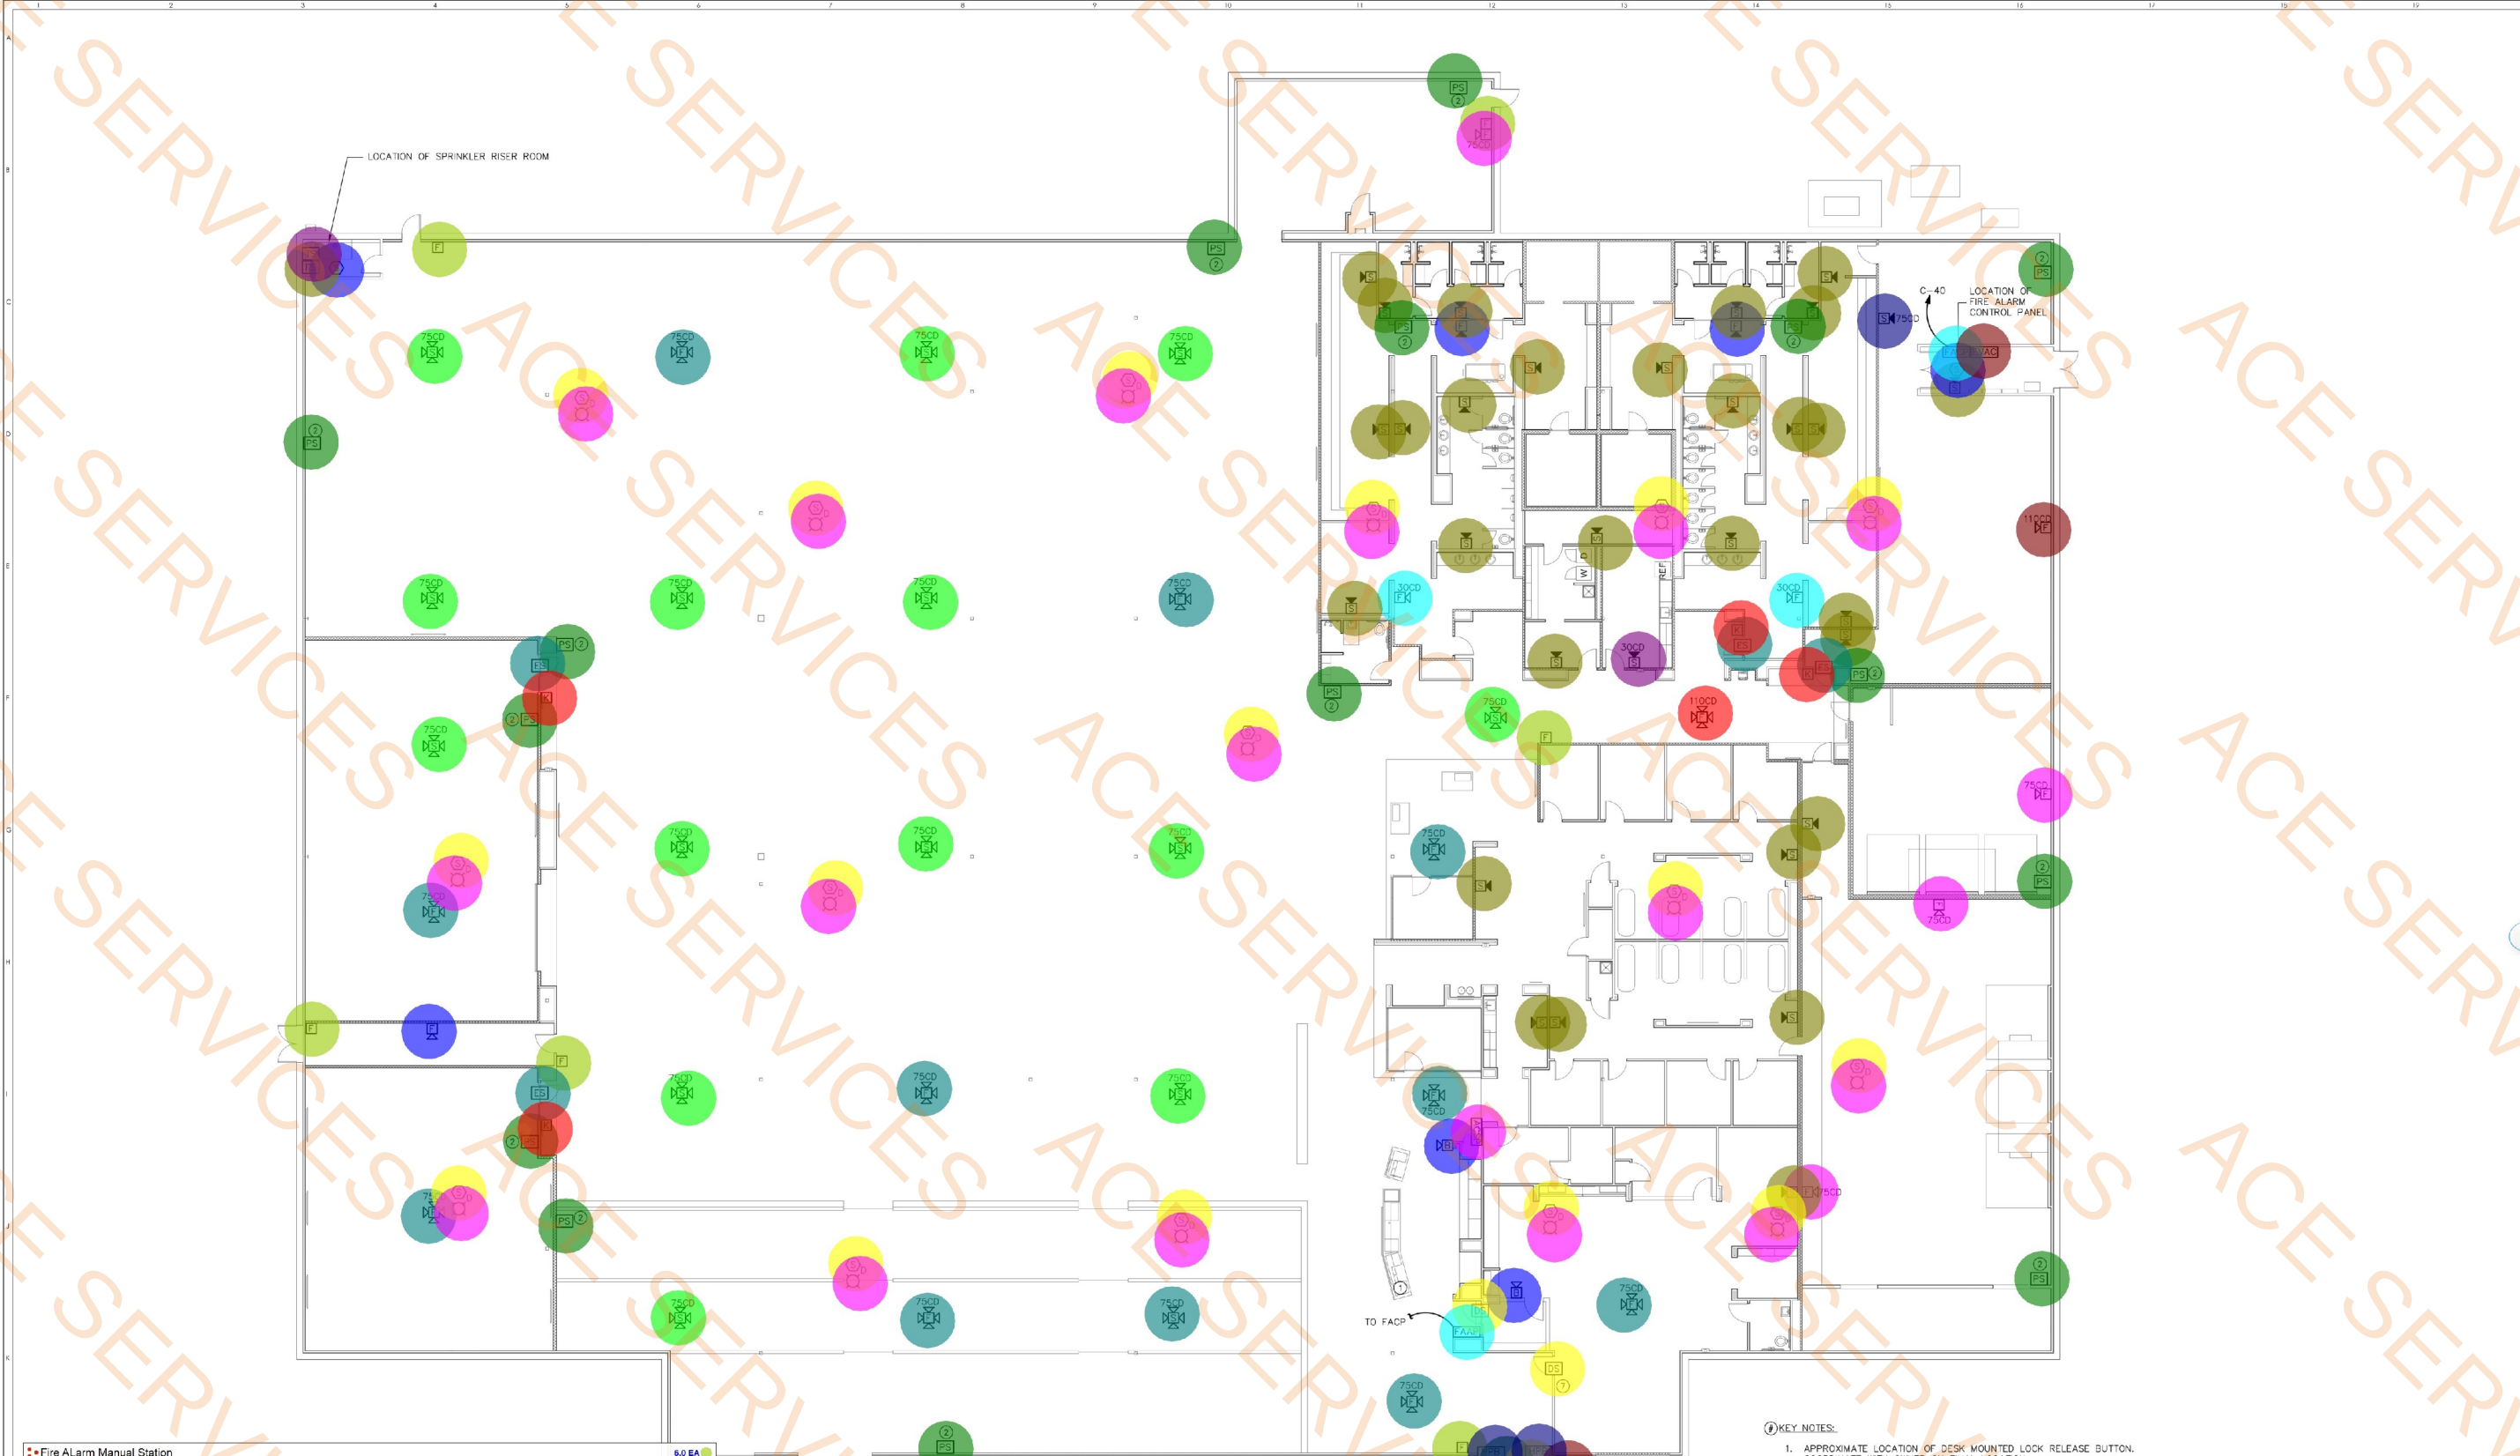

- Fire Alarm Manual Station
- Fire Alarm Horn-Strobe Combination
- Fire Alarm Horn-Strobe Combination
- Fire Alarm Horn-Strobe Combination
- Fire Alarm Horn-Strobe Combination
- Fire Alarm Strobe
- Fire Alarm Strobe
- Fire Alarm Strobe
- Fire Alarm Horn-Strobe Combination
- Fire Alarm Horn-Strobe Combination
- Fire Alarm Strobe
- Fire Alarm Smoke Detector
- Ceiling Mounted Fire Alarm Smoke Detector
- Fire Alarm Dual Detector Remote Indicating Light
- Fire Alarm Control Panel
- EVAC Control Panel
- Panic Pull station
- Fire Alarm Flow Switch On Sprinkler System
- Fire Alarm Tamper Switch on Sprinkler System
- Electric Door Strike
- Keypad
- Door Switch Access Control
- Day Care Buzzer
- Access Control System Panel
- Fire Alarm Remote Annunciator Panel
- Card Reader
- Handicap Door Operator
- Handicap Pushbutton

1 OVERALL BUILDING PLAN - FIRE ALARM + ACCESS CONTROL


GENERAL NOTES:
1. FIRE ALARM SYSTEM SHALL BE A VOICE EVACUATION TYPE.
2. MECHANICAL CONTRACTOR IS TO PROVIDE A DUCT TYPE SMOKE DETECTOR IN ALL SUPPLY AIR AND RETURN DUCTS. ELECTRICAL CONTRACTOR SHALL CONNECT THESE DETECTORS TO THE FIRE ALARM SYSTEM TO PROVIDE AIR HANDLING SHUTDOWN IN THE CASE OF FIRE. COORDINATE WITH MECHANICAL ON EXACT LOCATION AND INSTALLATION OF SMOKE DUCT DETECTORS PRIOR TO ROUGH-IN.

- KEY NOTES:
1. APPROXIMATE LOCATION OF DESK MOUNTED LOCK RELEASE BUTTON. COORDINATE WITH OWNER ON FINAL LOCATION.
 2. PANIC STYLE PULL STATION, CONTRACTOR SHALL PROVIDE FLUSH MOUNTED DEEP JUNCTION BOX AND 3/4" CONDUIT WITH PULL STRING TO 6" ABOVE ACCESSIBLE CEILING, OR TO 10'-0" A.F.F. MOUNT AT 48" A.F.F. FOR USE BY FUTURE ELECTRONIC RELAY AND WARNING SYSTEM CONTRACTOR.
 3. ACCESS CONTROL KEYPAD, CONTRACTOR SHALL PROVIDE FLUSH MOUNTED DEEP JUNCTION BOX AND 3/4" CONDUIT WITH PULL STRING TO 6" ABOVE ACCESSIBLE CEILING, OR TO 10'-0" A.F.F. MOUNT AT 48" A.F.F. FOR USE BY FUTURE ELECTRONIC RELAY AND WARNING SYSTEM CONTRACTOR.
 4. SECURITY SYSTEM RELEASE BUTTON, CONTRACTOR SHALL PROVIDE FLUSH MOUNTED DEEP JUNCTION BOX AND 3/4" CONDUIT WITH PULL STRING TO 6" ABOVE ACCESSIBLE CEILING, OR TO 10'-0" A.F.F. MOUNT AT 48" A.F.F. FOR USE BY FUTURE ELECTRONIC RELAY AND WARNING SYSTEM CONTRACTOR.
 5. AT THIS LOCATION, PROVIDE A CIRCUIT FOR A DOOR MOTOR ASSEMBLY AND WALL MOUNTED ACTUATION SWITCHES. CONNECT THROUGH THE ACCESS CONTROL PANEL. PRIOR TO ROUGH IN SEE THE POWER INSTRUCTIONS FOR THE DOOR MOTOR CHOSEN.
 6. AT THIS LOCATION, PROVIDE AN ALARM SYSTEM TO WARN OF UNINTENDED DOOR OPENINGS. SYSTEM SHALL CONSIST OF DOOR CONTACT HARDWARE, (2) BUZZER UNITS, LOW VOLTAGE TRANSFORMER WIRING, AND COMMERCIAL ACTUATION EQUIPMENT.
 7. AT THIS LOCATION, PROVIDE AN ALARM SYSTEM AS DESCRIBED IN KEY NOTE (6) TO WARN OF UNINTENDED DOOR OPENING. SYSTEM SHALL CONSIST OF DOOR CONTACT HARDWARE, CHIME UNIT, LOW VOLTAGE TRANSFORMER WIRING, AND COMMERCIAL ACTUATION EQUIPMENT. FEED CHILD EXERCISE DOOR ALARM SYSTEM FROM SAME CIRCUIT.

NOTE: THE CONTRACT DRAWINGS ARE NOT ORGANIZED SPECIFICALLY FOR ANY CRAFT, TRADE, DISCIPLINE, OR SUBCONTRACT. THEREFORE, ADDITIONAL RELATED INFORMATION MAY BE INCLUDED IN OTHER CONTRACT DRAWINGS AND SPECIFICATIONS EVEN THOUGH NOT SPECIFICALLY NOTED ON THIS DOCUMENT. IT IS THE RESPONSIBILITY OF EACH PARTY TO REFER TO THE COMPLETE SET OF CONTRACT DRAWINGS AND SPECIFICATIONS, AND NOT TO A PARTIAL OR INCOMPLETE SET OF DOCUMENTS.

Brent Barron Architect
P 6 0 1 . 7 5 0 . 1 7 7 8
114 WOODY HILLS DR. MADISON, MS 39110

ALLIED
CONSULTING ENGINEERS
709 Calatowha St.
Belmont, NC 28012
P: (704) 399-3943
www.allied-engineers.com
ALLIED #25110

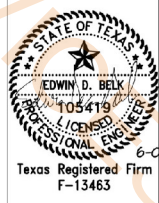

OVERALL BUILDING PLAN - FIRE ALARM
CLUB 4 FITNESS - EL PASO MONTWOOD
11705 MONTWOOD DR, EL PASO, TX 79936
20250321

FOR CONSTRUCTION
June 5, 2025

FA1.0



Brent Barron Architect

P 6 0 1 . 7 5 0 . 1 7 7 8
114 WOODY HILLS DR, MADISON, MS 39110

FLOOR PLAN - HVAC
CLUB 4 FITNESS - EL PASO MONTWOOD


11705 MONTWOOD DR, EL PASO, TX 79936

20250321

FOR CONSTRUCTION
JUNE 5, 2025



M1.1

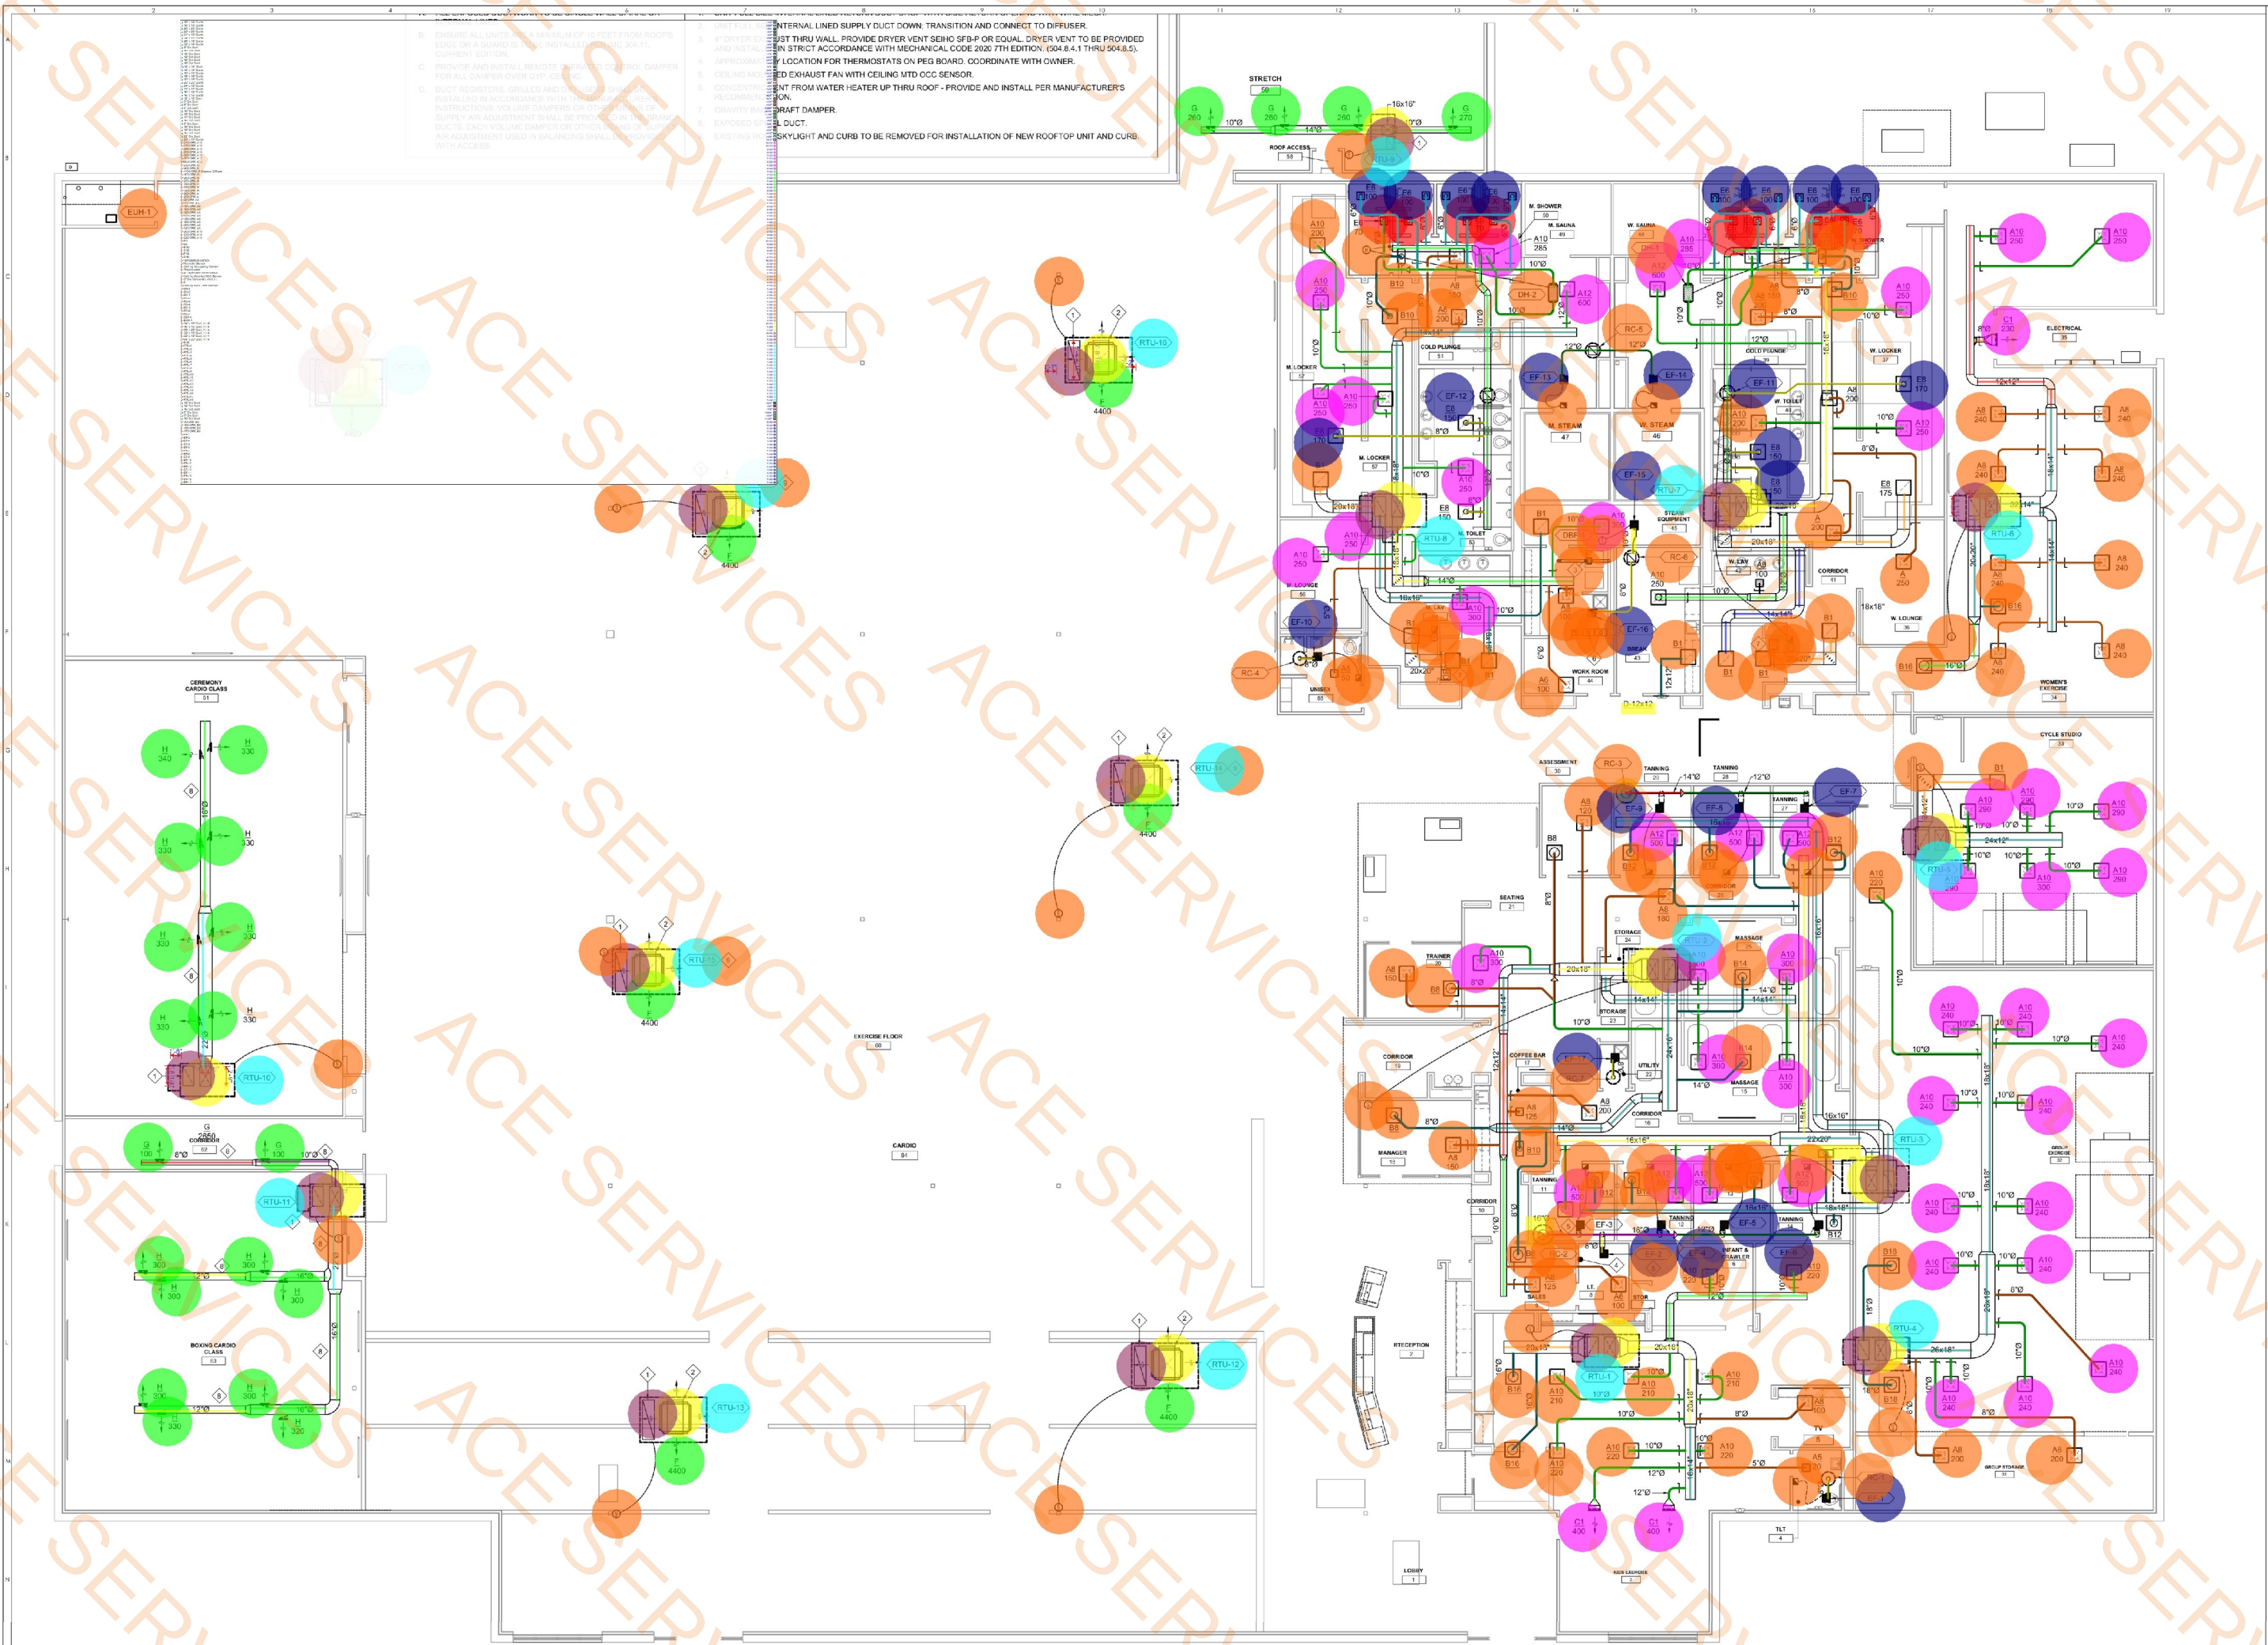

1 Floor Plan - Plumbing "Sanitary" (Renovation)
1/8" = 1' - 0"

NOTE: THE CONTRACT DRAWINGS ARE NOT ORGANIZED SPECIFICALLY FOR ANY CRAFT, TRADE, DISCIPLINE, OR SUBCONTRACT. THEREFORE, ADDITIONAL RELATED INFORMATION MAY BE INCLUDED IN OTHER CONTRACT DRAWINGS AND SPECIFICATIONS EVEN THOUGH NOT SPECIFICALLY NOTED ON THIS DOCUMENT. IT IS THE RESPONSIBILITY OF EACH PARTY TO REFER TO THE COMPLETE SET OF CONTRACT DRAWINGS AND SPECIFICATIONS, AND NOT TO A PARTIAL OR INCOMPLETE SET OF DOCUMENTS.



NOTE: THE CONTRACT DRAWINGS ARE NOT ORGANIZED SPECIFICALLY FOR ANY CRAFT, TRADE, DISCIPLINE, OR SUBCONTRACT. THEREFORE, ADDITIONAL RELATED INFORMATION MAY BE INCLUDED IN OTHER CONTRACT DRAWINGS AND SPECIFICATIONS EVEN THOUGH NOT SPECIFICALLY NOTED ON THIS DOCUMENT. IT IS THE RESPONSIBILITY OF EACH PARTY TO REFER TO THE COMPLETE SET OF CONTRACT DRAWINGS AND SPECIFICATIONS, AND NOT TO A PARTIAL OR INCOMPLETE SET OF DOCUMENTS.

1 Floor Plan - Plumbing "Sanitary" (Renovation)
1/8" = 1' - 0"

4" Wastage	248.8 FT	
3" Wastage	77.6 FT	
2" Wastage	13.0 FT	
FD-1	2.0 EA	
WC-2	1.0 EA	
L-2	1.0 EA	
2" Dia Vent Pipe	39.4 FT	
2" VTR, H: 25'	1.0 EA	
2" V, H: 9'	4.0 EA	
4" V, H: 9'	1.0 EA	
4" Dia Vent Pipe	6.5 FT	
4" VTR, H: 25'	1.0 EA	

GENERAL NOTES:	
A.	INSTALL DEEP-SEAL TRAP AT ALL FD-2, FS-1 AND TD-1 FLOOR/TRENCH DRAINS AND FLOOR SINKS.
B.	REFER TO PLUMBING FIXTURE SCHEDULE WHERE PIPE SIZES ARE NOT SHOWN TO PLUMBING FIXTURE.

PLAN NOTES:	
1.	NEW 4" WASTE: FIELD VERIFY EXISTING LOCATION. CONNECT TO EXISTING WASTE. VERIFY DEPTH OF EXISTING TO ENSURE THAT NEW WASTE CAN CONNECT WITH ADEQUATE SLOPE.
2.	PIPE DRAIN FROM STEAM GENERATORS TO FLOOR DRAIN.
3.	2" CONDENSATE DRAIN FROM ROOF: DROP AND SPILL INTO MOP SINK (MS-1).

SEE PARTIAL ENLARGED FLOOR PLAN SHEET P4.1





P601.750.1778

14 WOODY HILLS DR, MADISON, MS 39110


FLOOR PLAN - PLUMBING - SUPPLY
CLUB 4 FITNESS - EL PASO MONTWOOD

1705 MONTWOOD DR. EL PASO, TX 79936


20250321

FOR CONSTRUCTION
JUNE 5, 2025

P1.2

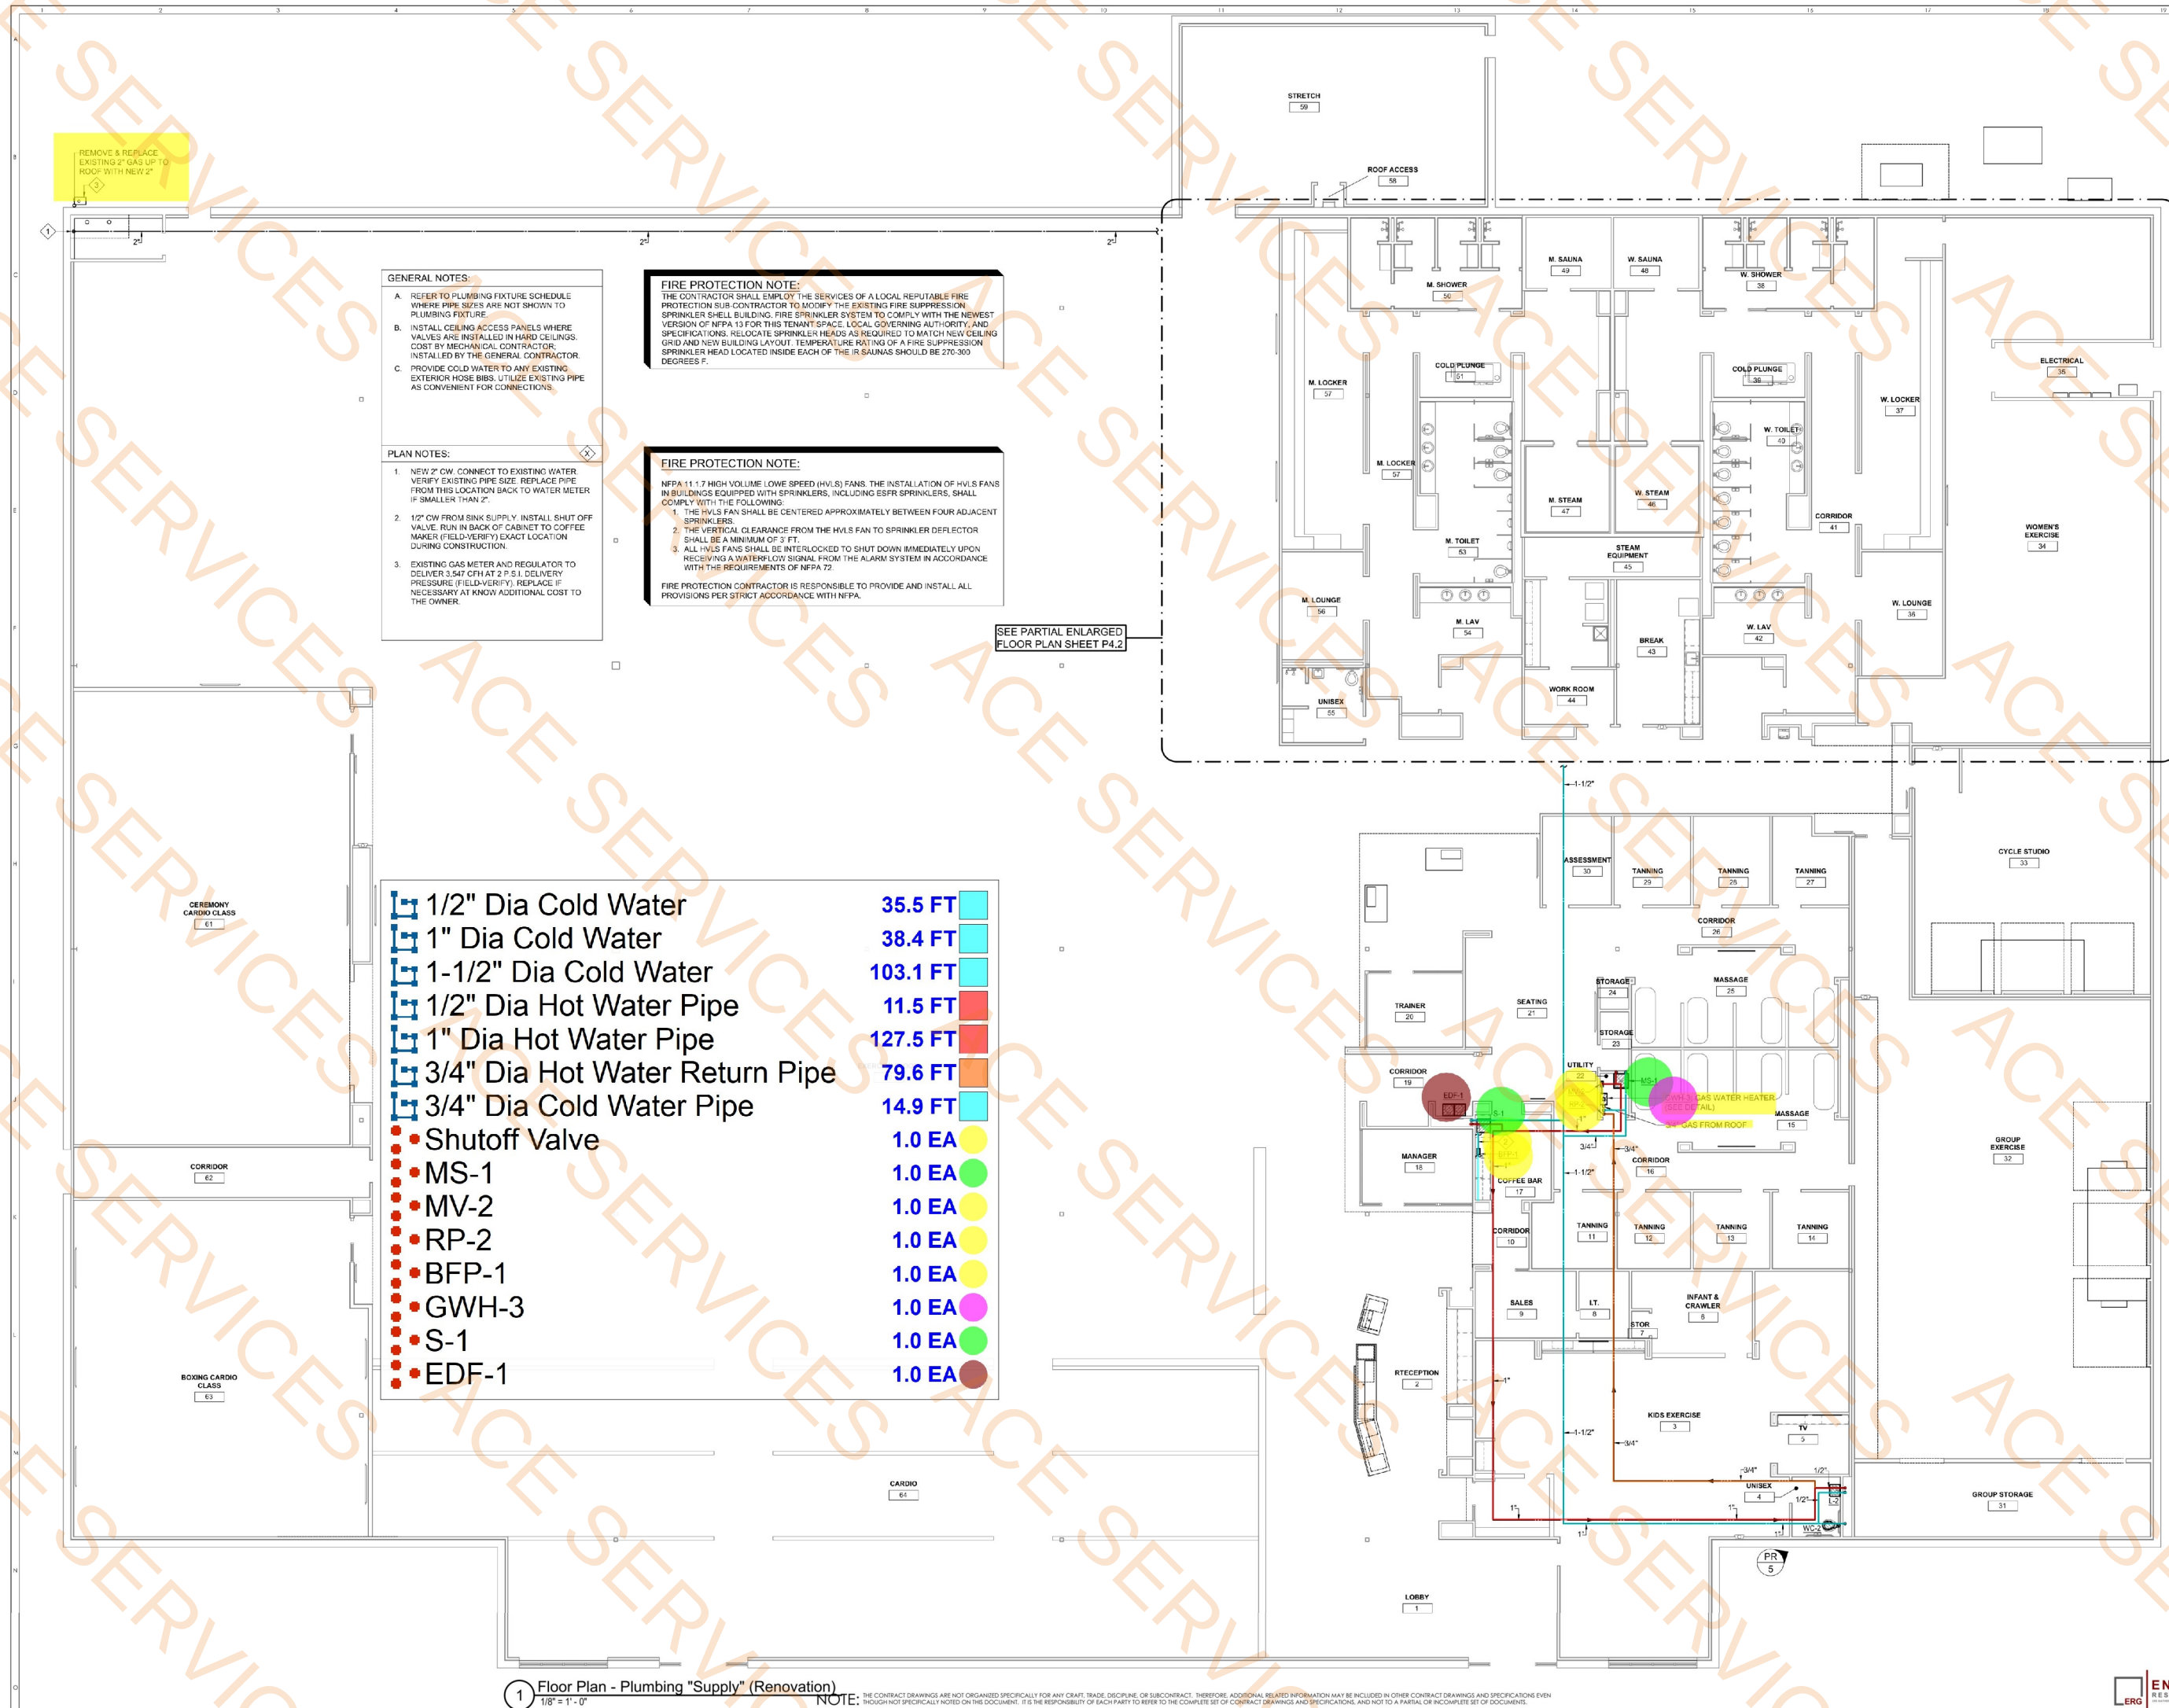

NOTE: THE CONTRACT DRAWINGS ARE NOT ORGANIZED SPECIFICALLY FOR ANY CRAFT, TRADE, DISCIPLINE, OR SUBCONTRACT. THEREFORE, ADDITIONAL RELATED INFORMATION MAY BE INCLUDED IN OTHER CONTRACT DRAWINGS AND SPECIFICATIONS EVEN THOUGH NOT SPECIFICALLY NOTED ON THIS DOCUMENT. IT IS THE RESPONSIBILITY OF EACH PARTY TO REFER TO THE COMPLETE SET OF CONTRACT DRAWINGS AND SPECIFICATIONS, AND NOT TO A PARTIAL OR INCOMPLETE SET OF DOCUMENTS.

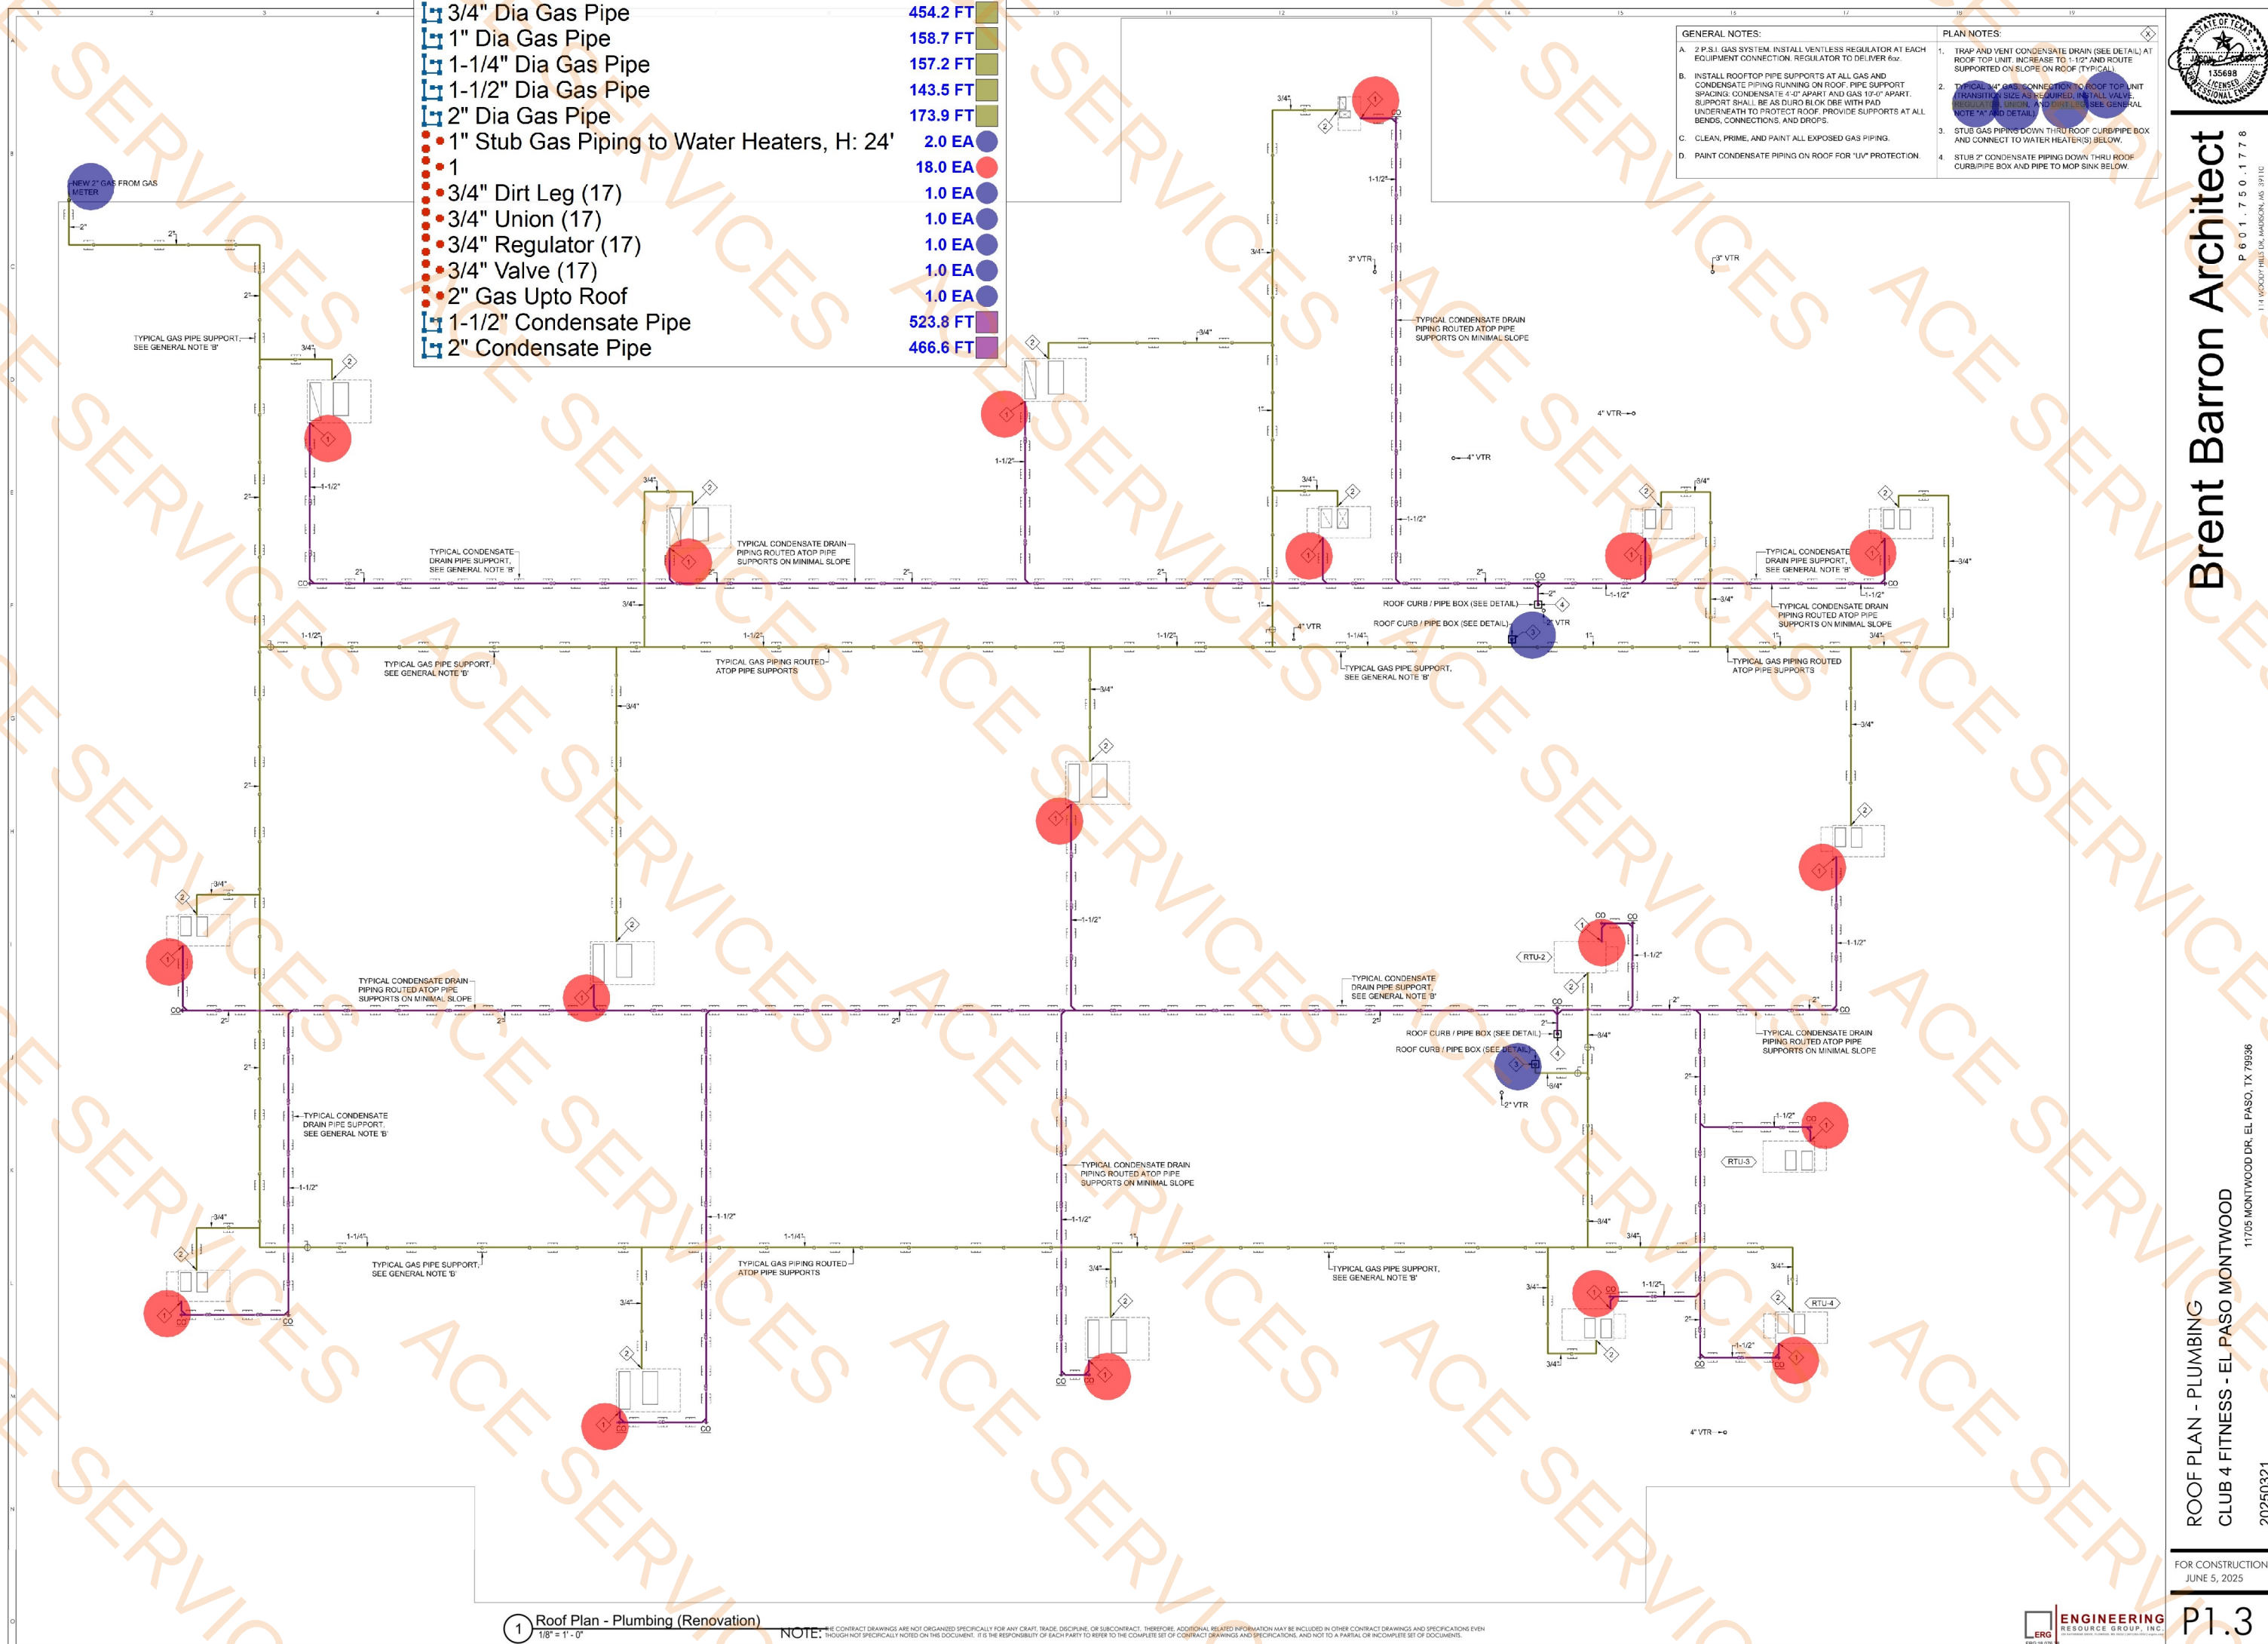





14 WOODY HILLS DR, MADISON, MS 39110

11705 MONTWOOD DR, EL PASO, TX 79936

FOR CONSTRUCTION
JUNE 5, 2025

P4.1

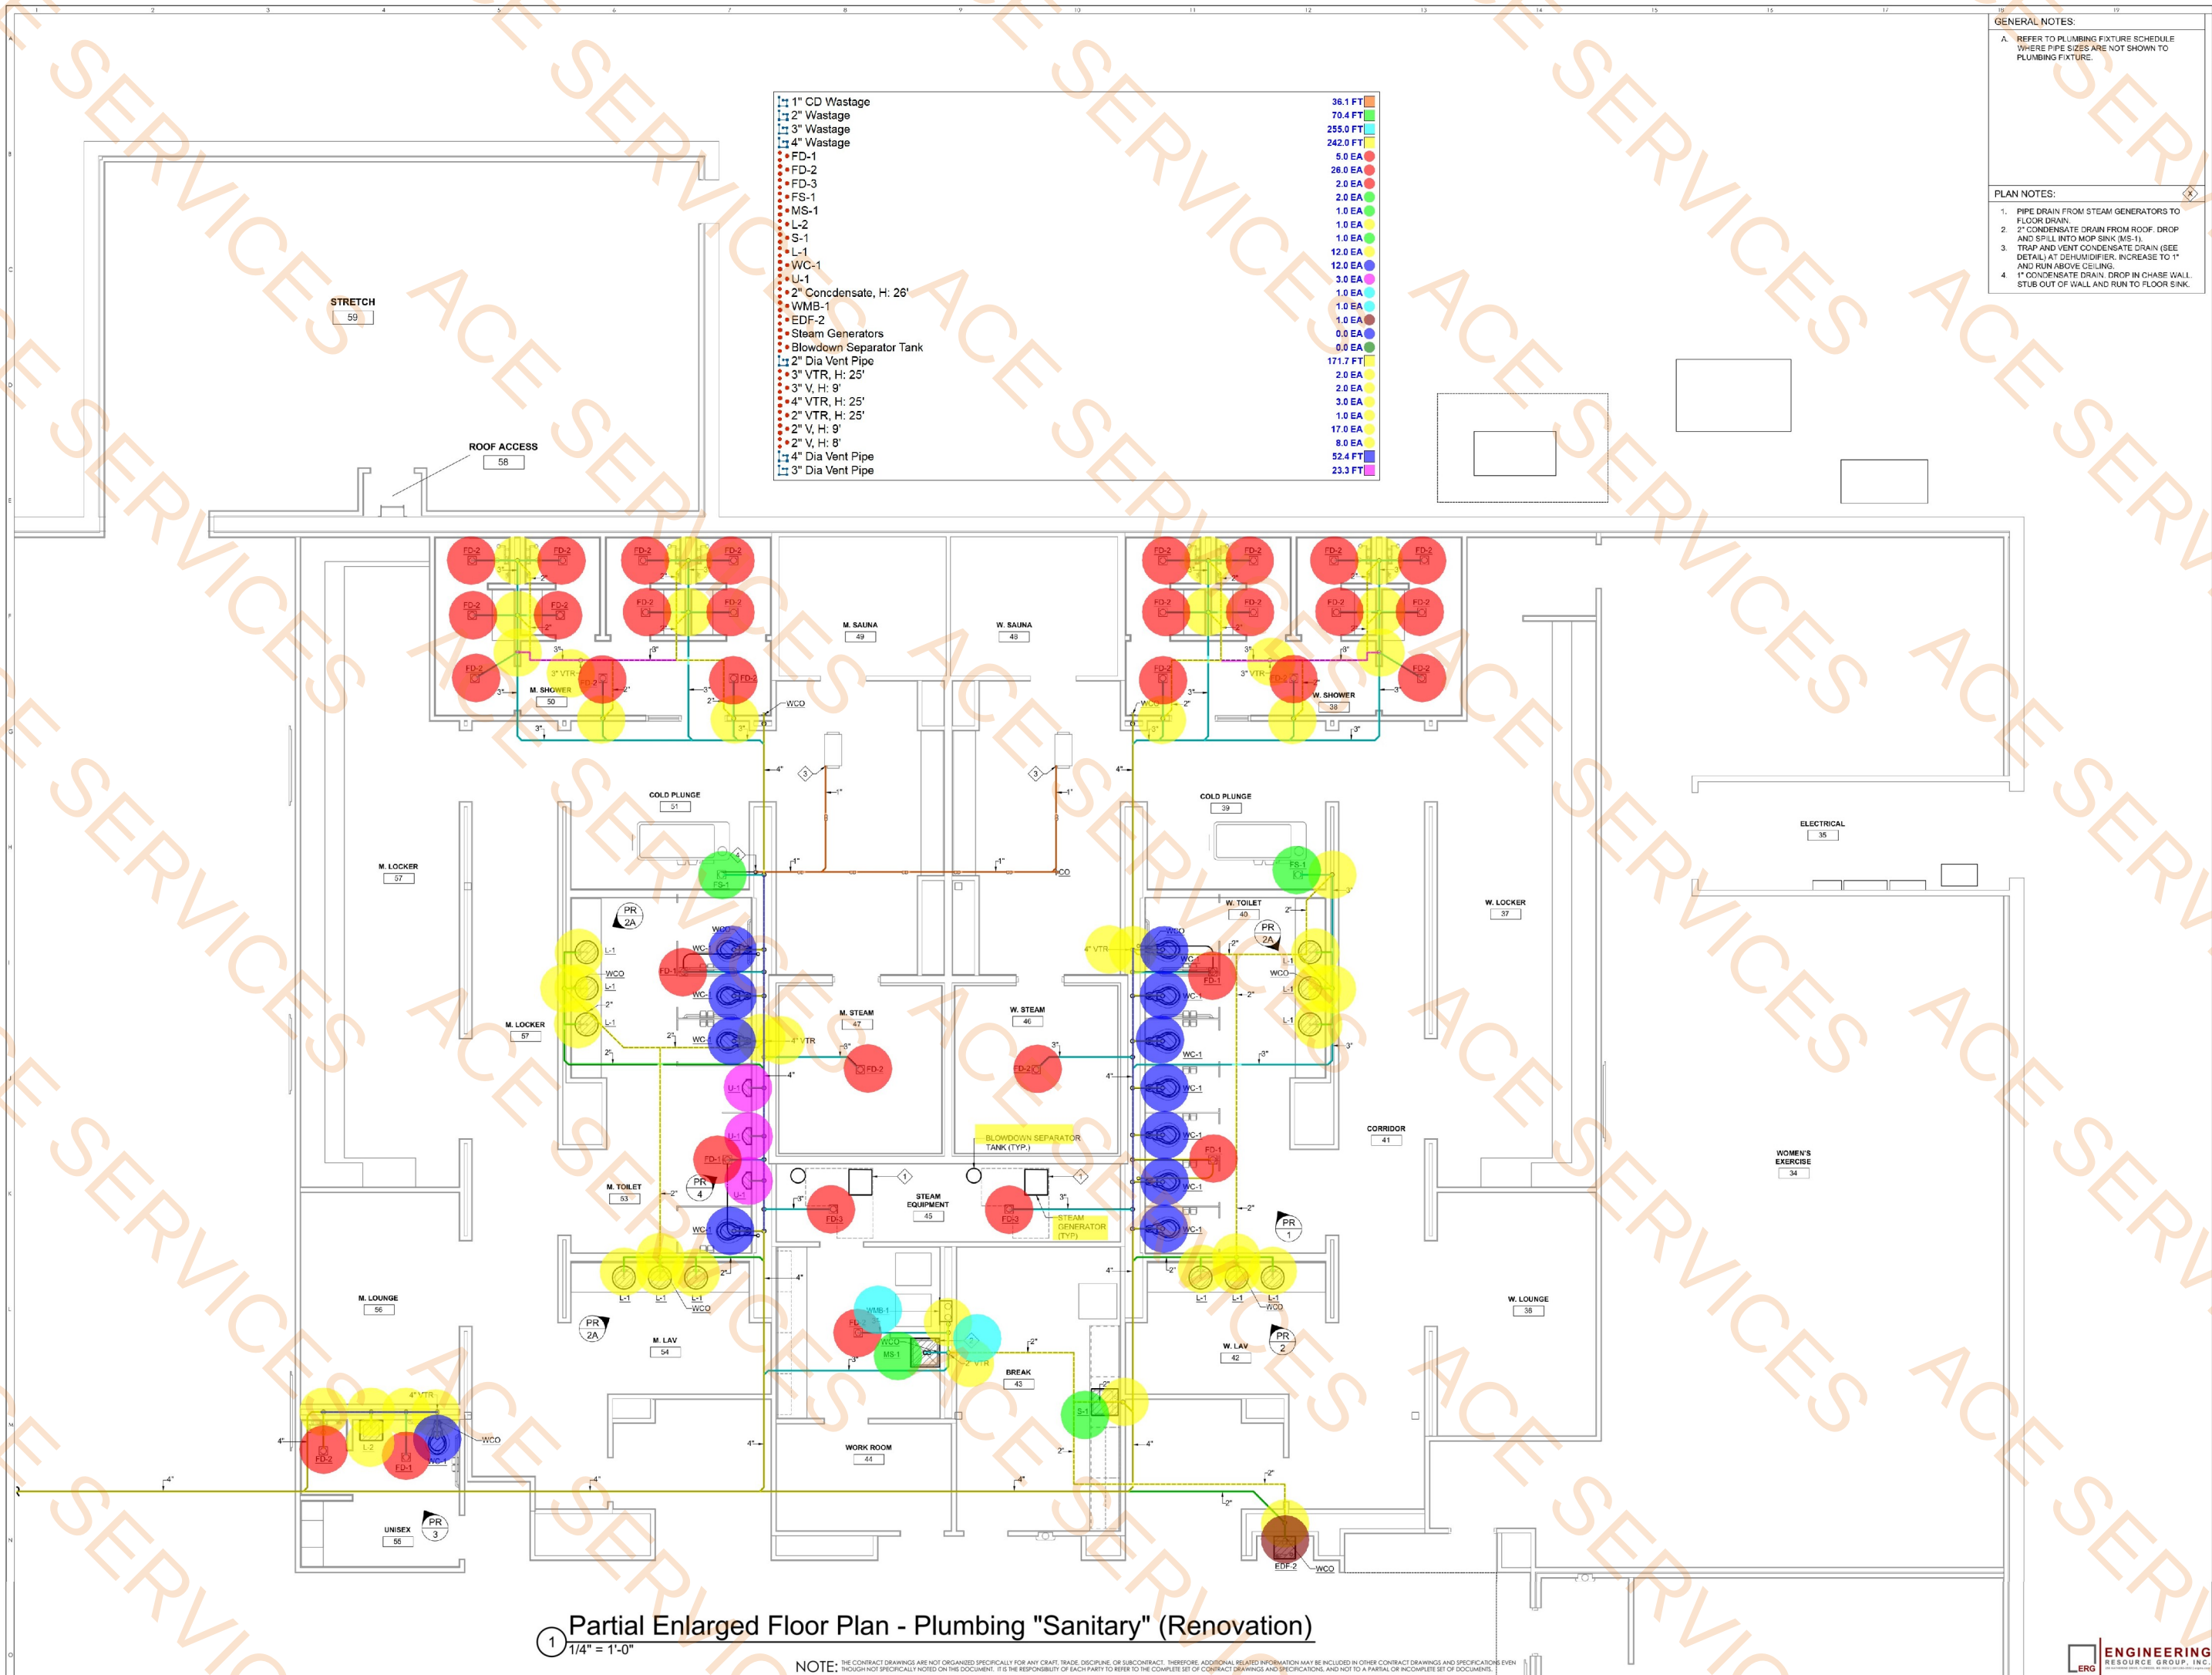

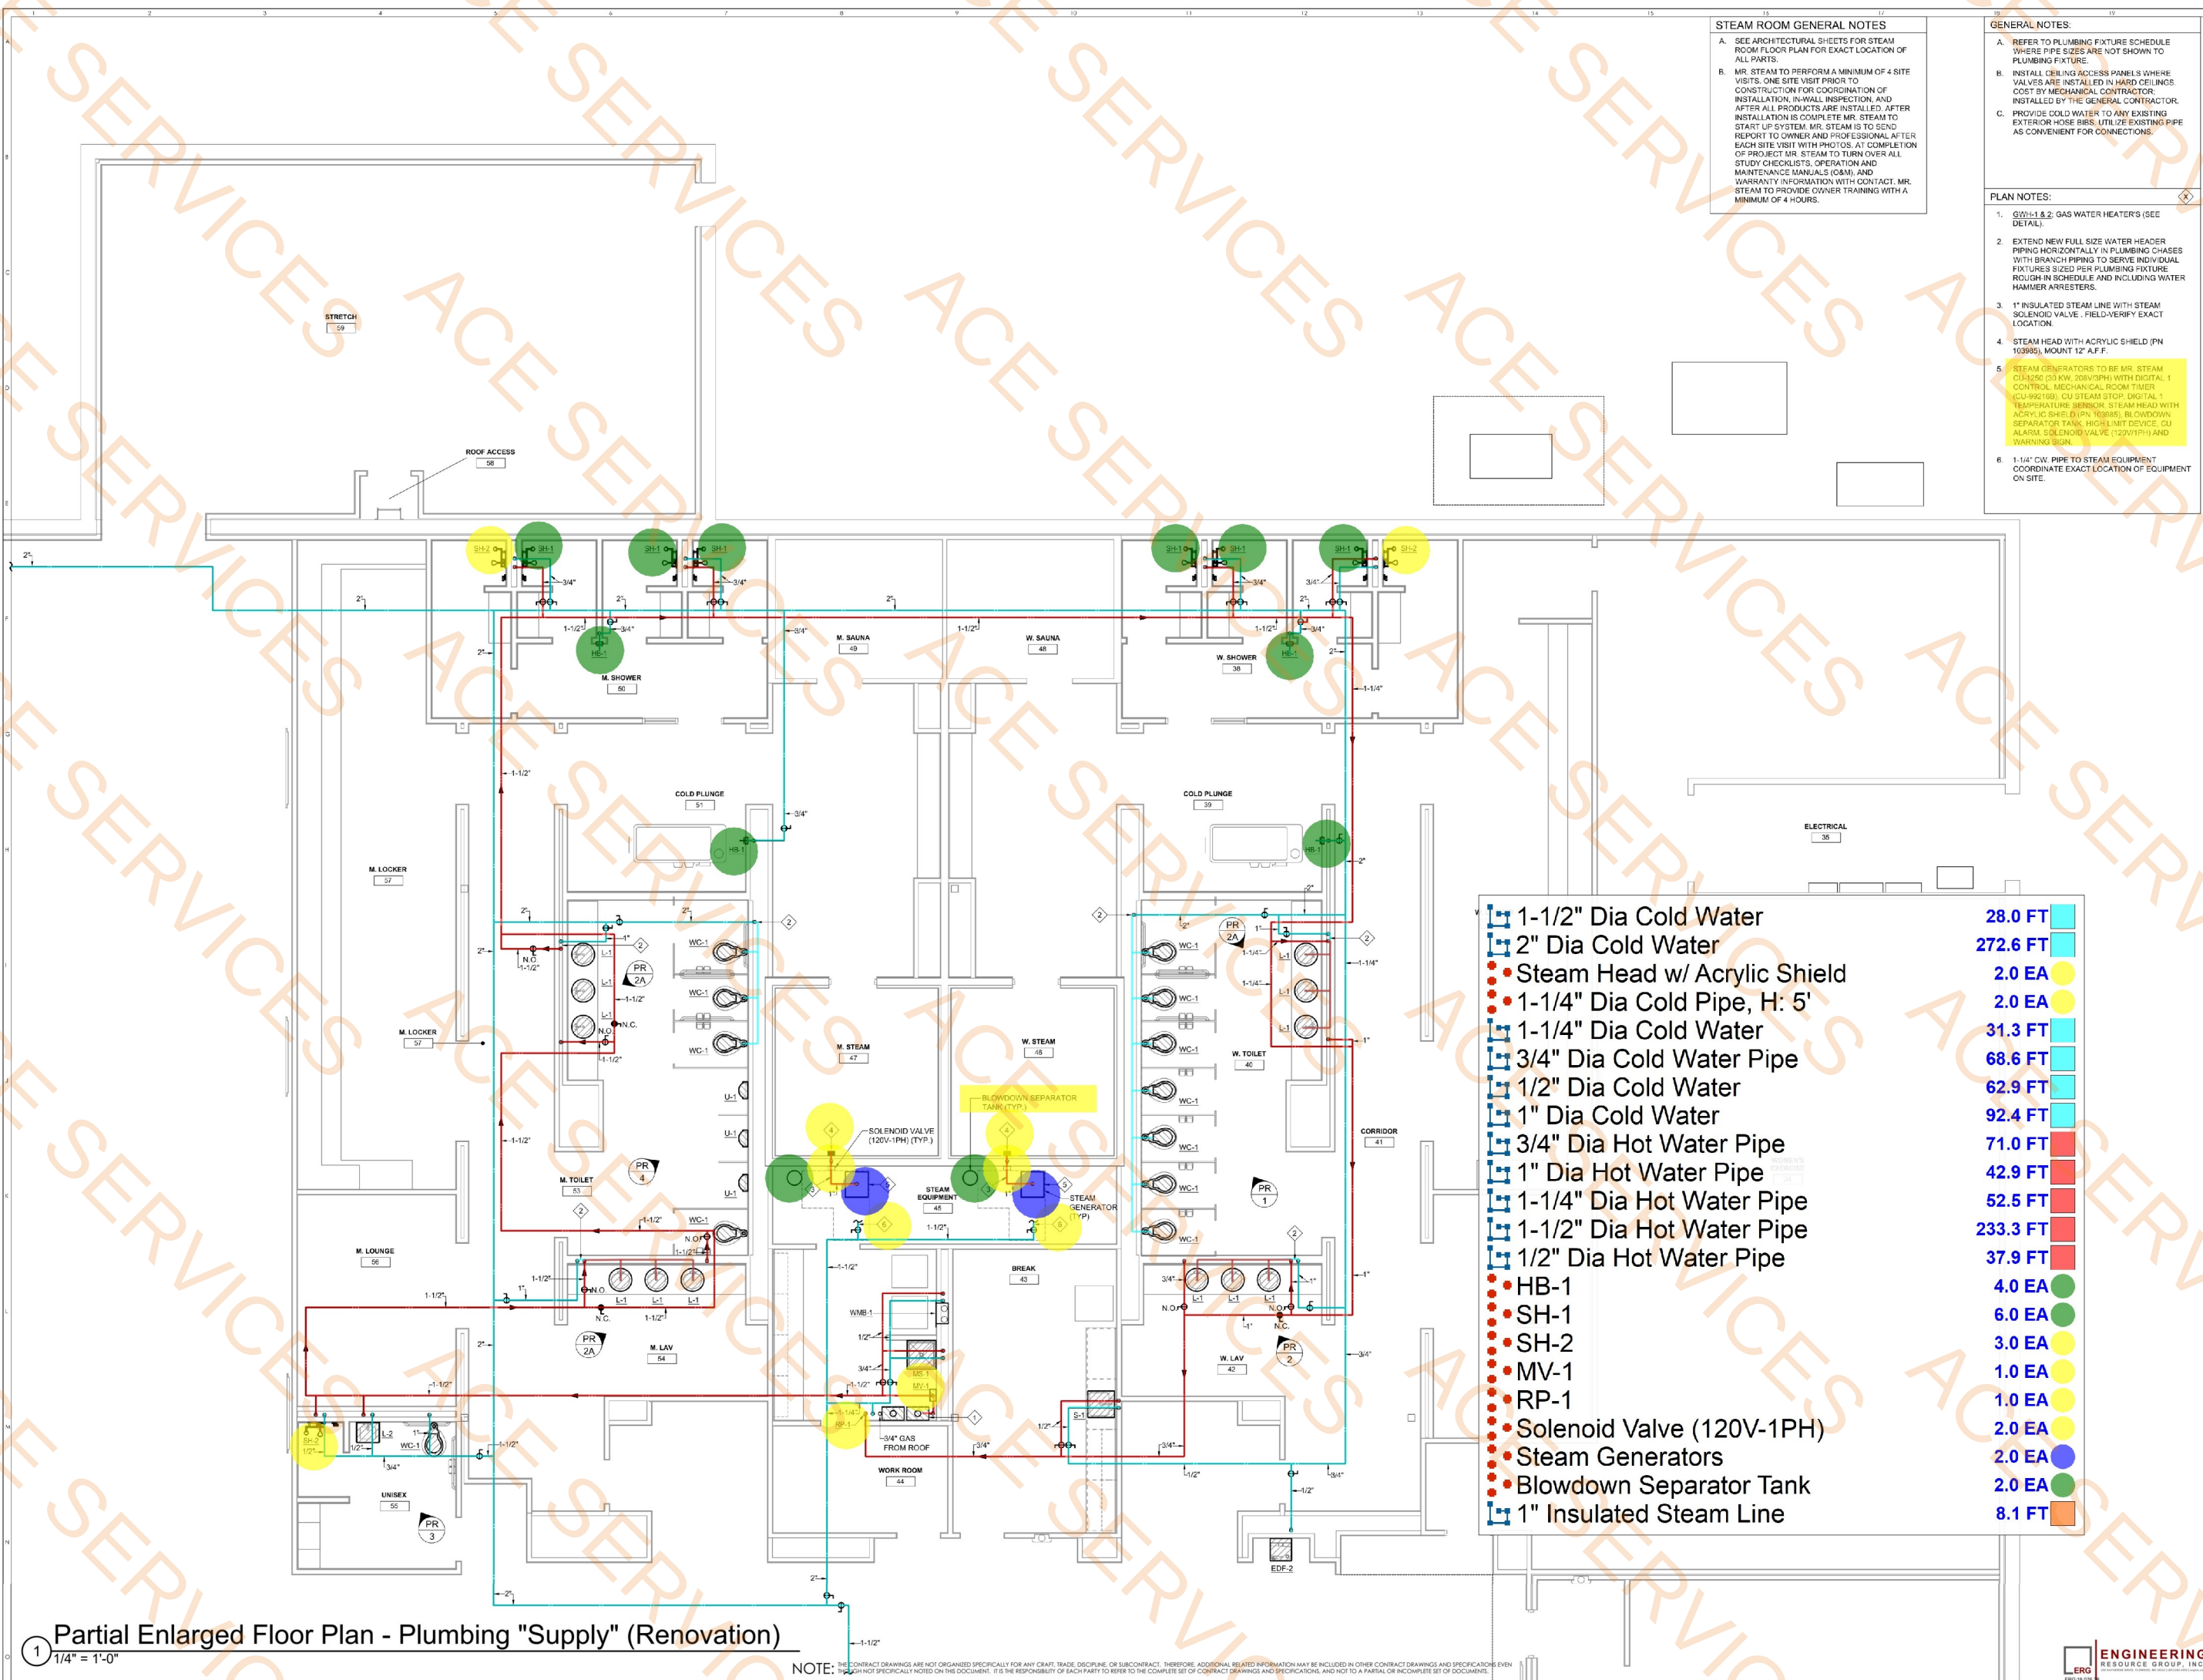

STEAM ROOM GENERAL NOTES

A. SEE ARCHITECTURAL SHEETS FOR STEAM ROOM FLOOR PLAN FOR EXACT LOCATION OF PLUMBING FIXTURE.

B. MR. STEAM TO PERFORM A MINIMUM OF 4 SITE VISITS. ONE SITE VISIT PRIOR TO CONSTRUCTION FOR COORDINATION OF INSTALLATION, IN-WALL INSPECTION, AND AFTER ALL PRODUCTS ARE INSTALLED. AFTER INSTALLATION IS COMPLETE MR. STEAM TO START UP SYSTEM. MR. STEAM IS TO SEND REPORT TO OWNER AND PROFESSIONAL AFTER EACH SITE VISIT WITH PHOTOS. AT COMPLETION OF PROJECT MR. STEAM TO TURN OVER ALL STUDY CHECKLISTS, OPERATION AND MAINTENANCE MANUALS (O&M), AND WARRANTY INFORMATION WITH CONTACT. MR. STEAM TO PROVIDE OWNER TRAINING WITH A MINIMUM OF 4 HOURS.

GENERAL NOTES:

A. REFER TO PLUMBING FIXTURE SCHEDULE WHERE PIPE SIZES ARE NOT SHOWN TO PLUMBING FIXTURE.

B. INSTALL CEILING ACCESS PANELS WHERE VALVES ARE INSTALLED IN HARD CEILINGS COST BY MECHANICAL CONTRACTOR. INSTALLED BY THE GENERAL CONTRACTOR.

C. PROVIDE COLD WATER TO ANY EXISTING EXTERIOR HOSE BIBS. UTILIZE EXISTING PIPE AS CONVENIENT FOR CONNECTIONS.

PLAN NOTES:

1. GWH-1 & 2: GAS WATER HEATERS (SEE DETAIL).

2. EXTEND NEW FULL SIZE WATER HEADER PIPING HORIZONTALLY IN PLUMBING CHASES WITH BRANCH PIPING TO SERVE INDIVIDUAL FIXTURES SIZED PER PLUMBING FIXTURE SCHEDULE AND INCLUDING WATER HAMMER ARRESTERS.

3. 1" INSULATED STEAM LINE WITH STEAM SOLENOID VALVE. FIELD-VERIFY EXACT LOCATION.

4. STEAM HEAD WITH ACRYLIC SHIELD (PN 103985), MOUNT 12" A.F.F.

5. STEAM GENERATORS TO BE MR. STEAM CU-1250 (30 KW, 208V/3PH) WITH DIGITAL 1 CONTROL, MECHANICAL ROOM TIER (CU-88216B), CU STEAM STOP, DIGITAL 1 TEMPERATURE SENSOR, STEAM HEAD WITH ACRYLIC SHIELD (PN 103985), BLOWDOWN SEPARATOR TANK, HIGH LIMIT DEVICE, CU ALARM, SOLENOID VALVE (120V/1PH) AND WARNING SIGN.












6. 1-1/4" CW PIPE TO STEAM EQUIPMENT. COORDINATE EXACT LOCATION OF EQUIPMENT ON SITE.

1-1/2" Dia Cold Water	28.0 FT
2" Dia Cold Water	272.6 FT
Steam Head w/ Acrylic Shield	2.0 EA
1-1/4" Dia Cold Pipe, H: 5'	2.0 EA
1-1/4" Dia Cold Water	31.3 FT
3/4" Dia Cold Water Pipe	68.6 FT
1/2" Dia Cold Water	62.9 FT
1" Dia Cold Water	92.4 FT
3/4" Dia Hot Water Pipe	71.0 FT
1" Dia Hot Water Pipe	42.9 FT
1-1/4" Dia Hot Water Pipe	52.5 FT
1-1/2" Dia Hot Water Pipe	233.3 FT
1/2" Dia Hot Water Pipe	37.9 FT
HB-1	4.0 EA
SH-1	6.0 EA
SH-2	3.0 EA
MV-1	1.0 EA
RP-1	1.0 EA
Solenoid Valve (120V-1PH)	2.0 EA
Steam Generators	2.0 EA
Blowdown Separator Tank	2.0 EA
1" Insulated Steam Line	8.1 FT

Partial Enlarged Floor Plan - Plumbing "Supply" (Renovation)

1/4" = 1'-0"

NOTE: THE CONTRACT DRAWINGS ARE NOT ORGANIZED SPECIFICALLY FOR ANY CRAFT, TRADE, DISCIPLINE, OR SUBCONTRACT. THEREFORE, ADDITIONAL RELATED INFORMATION MAY BE INCLUDED IN OTHER CONTRACT DRAWINGS AND SPECIFICATIONS EVEN IF NOT SPECIFICALLY NOTED ON THIS DOCUMENT. IT IS THE RESPONSIBILITY OF EACH PARTY TO REFER TO THE COMPLETE SET OF CONTRACT DRAWINGS AND SPECIFICATIONS, AND NOT TO A PARTIAL OR INCOMPLETE SET OF DOCUMENTS.

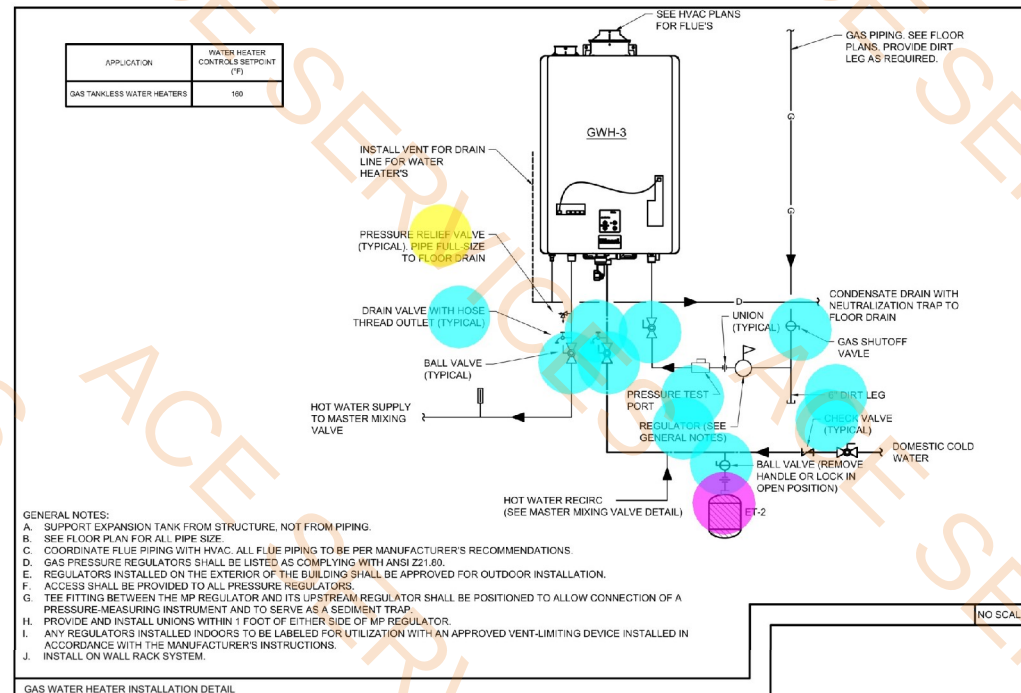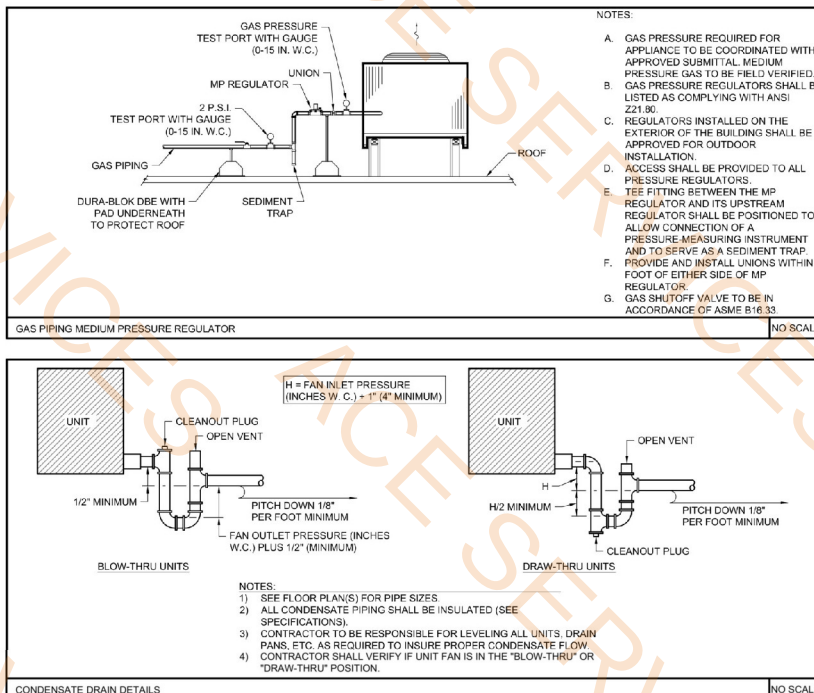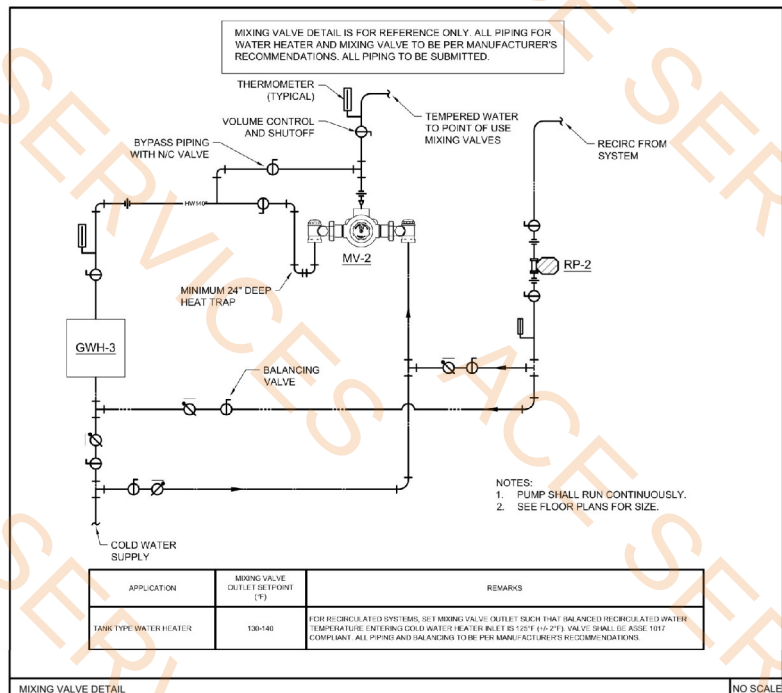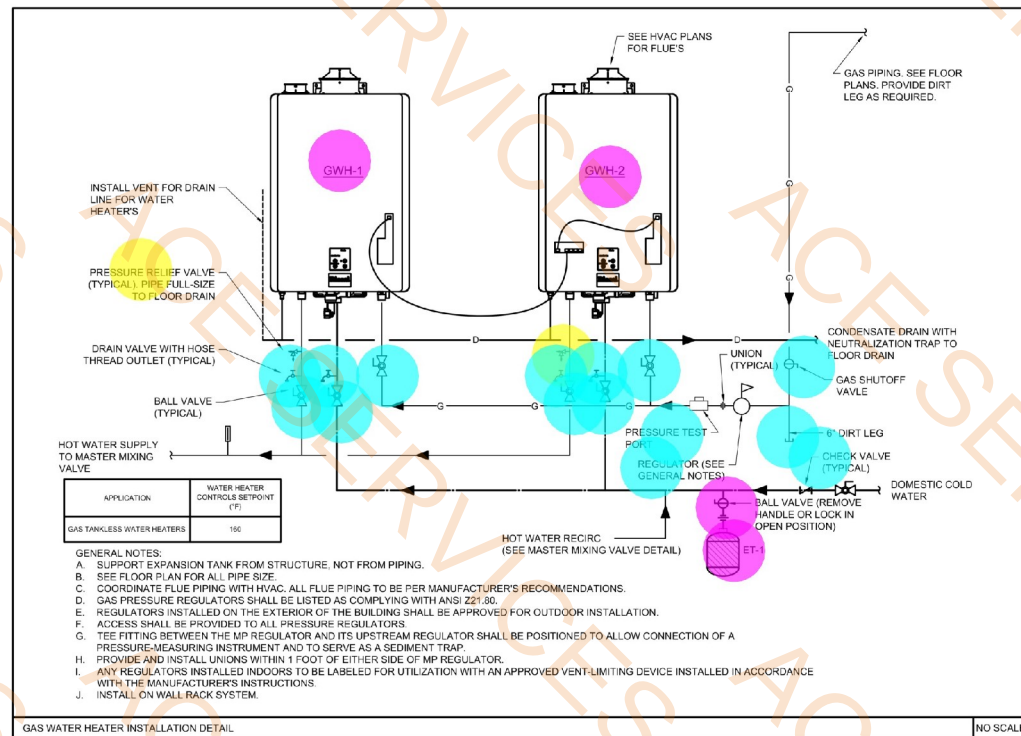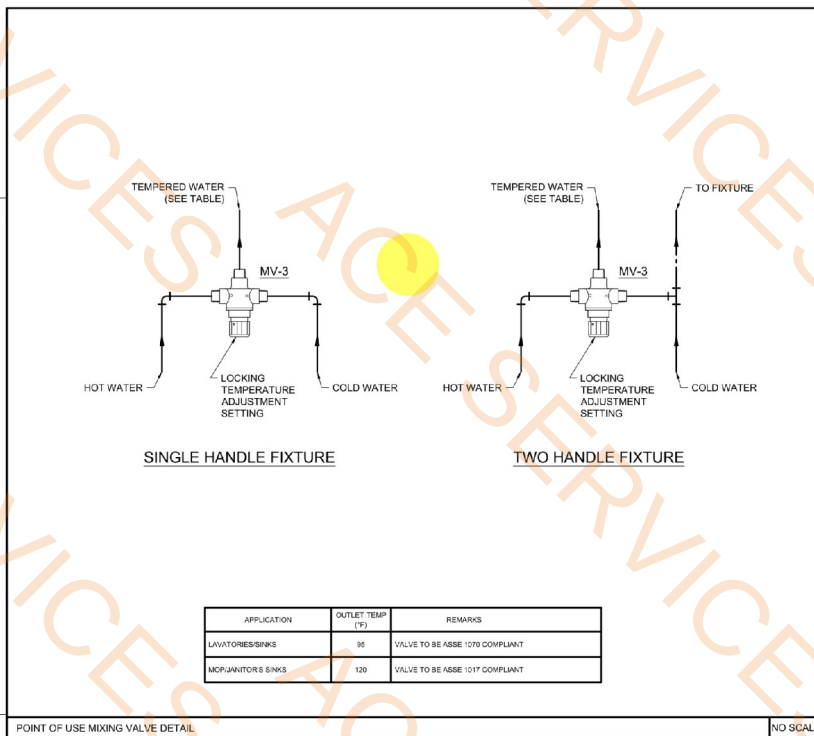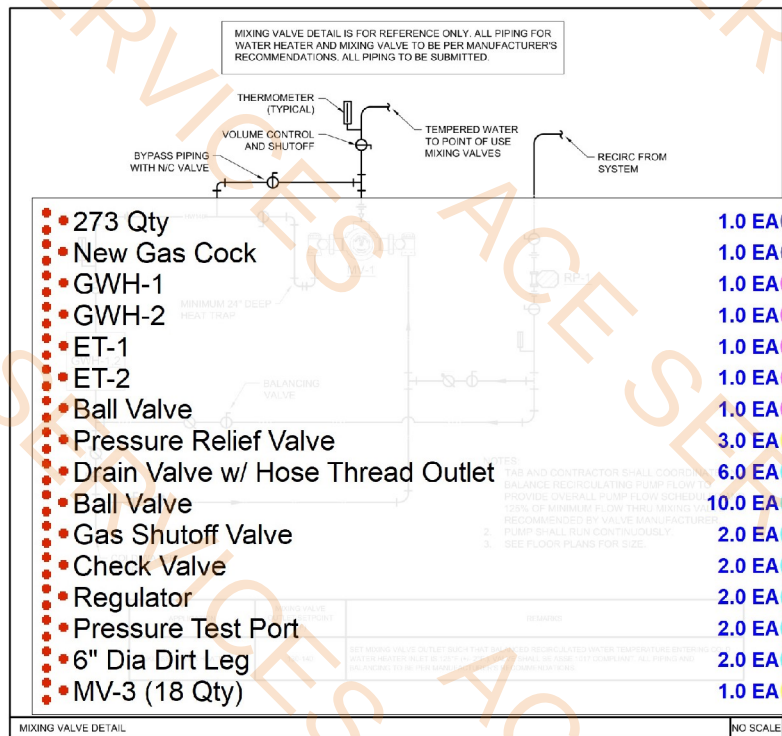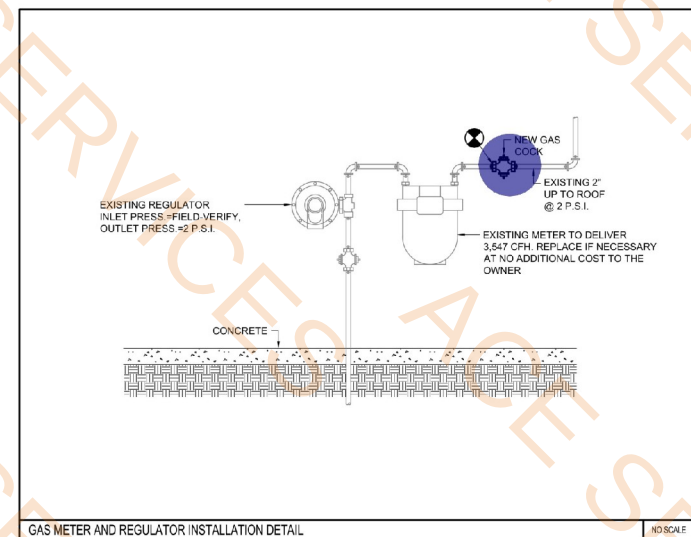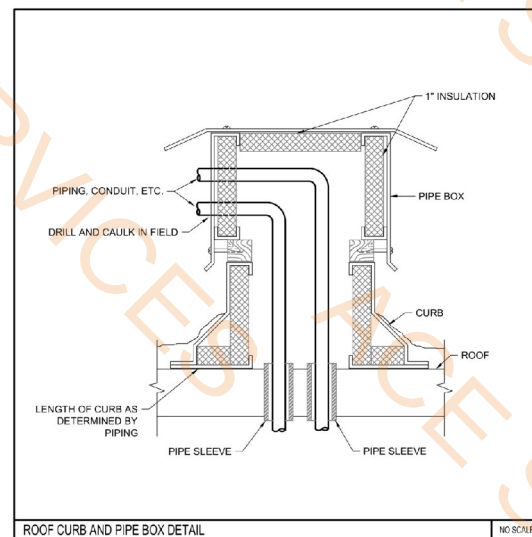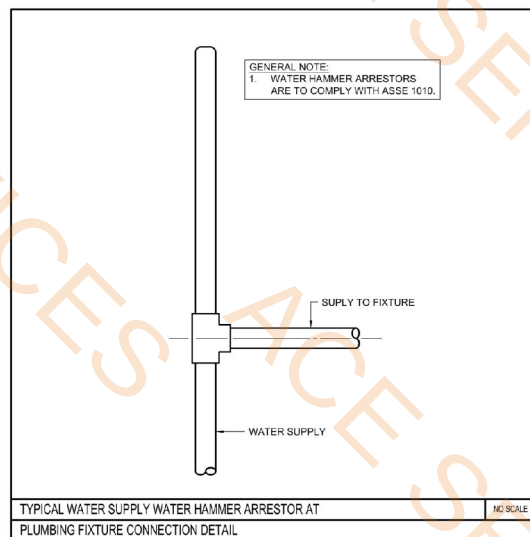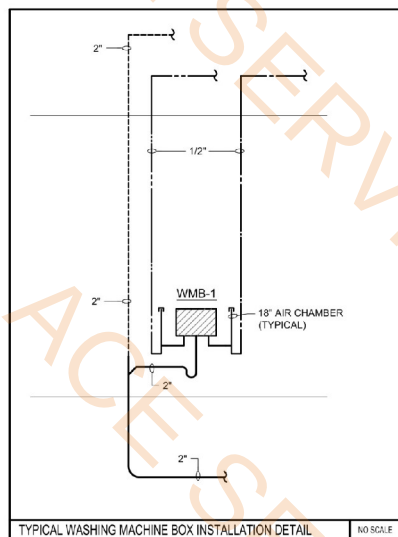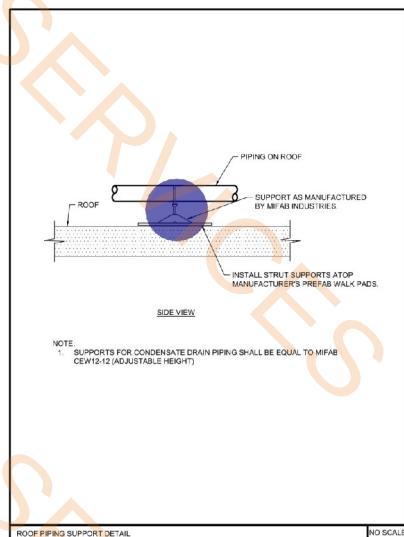



Brent Barron Architect

P 6 0 1 . 7 5 0 . 1 7 7 8

114 WOODY HILL DR. AUSTON, MS 39110

11705 MONTWOOD DR. EL PASO, TX 79936

PLUMBING DETAILS / RISERS
CLUB 4 FITNESS - EL PASO MONTWOOD


20250321

FOR CONSTRUCTION
JUNE 5, 2025

P5.2




NOTE: THE CONTRACT DRAWINGS ARE NOT ORGANIZED SPECIFICALLY FOR ANY CRAFT, TRADE, DISCIPLINE, OR SUBCONTRACT. THEREFORE, ADDITIONAL RELATED INFORMATION MAY BE INCLUDED IN OTHER CONTRACT DRAWINGS AND SPECIFICATIONS EVEN THOUGH NOT SPECIFICALLY NOTED ON THIS DOCUMENT. IT IS THE RESPONSIBILITY OF EACH PARTY TO REFER TO THE COMPLETE SET OF CONTRACT DRAWINGS AND SPECIFICATIONS, AND NOT TO A PARTIAL OR INCOMPLETE SET OF DOCUMENTS.

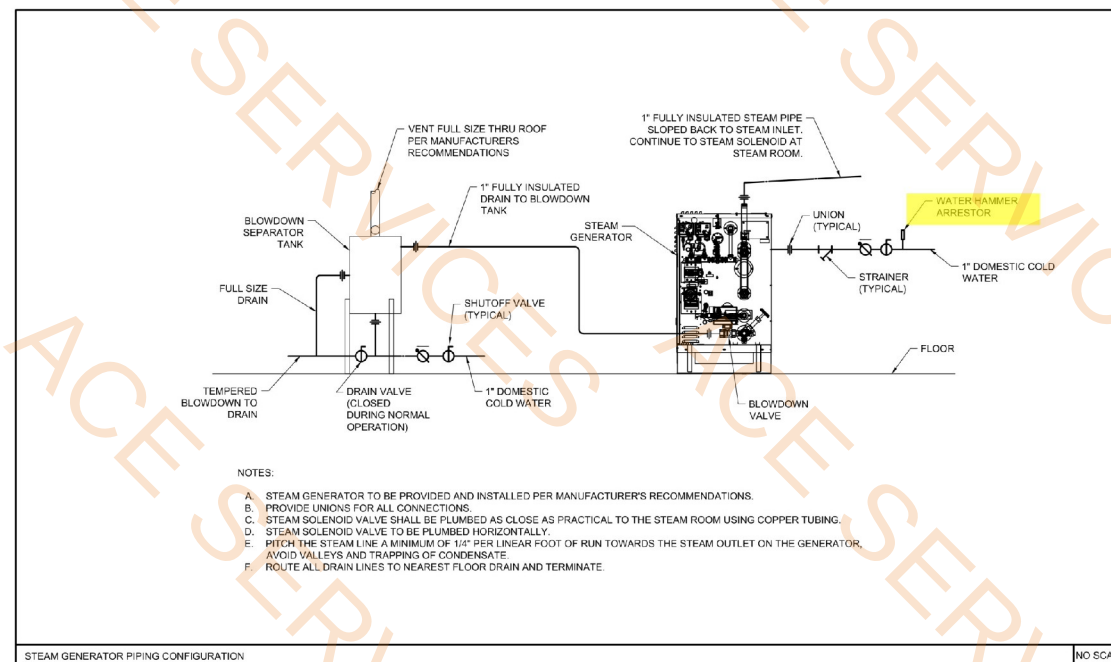

- NOTES:
- A. STEAM GENERATOR TO BE PROVIDED AND INSTALLED PER MANUFACTURER'S RECOMMENDATIONS.
 - B. PROVIDE UNIONS FOR ALL CONNECTIONS.
 - C. STEAM SOLENOID VALVE SHALL BE PLUMBED AS CLOSE AS PRACTICAL TO THE STEAM ROOM USING COPPER TUBING.
 - D. STEAM SOLENOID VALVE TO BE PLUMBED HORIZONTALLY.
 - E. PITCH THE STEAM LINE A MINIMUM OF 1/4" PER LINEAR FOOT OF RUN TOWARDS THE STEAM OUTLET ON THE GENERATOR. AVOID VALLEYS AND TRAPPING OF CONDENSATE.
 - F. ROUTE ALL DRAIN LINES TO NEAREST FLOOR DRAIN AND TERMINATE.

STEAM GENERATOR PIPING CONFIGURATION


NO SCALE

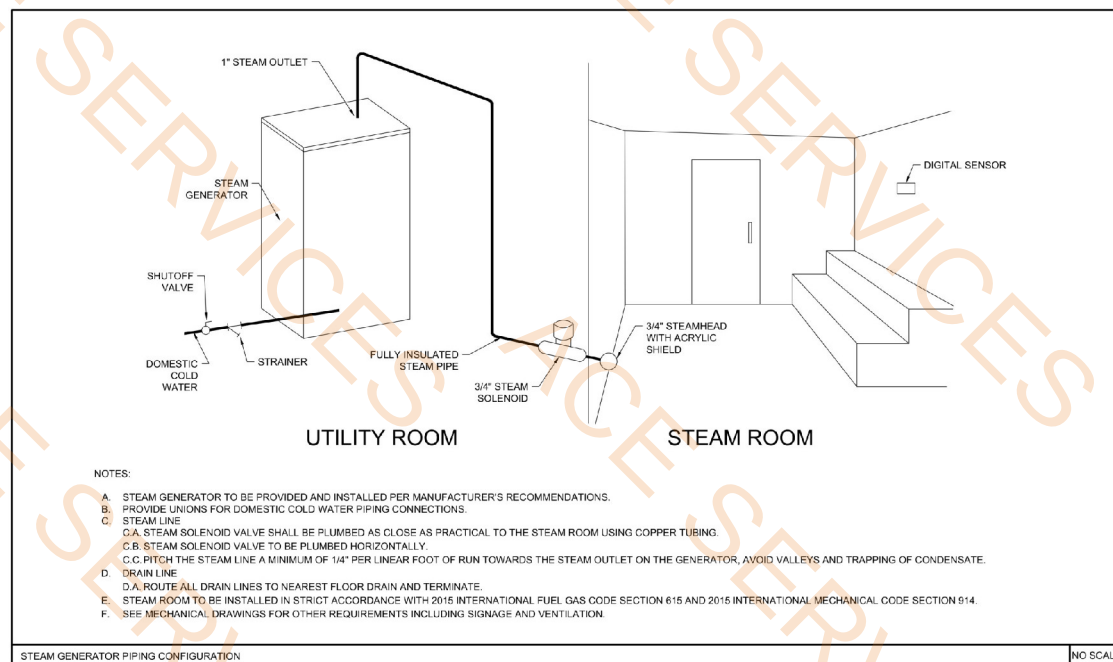


- NOTES:
- A. STEAM GENERATOR TO BE PROVIDED AND INSTALLED PER MANUFACTURER'S RECOMMENDATIONS.
 - B. PROVIDE UNIONS FOR DOMESTIC COLD WATER PIPING CONNECTIONS.
 - C. STEAM LINE
 - C.A. STEAM SOLENOID VALVE SHALL BE PLUMBED AS CLOSE AS PRACTICAL TO THE STEAM ROOM USING COPPER TUBING.
 - C.B. STEAM SOLENOID VALVE TO BE PLUMBED HORIZONTALLY.
 - C.C. PITCH THE STEAM LINE A MINIMUM OF 1/4" PER LINEAR FOOT OF RUN TOWARDS THE STEAM OUTLET ON THE GENERATOR. AVOID VALLEYS AND TRAPPING OF CONDENSATE.
 - D. DRAIN LINE
 - D.A. ROUTE ALL DRAIN LINES TO NEAREST FLOOR DRAIN AND TERMINATE.
 - E. STEAM ROOM TO BE INSTALLED IN STRICT ACCORDANCE WITH 2015 INTERNATIONAL FUEL GAS CODE SECTION 615 AND 2015 INTERNATIONAL MECHANICAL CODE SECTION 614.
 - F. SEE MECHANICAL DRAWINGS FOR OTHER REQUIREMENTS INCLUDING SIGNAGE AND VENTILATION.

STEAM GENERATOR PIPING CONFIGURATION

NO SCALE


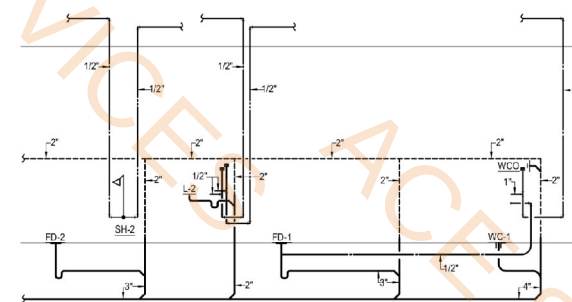


PR-3

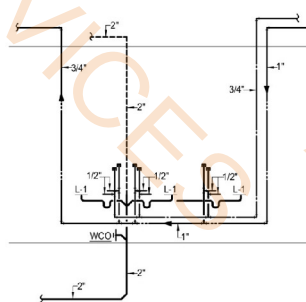


PR-2A SIMILAR:
JUST MIRRORRED

PR-5

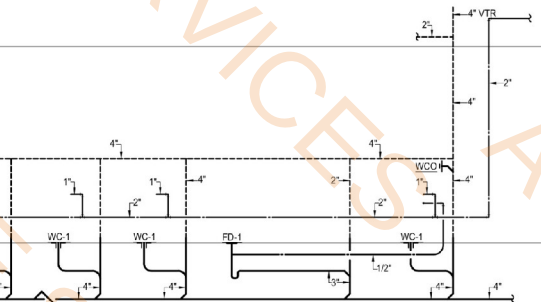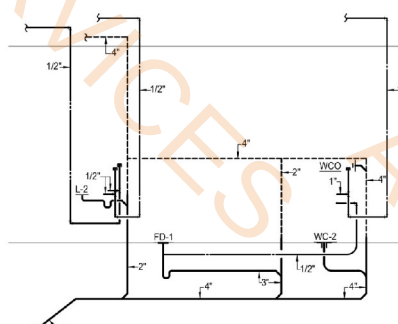

PR-1

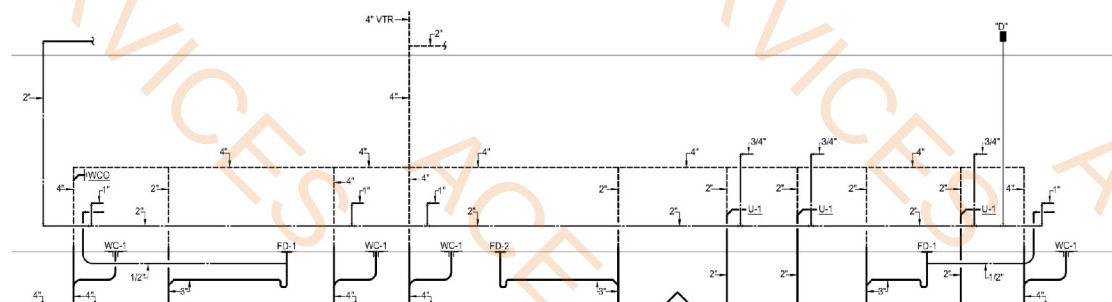

PR-4

PLUMBING FIXTURE SCHEDULE

MARK	DESCRIPTION	MAKE	MODEL	SUPPLY FITTING	SUPPLY PIPE(S)	DRAIN	TRAP	GPM	MIXING VALVE	ROUGH-IN SIZES				REMARKS
										C.W.	H.W.	WASTE	VENT	
WC-1	WATER CLOSET, FLR MTD. MANUAL F.V., A.D.A. TRAP PRIMER	KOHLER	K-98057-0	ZURN Z8000PL-HET	---	---	---	1.28	---	1"	--	4"	4"	W/ OPEN FRONT WHITE SEAT EQUAL TO BEM'S 1555SCT (SELF-SUSTAINING HINGES WITH STAINLESS STEEL POST AND PINTLES); TRAP PRIMER CONNECTION. MODIFY HEIGHT OF FLUSH VALVE AS REQUIRED FOR HANDRAIL.
WC-2	CHILD HEIGHT WATER CLOSET, FLR MTD., MANUAL F.V., A.D.A., TRAP PRIMER	KOHLER	K-99064	ZURN Z8000PL-HET	---	---	---	1.28	---	1"	--	4"	4"	W/ KOHLER K-4686-A WHITE SEAT, BOLT CAPS, TRAP PRIMER CONNECTION. MODIFY HEIGHT OF FLUSH VALVE AS REQUIRED FOR HANDRAIL.
U-1	URINAL, WALL HUNG, MANUAL F.V.	KOHLER	K-4991-ET	ZURN Z8003PL-EWS	---	---	---	0.5	---	3/4"	--	2"	2"	SEE ARCHITECTURE PLANS FOR MOUNTING HEIGHT.
L-1	LAVATORY, UNDER MOUNT, MANUAL FAUCET, A.D.A.	KOHLER	K-Z210	ZURN Z82200-XL	ZURN Z8604-XL-LRCE-PC	ZURN Z8743-PC	ZURN Z8700B-PC	0.5	MV-3	1/2"	1/2"	2"	2"	LESS POP UP DRAIN.
L-2	LAVATORY, WALL HUNG, 20" X 18", A.D.A., MANUAL FAUCET	KOHLER	K-2007	ZURN Z81104-XL-3M	ZURN Z8604-XL-LRCE-PC	ZURN Z8743-PC	ZURN Z8700B-PC	0.5	MV-3	1/2"	1/2"	2"	2"	INSULATE P-TRAP AND SUPPLY PIPES WITH TRUEBRO 1020/105. LESS POP-UP DRAIN.
S-1	SINK, SINGLE COMP. 5/5, 18-1/2" X 18-1/2"	ELKAY	ELUHAD161855PD	ZURN Z831A4-XL-ICT	ZURN Z8604-XL-LRCE-PC	PERFECT DRAIN	ZURN Z8700B-PC	---	MV-3	1/2"	1/2"	2"	2"	---
S-2	SINK, DOUBLE COMP. 5/5, 30-3/4" X 18-1/2"	ELKAY	ELUH3118PD	DELTA 9179-DST	ZURN Z8604-XL-LRCE-PC	PERFECT DRAIN	ZURN Z8700B-PC	1.8	MV-3	1/2"	1/2"	2"	2"	---
EDF-1	ELECTRIC DRINKING FOUNTAIN BILEVEL, BOTTLE FILLING STATION, A.D.A.	ELKAY	LZ5TL6W5LP	---	---	---	---	---	---	1/2"	---	2"	2"	FURNISHED WITH EZH20 BOTTLE FILLING STATION.
EDF-2	ELECTRIC DRINKING FOUNTAIN, BOTTLE FILLING STATION, A.D.A.	ELKAY	LZ58WSSP	---	---	---	---	---	---	1/2"	---	2"	2"	FURNISHED WITH EZH20 BOTTLE FILLING STATION.
SH-1	SHOWER HEAD, MIXING VALVE	DELTA	52672-15-BG	T13291-LHD	---	---	---	1.5	---	1/2"	1/2"	2"	2"	---
SH-2	SHOWER HEAD, A.D.A. SLIDE HAND SHOWER, MIXING VALVE	DELTA	52672-15-BG	T13291-LHD	---	---	---	1.5	---	1/2"	1/2"	2"	2"	PROVIDE & INSTALL RP16540 ESCUTCHEON, 351055A HANDLE WITH SCREW & BUTTON U4960-PK WALL SUPPLY ELBOW, 52003-D5 ADA SLIDE/GRAB BAR, HOSE & HAND SHOWER.
MS-1	MOP BASIN 36" x 24" x 10"	STERN WILLIAMS	MTB-3624	TV-15-VB	---	---	KOHLER K-6673	---	MV-3	1/2"	1/2"	3"	2"	PROVIDE AND INSTALL T-35 HOSE AND WALL HOOK, T-40 STAINLESS STEEL MOP HANGER AND BP SPLASH CATCHER PANELS.
HS-1	HAND SANITIZING STATION 20" X 20" X 22-1/2"	MERITECH	500-C	---	---	---	---	0.5	---	3/4"	3/4"	2"	2"	---
FD-1	SQUARE FLOOR DRAIN - POLISHED BRONZE WITH TRAP PRIMER CONNECTION	ZURN	ZN-415-SB-P	---	---	---	---	---	---	---	---	3"	2"	TOILETS WITH TRAP PRIMER.
FD-2	ROUND FLOOR DRAIN - POLISHED BRONZE	ZURN	Z415	---	---	---	---	---	---	---	---	2"	2"	PROVIDE "SURE SEAL" TRAP GUARD.
FD-3	FLOOR DRAIN - POLISHED BRONZE WITH RECESSED RIM	ZURN	Z9-415-I	---	---	---	---	---	---	---	---	3"	2"	PROVIDE "SURE SEAL" TRAP GUARD.
FS-1	SQUARE FLOOR SINK LESS GRATE	ZURN	Z-1902-K-1	---	---	---	---	---	---	---	---	3"	2"	PROVIDE "SURE SEAL" TRAP GUARD.
TD-1	60" LINEAR TRENCH DRAIN	QM USA, CORP.	88.620 60 PS	---	---	---	---	---	---	---	---	2"	2"	PROVIDE "SURE SEAL" TRAP GUARD AND HAIR STRAINER.
DST-1	DEAP-SEAL P-TRAP	ZURN	Z1000	---	---	---	---	---	---	---	---	2"	2"	FURNISH WITH BRONZE FUNNEL.
WMB-1	WASHING MACHINE BOX	GUY GRAY	WB	---	---	---	---	---	---	1/2"	1/2"	2"	2"	---
HB-1	HOSE BIBB WITH KEY & COVER	WOODFORD	B26	---	---	---	---	---	---	3/4"	---	---	---	TEE KEY PROTECTED, LOCKABLE COVER.
FHB-1	FREEZE PROOF, HOSE BIBB	WOODFORD	B65	---	---	---	---	---	---	3/4"	---	---	---	WITH VACUUM BREAKER.
BFP-1	DUAL CHECK, BACKFLOW PREVENTER	WATTS	LF7C	---	---	---	---	---	---	3/8"	---	---	---	---

NOTES: 1. SHOWER LINERS SHALL BE SLOPED TO THE DRAIN OPENING AT A GRADIENT OF NOT LESS THAN 2% AND SHALL BE TESTED AND INSPECTED BEFORE THE INSTALLTION OF TILE OR OTHER COVERING BY AHJ.

PUMPS

MARK	MAKE AND MODEL	DUTY	TYPE	GPM EACH	PUMP HEAD (FT)	VOLTAGE/PH	MOTOR HP	RPM	REMARKS
RP-1	TACO 0034e	DOMESTIC HOT WATER	RECIRC PUMP	4	26	115/1	ECM	830 - 4300	SEE WATER HEATER DETAIL.
RP-2	TACO 0034e	DOMESTIC HOT WATER	RECIRC PUMP	4	28	115/1	ECM	830 - 4300	SEE WATER HEATER DETAIL.

MIXING VALVE SCHEDULE

MARK	DESCRIPTION	MAKE	MODEL	IN	OUT	MIN. FLOW (GPM)	FLOW / MAX PRESSURE DROP	REMARKS
MV-1	WATER HEATER	LEONARD	XL-S2-LF-BDT	3/4"	1"	1	26 GPM / 10 PSI	MINIMUM FLOW IS NON-RECIRCULATED VALUE. INSTALL AT GWH-1 & 2 WATER HEATER'S.
MV-2	WATER HEATER	LEONARD	LV-20-LF-E-RF-BDT	3/4"	3/4"	1	9 GPM / 10 PSI	MINIMUM FLOW IS NON-RECIRCULATED VALUE. INSTALL AT GWH-3 WATER HEATER.
MV-3	POINT OF USE	LEONARD	170-LF	3/8"	3/8"	0.25	1.7 GPM / 10 PSI	INSTALL BELOW HAND WASH LAVATORY AND SINKS

EXPANSION TANK

MARK	DESCRIPTION	MAKE	MODEL	TANK VOLUME	ACCEPTANCE VOLUME GAL.	REMARKS
ET-1	WATER HEATER EXPANSION TANK	AMTROL	ST-5-C	2.0	.45	INSTALL AT GWH-1 & 2 WATER HEATER'S (SEE DETAIL).
ET-2	WATER HEATER EXPANSION TANK	AMTROL	ST-5-C	2.0	.45	INSTALL AT GWH-3 WATER HEATER (SEE DETAIL).

GAS PIPING TO EQUIPMENT SCHEDULE

TAG	DESCRIPTION	INCOMING GAS PRESSURE	REGULATOR	EQUIPMENT PRESSURE REQUIREMENT	INCOMING BTU	REMARKS
GWH-1	GAS WATER HEATER	2 LBS	YES	6 OZ.	199,000	INSTALL WITH GAS COCK, UNION, AND DIRT LEG
GWH-2	GAS WATER HEATER	2 LBS	YES	6 OZ.	199,000	INSTALL WITH GAS COCK, UNION, AND DIRT LEG
GWH-3	GAS WATER HEATER	2 LBS	YES	6 OZ.	199,000	INSTALL WITH GAS COCK, UNION, AND DIRT LEG
RTU-1	ROOFTOP UNIT	2 LBS	YES	6 OZ.	150,000	INSTALL WITH GAS COCK, UNION, AND DIRT LEG
RTU-2	ROOFTOP UNIT	2 LBS	YES	6 OZ.	150,000	INSTALL WITH GAS COCK, UNION, AND DIRT LEG
RTU-3	ROOFTOP UNIT	---	---	---	COOLING ONLY	---
RTU-4	ROOFTOP UNIT	2 LBS	YES	6 OZ.	200,000	INSTALL WITH GAS COCK, UNION, AND DIRT LEG
RTU-5	ROOFTOP UNIT	2 LBS	YES	6 OZ.	100,000	INSTALL WITH GAS COCK, UNION, AND DIRT LEG
RTU-6	ROOFTOP UNIT	2 LBS	YES	6 OZ.	150,000	INSTALL WITH GAS COCK, UNION, AND DIRT LEG
RTU-7	ROOFTOP UNIT	2 LBS	YES	6 OZ.	200,000	INSTALL WITH GAS COCK, UNION, AND DIRT LEG
RTU-8	ROOFTOP UNIT	2 LBS	YES	6 OZ.	200,000	INSTALL WITH GAS COCK, UNION, AND DIRT LEG
RTU-9	ROOFTOP UNIT	2 LBS	YES	6 OZ.	100,000	INSTALL WITH GAS COCK, UNION, AND DIRT LEG
RTU-10	ROOFTOP UNIT	2 LBS	YES	6 OZ.	150,000	INSTALL WITH GAS COCK, UNION, AND DIRT LEG
RTU-11	ROOFTOP UNIT	2 LBS	YES	6 OZ.	150,000	INSTALL WITH GAS COCK, UNION, AND DIRT LEG
RTU-12	ROOFTOP UNIT	2 LBS	YES	6 OZ.	200,000	INSTALL WITH GAS COCK, UNION, AND DIRT LEG
RTU-13	ROOFTOP UNIT	2 LBS	YES	6 OZ.	200,000	INSTALL WITH GAS COCK, UNION, AND DIRT LEG
RTU-14	ROOFTOP UNIT	2 LBS	YES	6 OZ.	200,000	INSTALL WITH GAS COCK, UNION, AND DIRT LEG
RTU-15	ROOFTOP UNIT	2 LBS	YES	6 OZ.	200,000	INSTALL WITH GAS COCK, UNION, AND DIRT LEG
RTU-16	ROOFTOP UNIT	2 LBS	YES	6 OZ.	200,000	INSTALL WITH GAS COCK, UNION, AND DIRT LEG
RTU-17	ROOFTOP UNIT	2 LBS	YES	6 OZ.	200,000	INSTALL WITH GAS COCK, UNION, AND DIRT LEG
RTU-18	ROOFTOP UNIT	2 LBS	YES	6 OZ.	200,000	INSTALL WITH GAS COCK, UNION, AND DIRT LEG

GAS WATER HEATER SCHEDULE

MARK	MAKE	MODEL	INPUT (BTU)	RECOVERY @ 100 GPH	VENT DIA.	CONTROLS	EFFICIENCY	REMARKS
GWH-1	RINNAI	C159i	199,000	TANKLESS	5"	120V/1PH	97%	FURNISH VENT KITS & CONTROLS
GWH-2	RINNAI	C159i	199,000	TANKLESS	5"	120V/1PH	97%	FURNISH VENT KITS & CONTROLS
GWH-3	RINNAI	C159i	199,000	TANKLESS	5"	120V/1PH	97%	FURNISH VENT KITS & CONTROLS

FURNISH IN-LINE CONDENSATION NEUTRALIZATION KIT.

GAS PIPE CALCULATION
2 PSI SYSTEM

TABLE: 402.4(5), CURRENT EDITION FUEL GAS CODE SCHEDULE 40 METALLIC PIPE INLET PRESSURE: 2.0 PSI PRESSURE DROP: 1.0 PSI SPECIFIC GRAVITY: 0.60 LONGEST LENGTH OF PIPE: 420 FT TOTAL LOAD: 3,547 MBH		
MARK	DESCRIPTION	INPUT
GWH-1	GAS WATER HEATER	199 MBH
GWH-2	GAS WATER HEATER	199 MBH
GWH-3	GAS WATER HEATER	199 MBH
RTU-1	ROOFTOP UNIT	150 MBH
RTU-2	ROOFTOP UNIT	150 MBH
RTU-3	ROOFTOP UNIT	COOLING ONLY
RTU-4	ROOFTOP UNIT	200 MBH
RTU-5	ROOFTOP UNIT	100 MBH
RTU-6	ROOFTOP UNIT	150 MBH
RTU-7	ROOFTOP UNIT	200 MBH
RTU-8	ROOFTOP UNIT	200 MBH
RTU-9	ROOFTOP UNIT	200 MBH
RTU-10	ROOFTOP UNIT	150 MBH
RTU-11	ROOFTOP UNIT	150 MBH
RTU-12	ROOFTOP UNIT	200 MBH
RTU-13	ROOFTOP UNIT	200 MBH
RTU-14	ROOFTOP UNIT	200 MBH
RTU-15	ROOFTOP UNIT	200 MBH
RTU-16	ROOFTOP UNIT	200 MBH
RTU-17	ROOFTOP UNIT	200 MBH
RTU-18	ROOFTOP UNIT	200 MBH
TABLE: 402.4(2), CURRENT EDITION FUEL GAS CODE. USED FOR LESS THAN 2 PSI AFTER REGULATORS AT INDIVIDUAL EQUIPMENT.		



Brent Barron Architect

P 6 0 1 . 7 5 0 . 1 7 7 8

114 WOODY HILLS DR. AUSTON, MS 39110

PLUMBING SCHEDULES
CLUB 4 FITNESS - EL PASO MONTWOOD
11705 MONTWOOD DR. EL PASO, TX 79936

20250321

FOR CONSTRUCTION
JUNE 5, 2025



P6.1

NOTE: THE CONTRACT DRAWINGS ARE NOT ORGANIZED SPECIFICALLY FOR ANY CRAFT, TRADE, DISCIPLINE, OR SUBCONTRACT. THEREFORE, ADDITIONAL RELATED INFORMATION MAY BE INCLUDED IN OTHER CONTRACT DRAWINGS AND SPECIFICATIONS EVEN THOUGH NOT SPECIFICALLY NOTED ON THIS DOCUMENT. IT IS THE RESPONSIBILITY OF EACH PARTY TO REFER TO THE COMPLETE SET OF CONTRACT DRAWINGS AND SPECIFICATIONS, AND NOT TO A PARTIAL OR INCOMPLETE SET OF DOCUMENTS.